



**DEMOLITION KEY NOTES**

1. REMOVE EXISTING SPRINKLER HEADS, ASSOCIATED PIPING DROPS, AND BRANCHLINES IN AREA INDICATED BY HATCHING. FIRE MAINS SHALL BE OFFSET OR RELOCATED TO ACCOMMODATE ABOVE CEILING WORK BY OTHER TRADES.

**KEY PLAN**

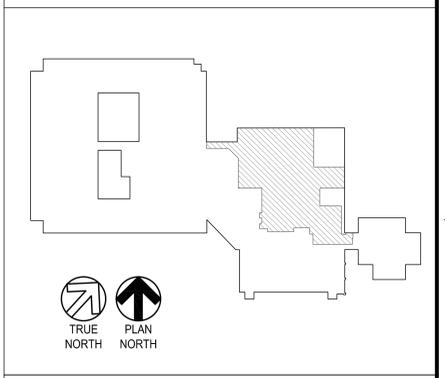

 **GRAPHIC SCALE**



**THIRD FLOOR  
DEMOLITION PLAN - PHASE 1**  
SCALE: 1/8" = 1'-0"

PROJECT: 190800412.TMM.VA.MEMPHIS.RENOVATE.OPS.0412.TMM.VA.MEMPHIS.RENOVATE.OPS.SHEETS.0412.D01.DWG

VA FORM 08-6231

Revisions:	Date:

**CONSULTANTS**


**CLARKNEXSEN**

440 Martin Luther King Jr. Blvd  
Macon, GA 31201  
478.743.8415 Fax: 478.743.8239  
www.clarknexsen.com

**ARCHITECT/ENGINEER OF RECORD**

**TOLAND MIZELL MOLNAR**

590 MEANS STREET NW  
STE. 200  
ATLANTA, GA 30318

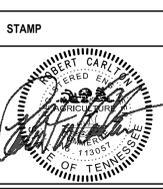

**Office of Construction and Facilities Management**

**VA** U.S. Department of Veterans Affairs

**Drawing Title**  
THIRD FLOOR DEMOLITION PLAN - PHASE 1


**Approved:** Project Director

**Phase**  
BID DOCUMENTS

**FULLY SPRINKLERED**

<b>Project Title</b> VA Memphis Renovate Operating Rooms		<b>Project Number</b> 614-18-115	
<b>Location</b> Memphis, TN		<b>Building Number</b> 01	
<b>Issue Date</b> 01/31/2020	<b>Checked</b> WW	<b>Drawn</b> PW	<b>Drawing Number</b> FD101 of




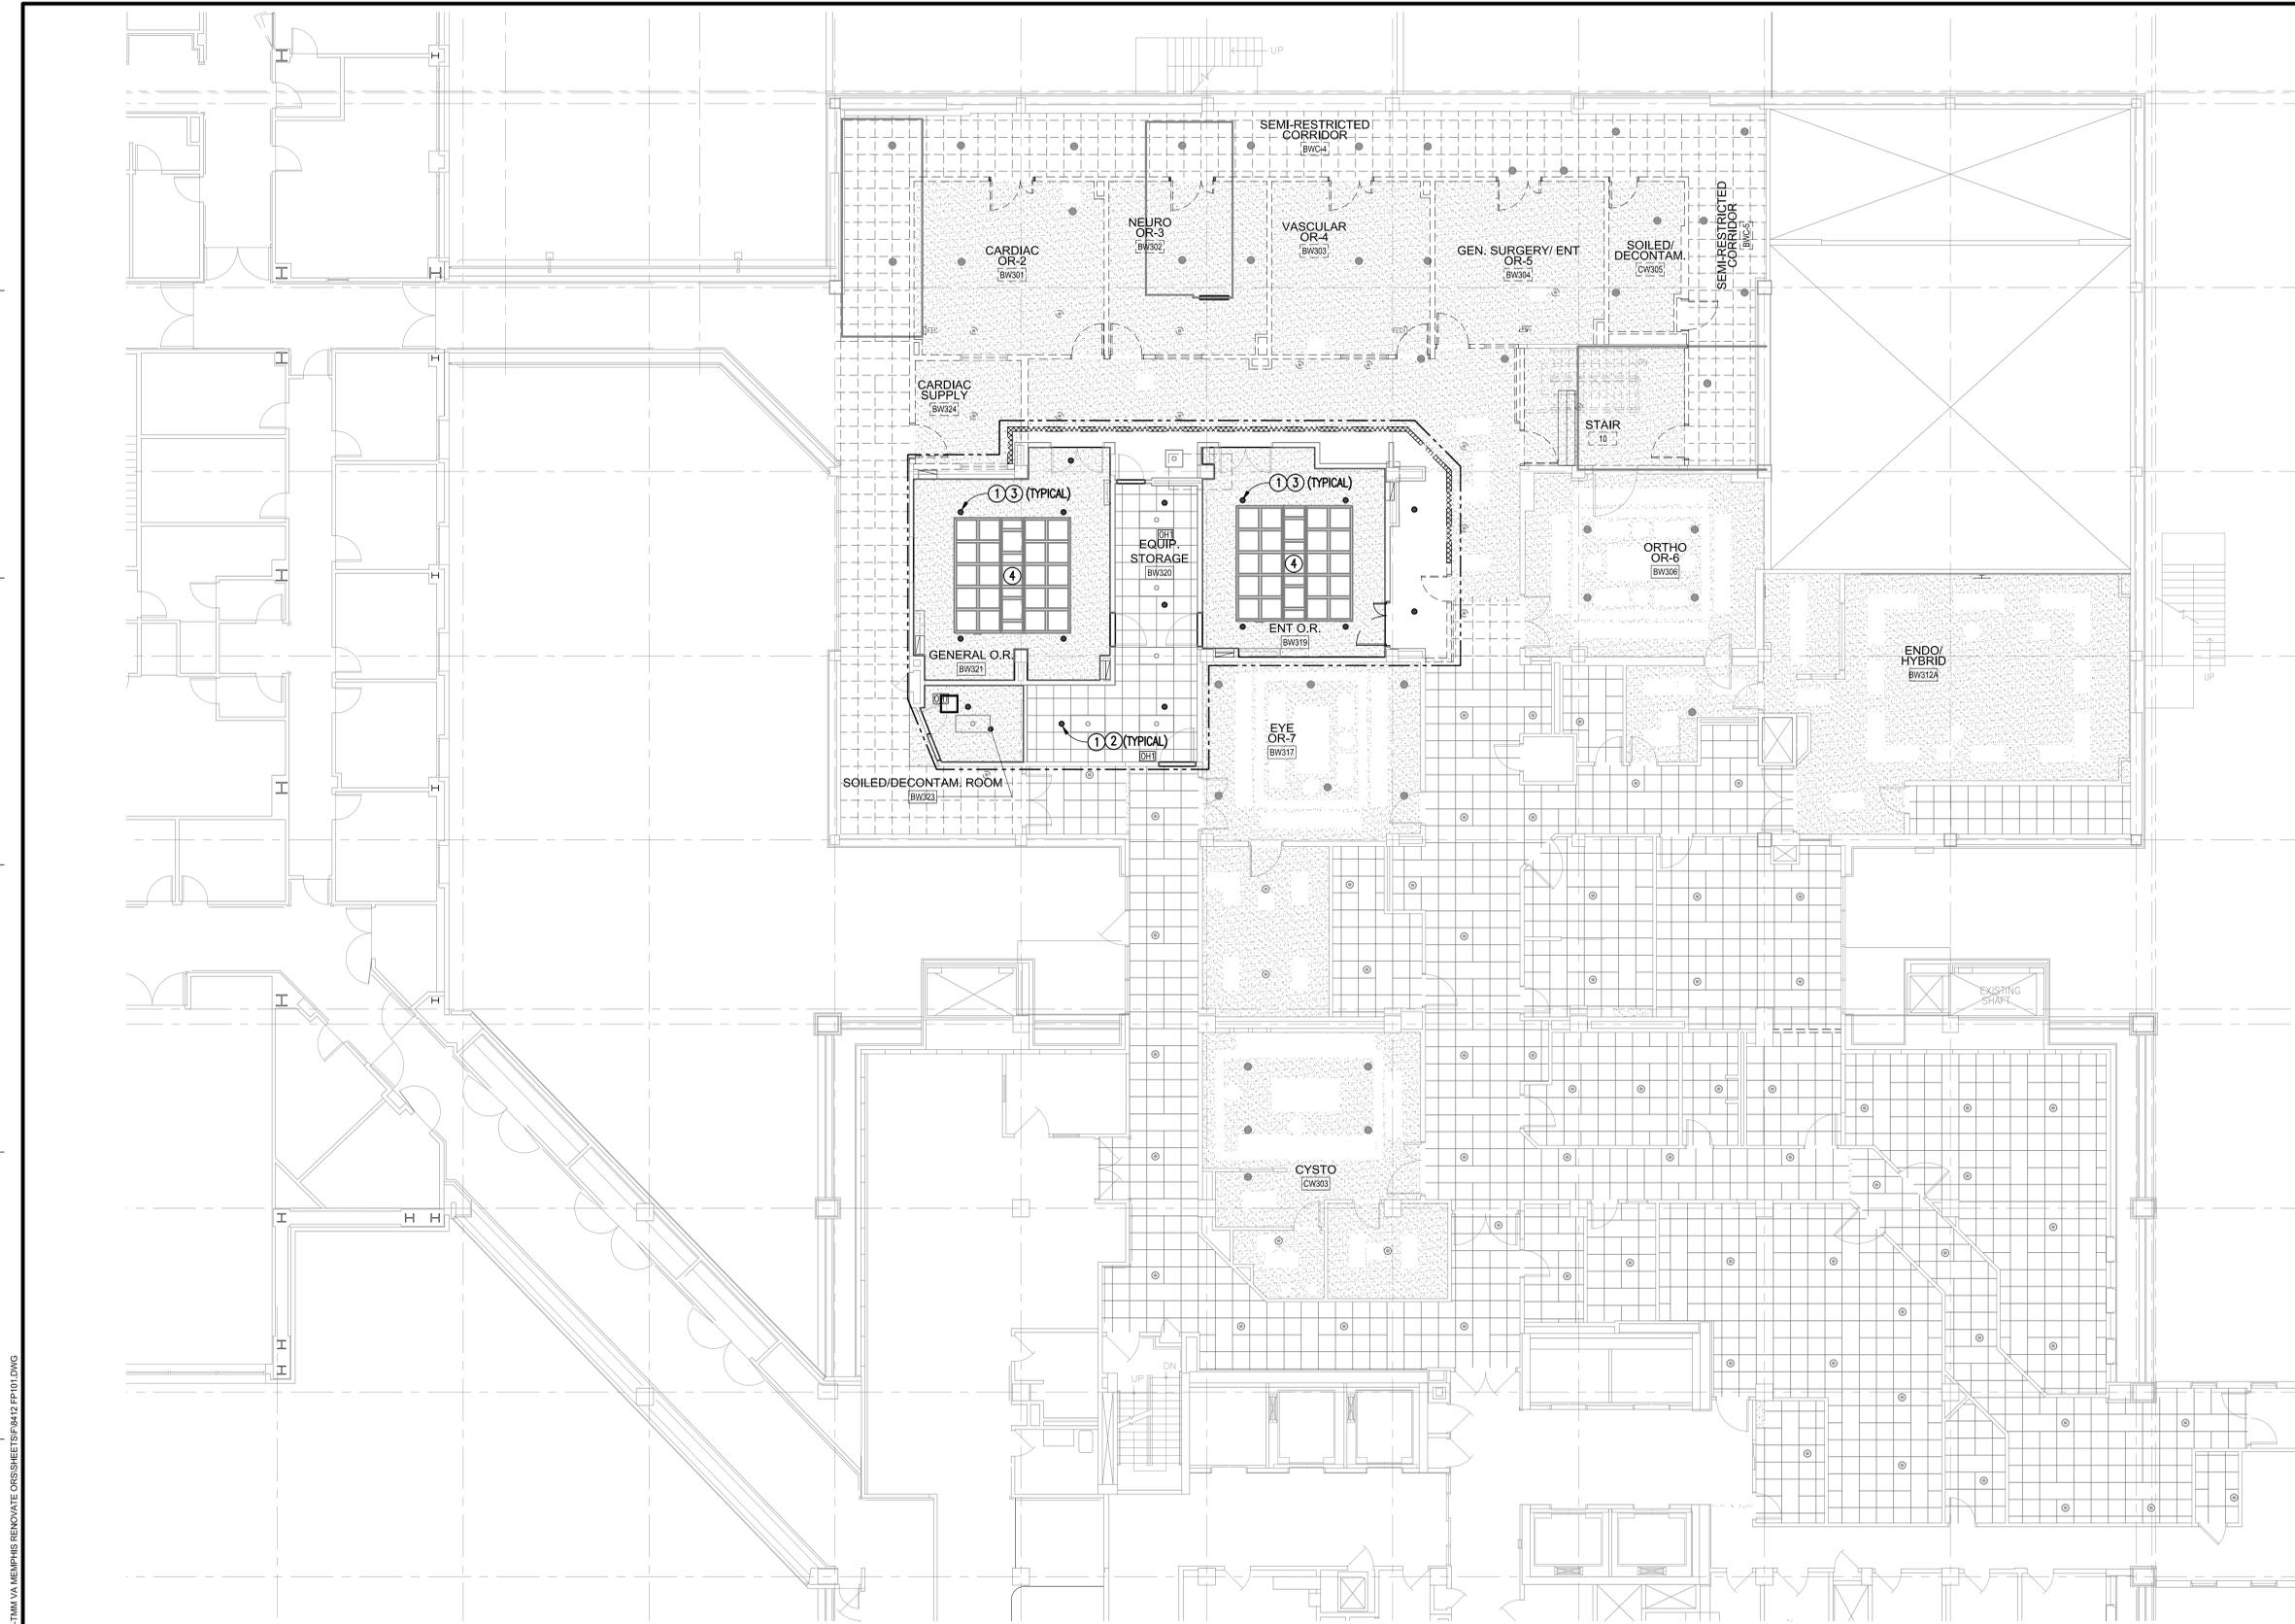

**KEY NOTES**

1. INSTALL NEW QUICK RESPONSE STANDARD COVERAGE PENDENT SPRINKLER HEADS IN ACCORDANCE WITH NFPA 13.
2. HEADS IN ACOUSTICAL TILE CEILINGS SHALL BE CENTERED IN TILES.
3. HEADS IN GYPSUM BOARD CEILINGS SHALL BE COORDINATED WITH OTHER CEILING EQUIPMENT AND SPACED UNIFORMLY.
4. CEILING AREA OTHER THAN GYPSUM BOARD IN OPERATING ROOMS IS A CLEAN SUITE CEILING SYSTEM THAT IS A SINGLE PIECE OF EQUIPMENT. COORDINATE WITH CEILING SYSTEM MANUFACTURER FOR ANY INTERACTION WITH SYSTEM.

**KEY PLAN**

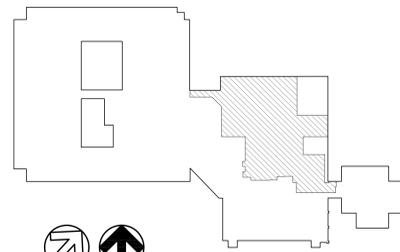

**GRAPHIC SCALE**

1/8" = 1'-0"

**THIRD FLOOR PLAN - PHASE 1**  
SCALE: 1/8" = 1'-0"

PROJECT: 08080412.TMM.VA.MEMPHIS.RENOVATE.ORS0412.TMM.VA.MEMPHIS.RENOVATE.ORS0412.FP01.DWG

Revisions:	Date:

**CONSULTANTS**

**CLARKNEXSEN**

440 Martin Luther King Jr. Blvd  
Macon, GA 31201  
478.743.8415 Fax: 478.743.8239  
www.clarknexsen.com

**ARCHITECT/ENGINEER OF RECORD**

**TOLAND MIZELL MOLNAR**

590 MEANS STREET NW  
STE. 200  
ATLANTA, GA 30318

**STAMP**

**Office of Construction and Facilities Management**

**VA** U.S. Department of Veterans Affairs


**Drawing Title**  
THIRD FLOOR PLAN - PHASE 1

**Approved:** Project Director



**Phase**  
BID DOCUMENTS

**FULLY SPRINKLERED**

<b>Project Title</b> VA Memphis Renovate Operating Rooms		<b>Project Number</b> 614-18-115	
<b>Location</b> Memphis, TN		<b>Building Number</b> 01	
<b>Issue Date</b> 01/31/2020	<b>Checked</b> WW	<b>Drawn</b> PW	<b>Drawing Number</b> FP101 of

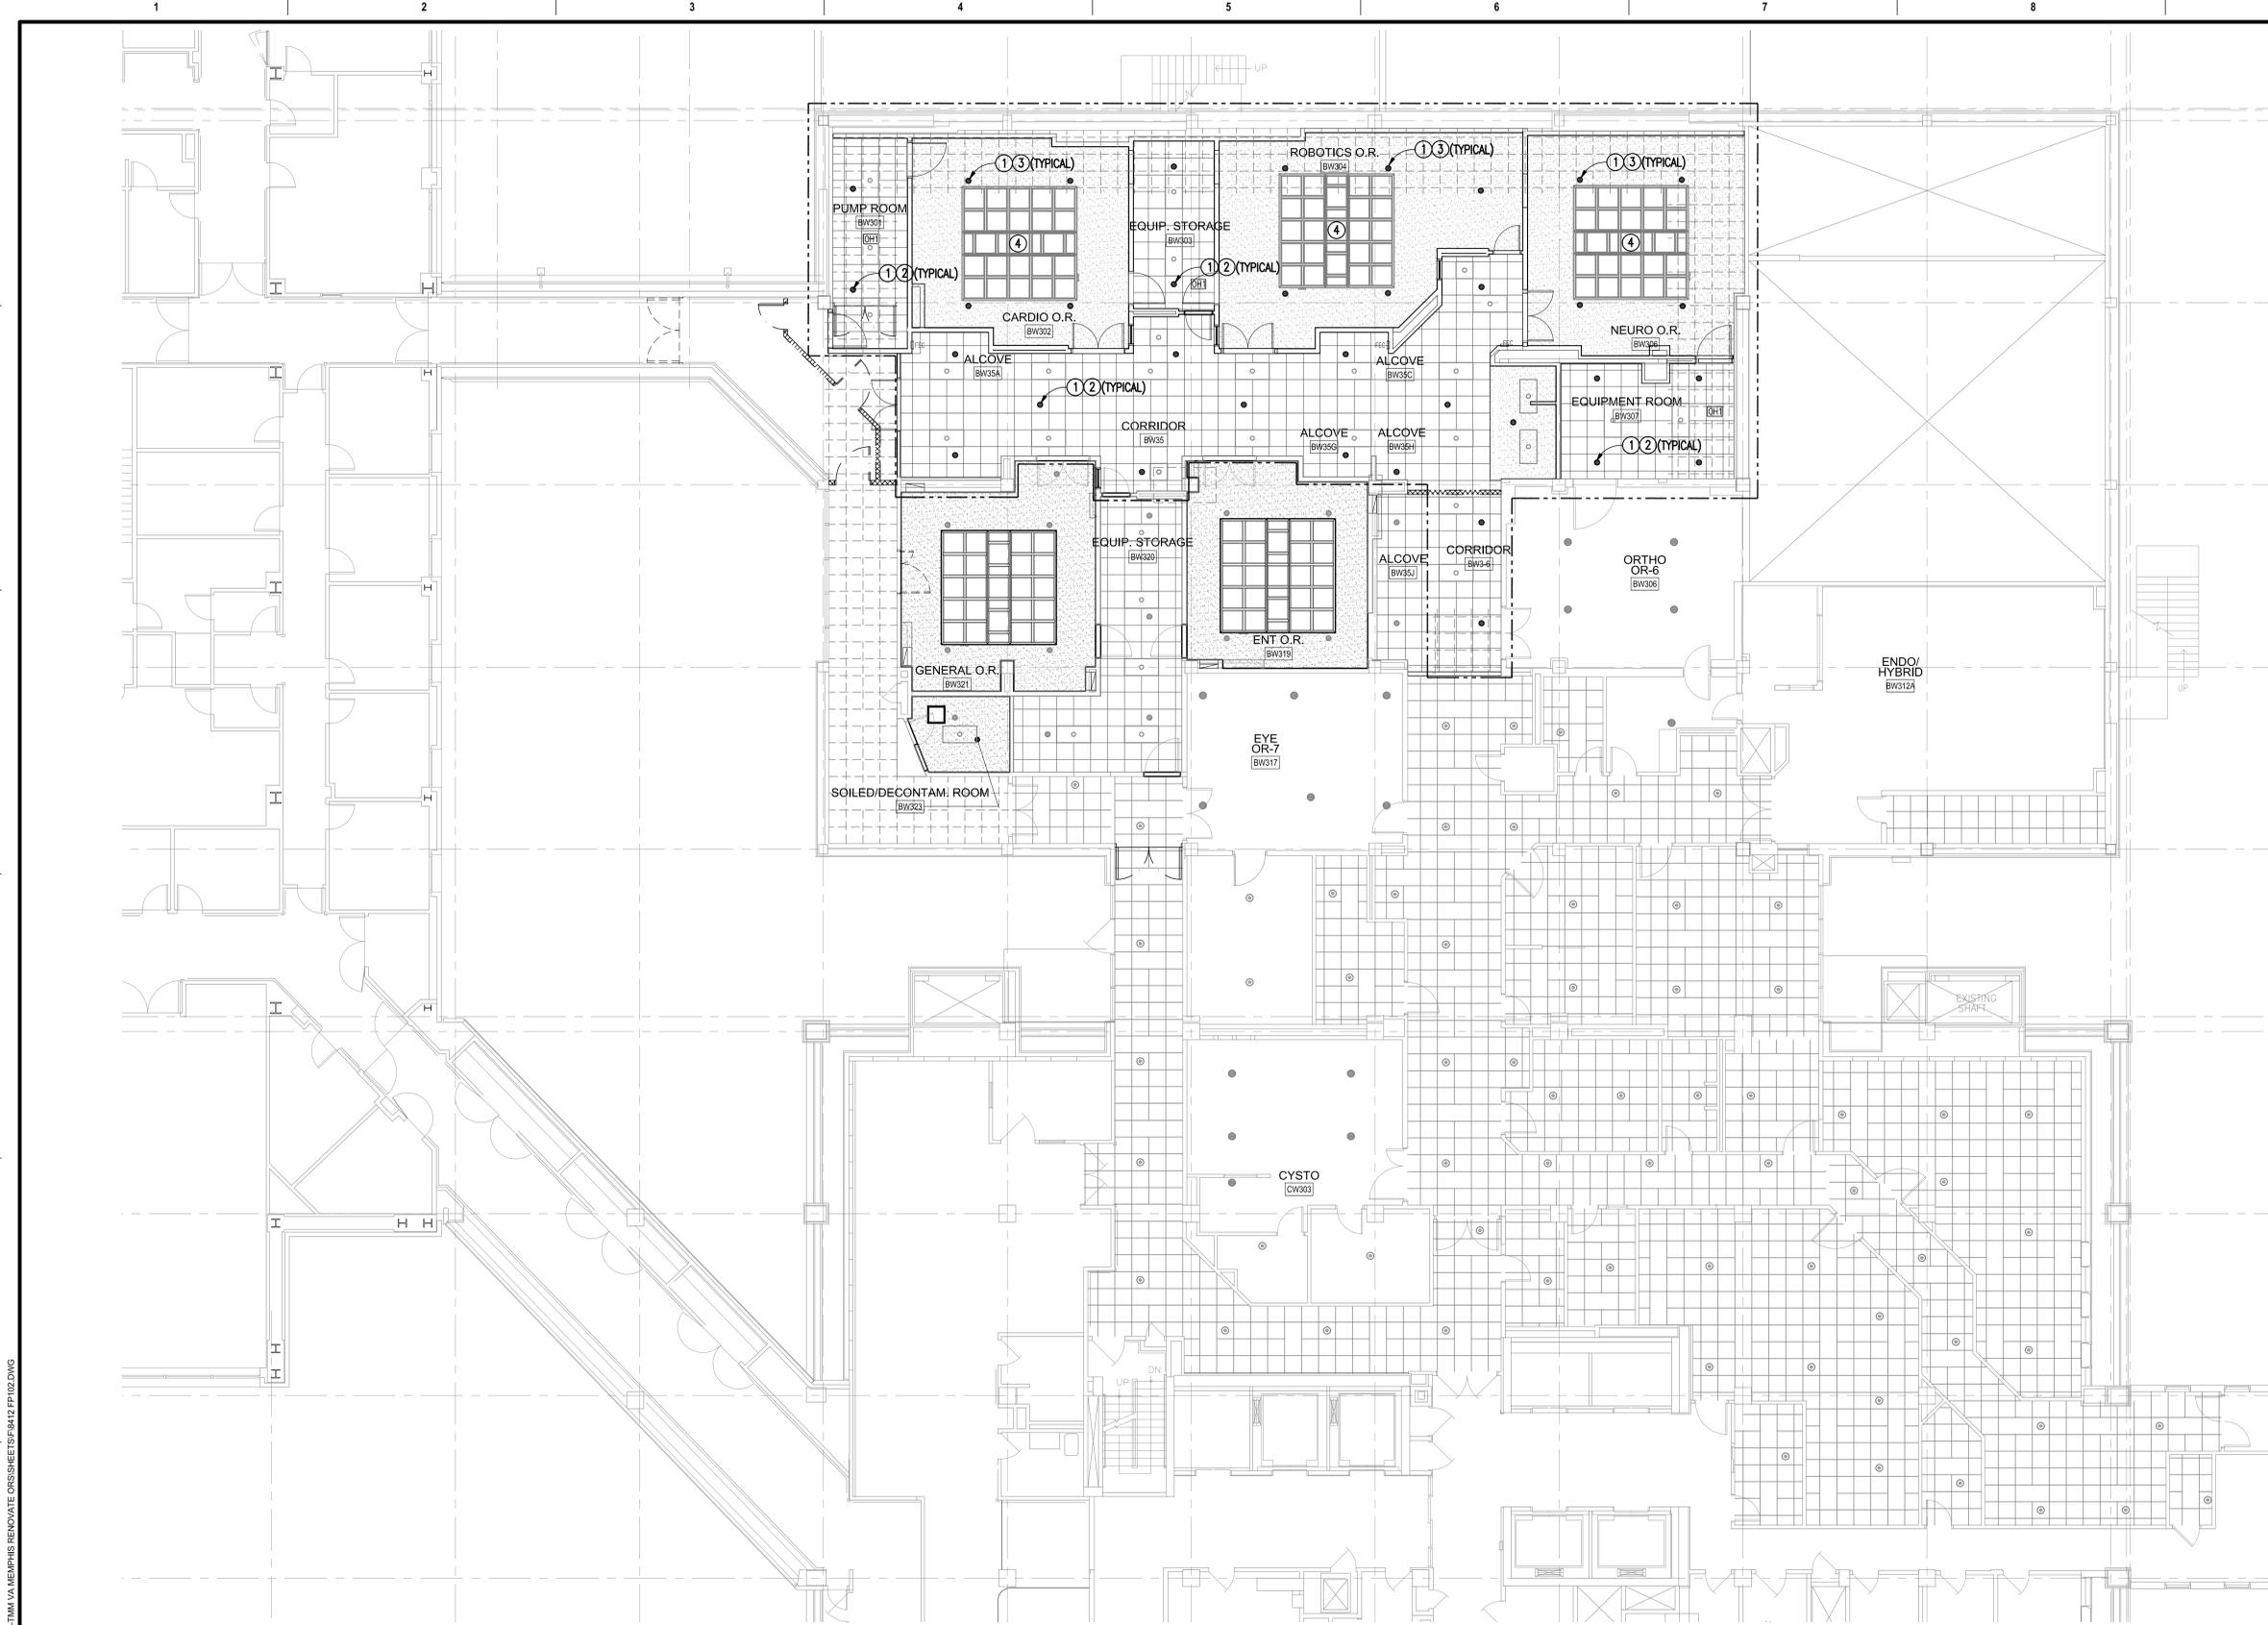

- KEY NOTES**
1. INSTALL NEW QUICK RESPONSE STANDARD COVERAGE PENDENT SPRINKLER HEADS IN ACCORDANCE WITH NFPA 13.
  2. HEADS IN ACOUSTICAL TILE CEILINGS SHALL BE CENTERED IN TILES.
  3. HEADS IN GYPSUM BOARD CEILINGS SHALL BE COORDINATED WITH OTHER CEILING EQUIPMENT AND SPACED UNIFORMLY.
  4. CEILING AREA OTHER THAN GYPSUM BOARD IN OPERATING ROOMS IS A CLEAN SUITE CEILING SYSTEM THAT IS A SINGLE PIECE OF EQUIPMENT. COORDINATE WITH CEILING SYSTEM MANUFACTURER FOR ANY INTERACTION WITH SYSTEM.

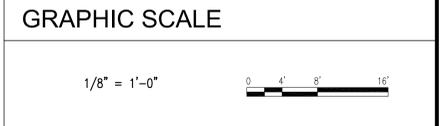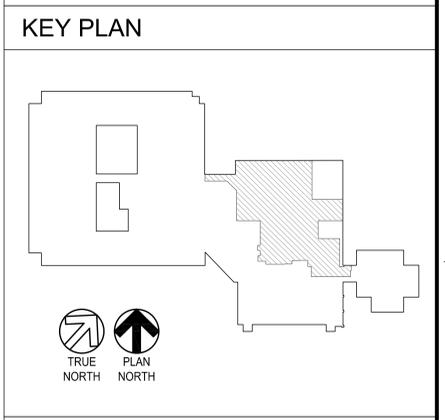

**THIRD FLOOR PLAN - PHASE 2**  
SCALE: 1/8" = 1'-0"

PROJECT: 08000412.TMM.VA.MEMPHIS.RENOVATE.CRS.0412.TMM.VA.MEMPHIS.RENOVATE.CRS.SHEETS.0412.FP.02.DWG

VA FORM 08-6231

Revisions:	Date:

**CONSULTANTS**


**CLARKNEXSEN**

440 Martin Luther King Jr. Blvd  
Macon, GA 31201  
478.743.8415 Fax: 478.743.8239  
www.clarknexsen.com

**ARCHITECT/ENGINEER OF RECORD**

**TOLAND MIZELL MOLNAR**

590 MEANS STREET NW  
STE. 200  
ATLANTA, GA 30318

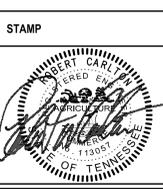

**Office of Construction and Facilities Management**

**VA** U.S. Department of Veterans Affairs

**Drawing Title**  
THIRD FLOOR PLAN - PHASE 2

**Phase**  
BID DOCUMENTS

**Approved:** Project Director

**FULLY SPRINKLERED**

<b>Project Title</b> VA Memphis Renovate Operating Rooms		<b>Project Number</b> 614-18-115	
<b>Location</b> Memphis, TN		<b>Building Number</b> 01	
<b>Issue Date</b> 01/31/2020	<b>Checked</b> WW	<b>Drawn</b> PW	<b>Drawing Number</b> FP102 of