
 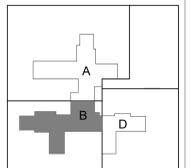


- GENERAL NOTES:**
- REFER TO SHEET T-000 FOR GENERAL NOTES AND LEGENDS.
 - ALL HORIZONTAL CABLING ON THIS FLOOR TO BE TERMINATED IN TR-4.
 - CONTRACTOR SHALL INSTALL BACKBONE RISER SLEEVES OF THE SIZE AS INDICATED ON THE PLANS. REFER TO SECTION 27 15 00 COMMUNICATIONS STRUCTURED CABLING AND SECTION 27 05 33 RACEWAYS AND BOXES FOR COMMUNICATIONS SYSTEMS.
 - CONTRACTOR SHALL X-RAY CONCRETE FLOOR BEFORE CORE DRILLING. CONTRACTOR SHALL COORDINATE WITH THE COR BEFORE BEGINNING DRILLING.
 - CONTRACTOR SHALL FIRESTOP RISER SLEEVES AND EMPTY SPARE RISER SLEEVES. REFER TO SECTION 07 04 00 FIRESTOPPING.
 - CONTRACTOR SHALL INSTALL A VERTICAL LADDER TYPE CABLE TRAY ON THE WALL ABOVE THE VERTICAL RISER SLEEVES FOR BACKBONE CABLE SUPPORT AS INDICATED ON THE PLANS. THE CABLE TRAY SHALL BE SECURELY ANCHORED TO THE WALL SUFFICIENT TO SUPPORT THE TOTAL WEIGHT OF CABLES AND CABLE TRAY PLUS 50%.
 - CONTRACTOR SHALL INSTALL CABLE SUPPORTS SUFFICIENT TO SUPPORT COMMUNICATIONS CABLES ON THE VERTICAL CABLE TRAY WITHOUT DAMAGING OR DEFORMING THE CABLE.
 - CONTRACTOR SHALL LABEL EACH CABLE AT 42 INCHES A.F.F. ON EACH FLOOR. REFER TO SECTION 27 15 00 COMMUNICATIONS STRUCTURED CABLING.
 - CONTRACTOR SHALL INSTALL NEW J-HOOKS WHERE THERE IS NO CABLE TRAY OR COMMUNICATIONS CONDUIT UNLESS OTHERWISE NOTED.
 - CONTRACTOR SHALL INSTALL NEW CATEGORY 6A PATCH PANELS IN THE TELECOMMUNICATION ROOM AS INDICATED ON RACK ELEVATIONS.
 - CONTRACTOR SHALL RE-TERMINATE AND TEST CABLING REMOVED FROM ANY WALL MOUNT EQUIPMENT UNLESS OTHERWISE NOTED. TESTING SHALL BE PERFORMED BY THE CONTRACTOR DURING COMMISSIONING.
 - CONTRACTOR SHALL INSTALL NEW CATEGORY 6A TELECOMMUNICATIONS DATA OUTLET AS INDICATED. EXISTING COMMUNICATION OUTLET BOXES AND CONDUITS TO BE REUSED.
 - CONTRACTOR SHALL REPLACE ALL DATA CABLE WITH NEW CATEGORY 6A CABLE UNLESS OTHERWISE NOTED.
 - CONTRACTOR SHALL TERMINATE COMMUNICATIONS CABLES WITH NEW CATEGORY MODULAR JACKS TO MATCH THE COMMUNICATION CABLE PERFORMANCE SPECIFICATIONS. NEW MODULAR JACKS SHALL BE OF THE SAME MANUFACTURER AS THE FACE PLATES, PATCH PANELS, AND PATCH CABLES.
 - CONTRACTOR SHALL INSTALL NEW CATEGORY 6A CABLES AND CONNECTIVITY COMPONENTS THAT ARE OF THE SAME MANUFACTURER, INCLUDING CABLE, MODULAR JACKS, PATCH PANELS, FACEPLATES, AND PATCH CABLES.
 - CONTRACTOR SHALL TEST ALL NEW AND EXISTING RE-TERMINATED CABLES IN ACCORDANCE WITH THE SPECIFICATION 27 08 00.

- KEYED NOTES:**
- EXISTING TELECOMMUNICATIONS ROOM.
 - EXISTING CONDITIONS WERE NOT OBSERVED. DATA SHOWN IN ROOM IS AN ESTIMATE OF WHAT WILL BE REQUIRED.
 - PROVIDE (4) 4" CONDUITS TO TR ON LEVEL ABOVE.

1 TECHNOLOGY FOURTH FLOOR PARTIAL PLAN - B
1/8" = 1'-0"



Description	Date

CONSULTANT
Ross & Baruzzini
LOW VOLTAGE/ IT
Ross & Baruzzini Inc.
1600 Riveredge Parkway NW
Suite 900
Atlanta, GA 30328

PROJECT MANAGEMENT
HFS
C O M P A N Y
8718 Botts Lane
San Antonio, Texas 78217
www.hfscmpany.com
Phone: (210) 816-4784
Fax: (210) 881-6808
jbianco@hfscmpany.com



Construction and Facilities Management
VA U.S. Department of Veterans Affairs

Drawing Title
TECHNOLOGY FOURTH FLOOR PARTIAL PLAN - B
Approved: Project Director

Phase
100% CONSTRUCTION DOCUMENTS
FULLY SPRINKLERED


 
Project Title
CINCINNATI VAMC EHRM INFRASTRUCTURE UPGRADES
Location
3200 VINE ST. CINCINNATI, OH. 45220
Issue Date
04-MAY-2022
Scale
1/8" = 1'-0"

Project Number
539-21-701
Building Number
C1
Drawing Number
TN-152-C.1.4

- GENERAL NOTES:**
- REFER TO SHEET T-000 FOR GENERAL NOTES AND LEGENDS.
 - ALL HORIZONTAL CABLING ON THIS FLOOR TO BE TERMINATED IN TR-4.
 - CONTRACTOR SHALL INSTALL BACKBONE RISER SLEEVES OF THE SIZE AS INDICATED ON THE PLANS. REFER TO SECTION 27 15 00 COMMUNICATIONS STRUCTURED CABLING AND SECTION 27 05 33 RACEWAYS AND BOXES FOR COMMUNICATIONS SYSTEMS.
 - CONTRACTOR SHALL X-RAY CONCRETE FLOOR BEFORE CORE DRILLING. CONTRACTOR SHALL COORDINATE WITH THE COR BEFORE BEGINNING DRILLING.
 - CONTRACTOR SHALL FIRESTOP RISER SLEEVES AND EMPTY SPARE RISER SLEEVES. REFER TO SECTION 07 84 00 FIRESTOPPING.
 - CONTRACTOR SHALL INSTALL AN VERTICAL LADDER TYPE CABLE TRAY ON THE WALL ABOVE THE VERTICAL RISER SLEEVES FOR BACKBONE CABLE SUPPORT AS INDICATED ON THE PLANS. THE CABLE TRAY SHALL BE SECURELY ANCHORED TO THE WALL SUFFICIENT TO SUPPORT THE TOTAL WEIGHT OF CABLES AND CABLE TRAY PLUS 50%.
 - CONTRACTOR SHALL INSTALL CABLE SUPPORTS SUFFICIENT TO SUPPORT COMMUNICATIONS CABLES ON THE VERTICAL CABLE TRAY WITHOUT DAMAGING OR DEFORMING THE CABLE.
 - CONTRACTOR SHALL LABEL EACH CABLE AT 42 INCHES A.F.F. ON EACH FLOOR. REFER TO SECTION 27 15 00 COMMUNICATIONS STRUCTURED CABLING.
 - CONTRACTOR SHALL INSTALL NEW J-HOOKS WHERE THERE IS NO CABLE TRAY OR COMMUNICATIONS CONDUIT UNLESS OTHERWISE NOTED.
 - CONTRACTOR SHALL INSTALL NEW CATEGORY 6A PATCH PANELS IN THE TELECOMMUNICATION ROOM AS INDICATED ON RACK ELEVATIONS.
 - CONTRACTOR SHALL RE-TERMINATE AND TEST CABLING REMOVED FROM ANY WALL MOUNT EQUIPMENT UNLESS OTHERWISE NOTED. TESTING SHALL BE PERFORMED BY THE CONTRACTOR DURING COMMISSIONING.
 - CONTRACTOR SHALL INSTALL NEW CATEGORY 6A TELECOMMUNICATIONS/ DATA OUTLET AS INDICATED. EXISTING COMMUNICATION OUTLET BOXES AND CONDUITS TO BE REUSED.
 - CONTRACTOR SHALL REPLACE ALL DATA CABLE WITH NEW CATEGORY 6A CABLE UNLESS OTHERWISE NOTED.
 - CONTRACTOR SHALL TERMINATE COMMUNICATIONS CABLES WITH NEW CATEGORY MODULAR JACKS TO MATCH THE COMMUNICATION CABLE PERFORMANCE SPECIFICATIONS. NEW MODULAR JACKS SHALL BE OF THE SAME MANUFACTURER AS THE FACE PLATES, PATCH PANELS, AND PATCH CABLES.
 - CONTRACTOR SHALL INSTALL NEW CATEGORY 6A CABLES AND CONNECTIVITY COMPONENTS THAT ARE OF THE SAME MANUFACTURER, INCLUDING CABLE, MODULAR JACKS, PATCH PANELS, FACEPLATES, AND PATCH CABLES.
 - CONTRACTOR SHALL TEST ALL NEW AND EXISTING RE-TERMINATED CABLES IN ACCORDANCE WITH THE SPECIFICATION 27 08 00.

- KEYED NOTES:**
- EXISTING TELECOMMUNICATIONS ROOM.
 - EXISTING CONDITIONS WERE NOT OBSERVED. DATA SHOWN IN ROOM IS AN ESTIMATE OF WHAT WILL BE REQUIRED.

1 TECHNOLOGY FOURTH FLOOR PARTIAL PLAN - D
1/8" = 1'-0"

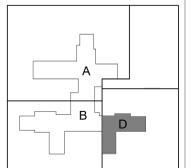

Description	Date

CONSULTANT
Ross & Baruzzini
LOW VOLTAGE/ IT
Ross & Baruzzini Inc.
1600 Riveredge Parkway NW
Suite 900
Atlanta, GA 30328

PROJECT MANAGEMENT
HFS
C O M P A N Y
8718 Botts Lane
San Antonio, Texas 78217
www.hfscorporation.com
Phone: (210) 816-4784
Fax: (210) 881-8808
jbiano@hfscorporation.com



Construction and Facilities Management
VA U.S. Department of Veterans Affairs

Drawing Title
TECHNOLOGY FOURTH FLOOR PARTIAL PLAN - D
Approved: Project Director


Phase
100% CONSTRUCTION DOCUMENTS
FULLY SPRINKLERED

Project Title
CINCINNATI VAMC EHRM INFRASTRUCTURE UPGRADES
Location
3200 VINE ST. CINCINNATI, OH. 45220
Issue Date
04-MAY-2022
Scale
1/8" = 1'-0"



Project Number
539-21-701
Building Number
C1
Drawing Number
TN-153-C.1.4

- GENERAL NOTES:**
- REFER TO SHEET T-000 FOR GENERAL NOTES AND LEGENDS.
 - ALL HORIZONTAL CABLING ON THIS FLOOR TO BE TERMINATED IN TR-5.
 - CONTRACTOR SHALL INSTALL BACKBONE RISER SLEEVES OF THE SIZE AS INDICATED ON THE PLANS. REFER TO SECTION 27 15 00 COMMUNICATIONS STRUCTURED CABLING AND SECTION 27 05 33 RACEWAYS AND BOXES FOR COMMUNICATIONS SYSTEMS.
 - CONTRACTOR SHALL X-RAY CONCRETE FLOOR BEFORE CORE DRILLING. CONTRACTOR SHALL COORDINATE WITH THE COR BEFORE BEGINNING DRILLING.
 - CONTRACTOR SHALL FIRESTOP RISER SLEEVES AND EMPTY SPARE RISER SLEEVES. REFER TO SECTION 07 64 00 FIRESTOPPING.
 - CONTRACTOR SHALL INSTALL A VERTICAL LADDER TYPE CABLE TRAY ON THE WALL ABOVE THE VERTICAL RISER SLEEVES FOR BACKBONE CABLE SUPPORT AS INDICATED ON THE PLANS. THE CABLE TRAY SHALL BE SECURELY ANCHORED TO THE WALL SUFFICIENT TO SUPPORT THE TOTAL WEIGHT OF CABLES AND CABLE TRAY PLUS 50%.
 - CONTRACTOR SHALL INSTALL CABLE SUPPORTS SUFFICIENT TO SUPPORT COMMUNICATIONS CABLES ON THE VERTICAL CABLE TRAY WITHOUT DAMAGING OR DEFORMING THE CABLE.
 - CONTRACTOR SHALL LABEL EACH CABLE AT 42 INCHES A.F.F. ON EACH FLOOR. REFER TO SECTION 27 15 00 COMMUNICATIONS STRUCTURED CABLING.
 - CONTRACTOR SHALL INSTALL NEW J-HOOKS WHERE THERE IS NO CABLE TRAY OR COMMUNICATIONS CONDUIT UNLESS OTHERWISE NOTED.
 - CONTRACTOR SHALL INSTALL NEW CATEGORY 6A PATCH PANELS IN THE TELECOMMUNICATION ROOM AS INDICATED ON RACK ELEVATIONS.
 - CONTRACTOR SHALL RE-TERMINATE AND TEST CABLING REMOVED FROM ANY WALL MOUNT EQUIPMENT UNLESS OTHERWISE NOTED. TESTING SHALL BE PERFORMED BY THE CONTRACTOR DURING COMMISSIONING.
 - CONTRACTOR SHALL INSTALL NEW CATEGORY 6A TELECOMMUNICATIONS/ DATA OUTLET AS INDICATED. EXISTING COMMUNICATION OUTLET BOXES AND CONDUITS TO BE REUSED.
 - CONTRACTOR SHALL REPLACE ALL DATA CABLE WITH NEW CATEGORY 6A CABLE UNLESS OTHERWISE NOTED.
 - CONTRACTOR SHALL TERMINATE COMMUNICATIONS CABLES WITH NEW CATEGORY MODULAR JACKS TO MATCH THE COMMUNICATION CABLE PERFORMANCE SPECIFICATIONS. NEW MODULAR JACKS SHALL BE OF THE SAME MANUFACTURER AS THE FACE PLATES, PATCH PANELS, AND PATCH CABLES.
 - CONTRACTOR SHALL INSTALL NEW CATEGORY 6A CABLES AND CONNECTIVITY COMPONENTS THAT ARE OF THE SAME MANUFACTURER, INCLUDING CABLE, MODULAR JACKS, PATCH PANELS, FACEPLATES, AND PATCH CABLES.
 - CONTRACTOR SHALL TEST ALL NEW AND EXISTING RE-TERMINATED CABLES IN ACCORDANCE WITH THE SPECIFICATION 27 08 00.

- KEYED NOTES:**
- EXISTING TELECOMMUNICATIONS ROOM.
 - PROVIDE (4) 4" CONDUITS TO TR ON LEVEL BELOW.
 - PROVIDE (4) 4" CONDUITS TO TR ON LEVEL ABOVE.
 - 12 INCH X 4 INCH WIRE MESH CABLE TRAY

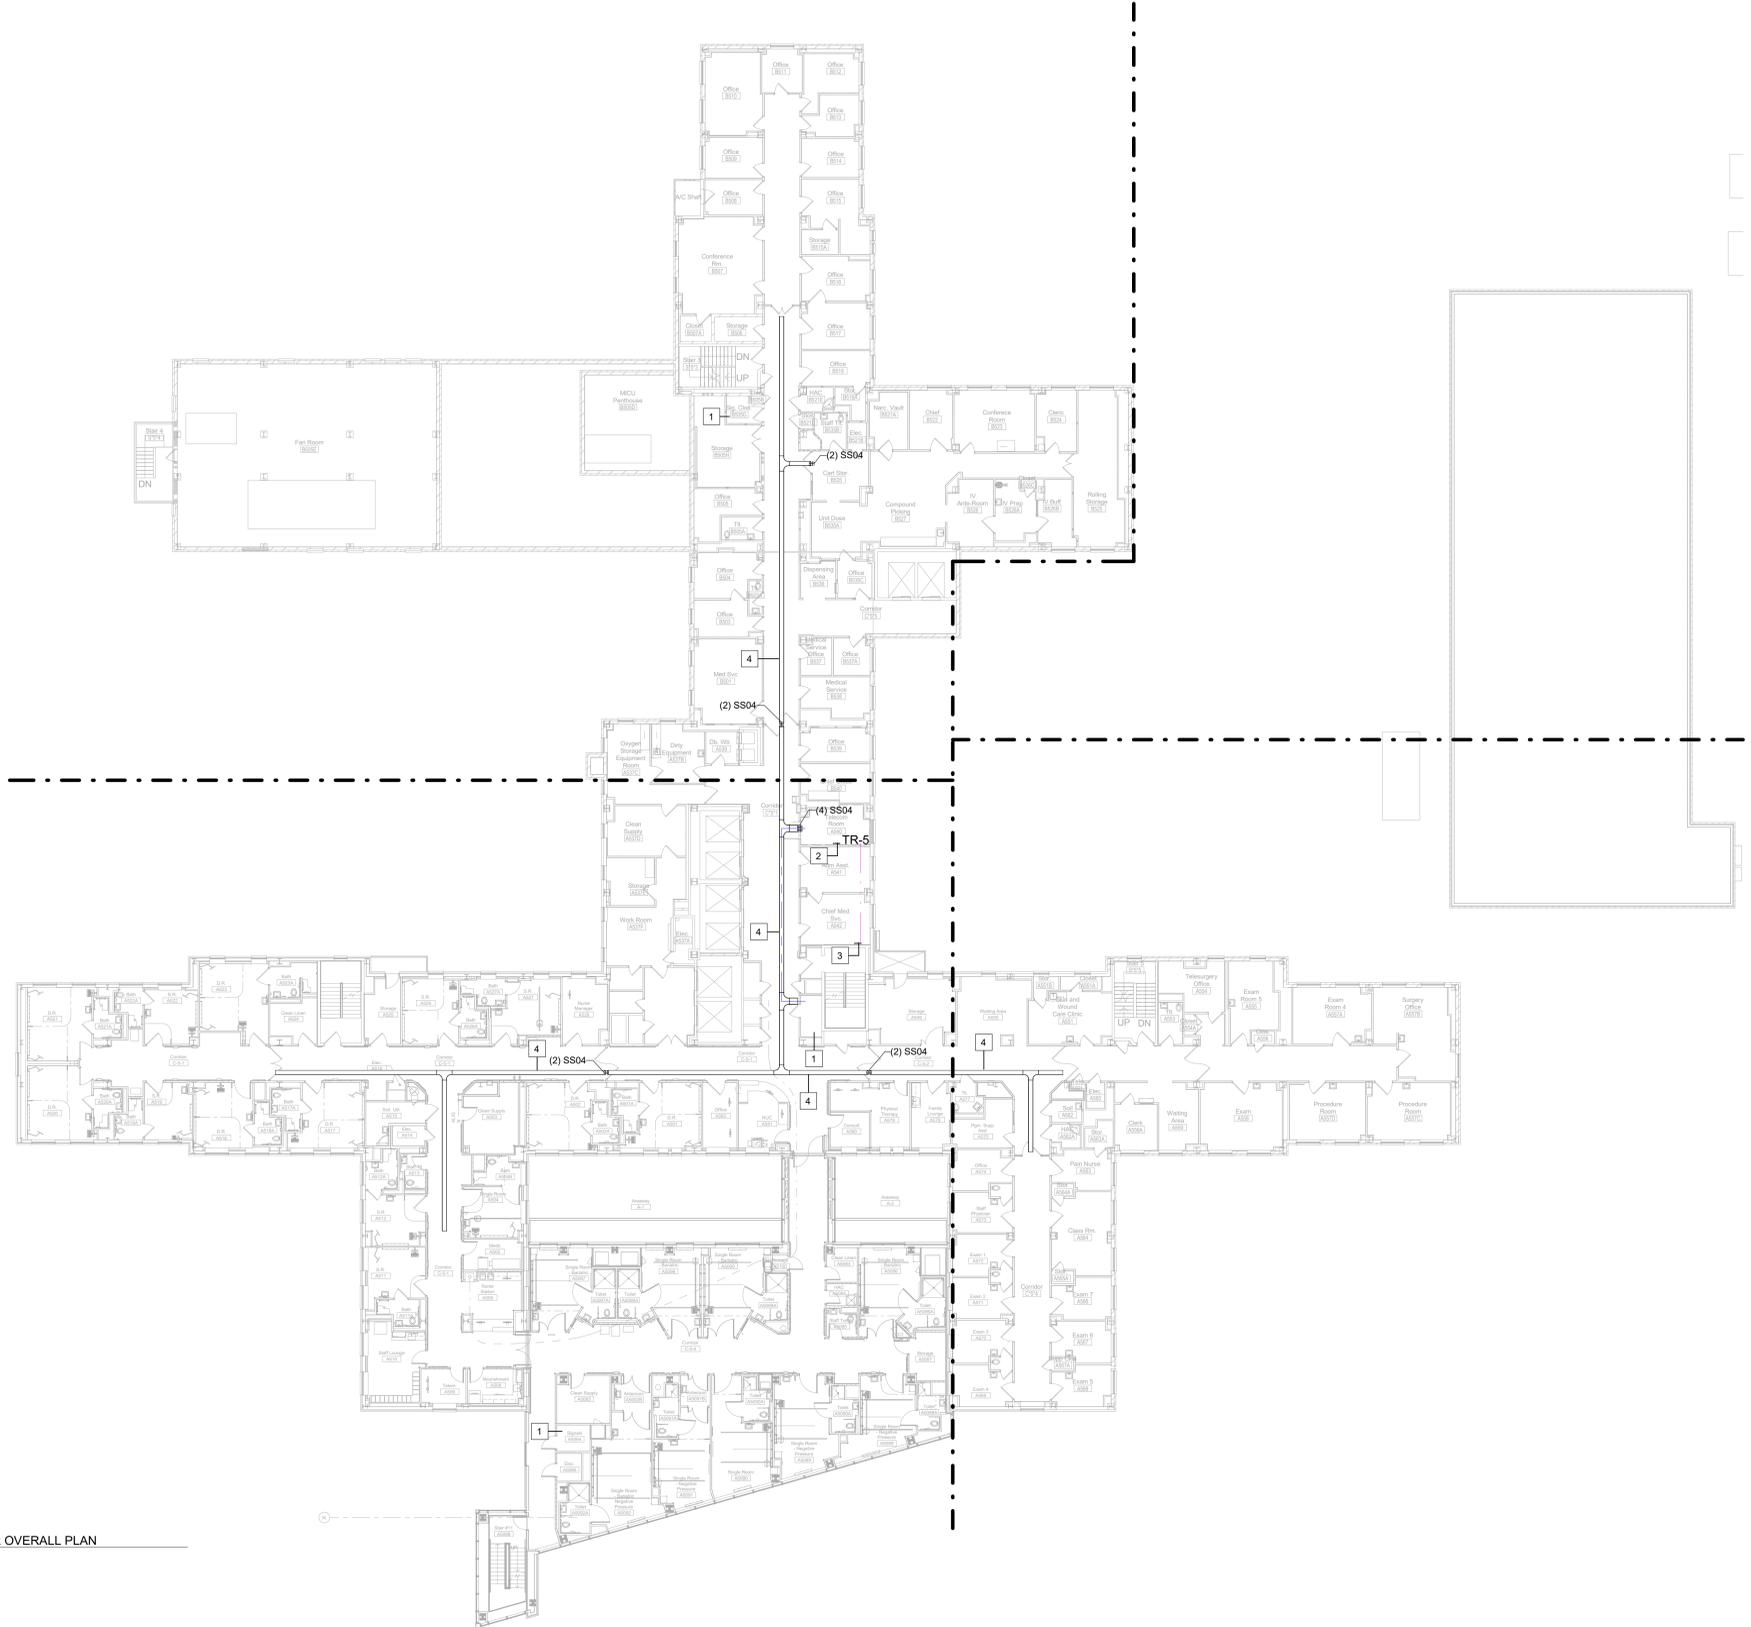

 1 TECHNOLOGY FIFTH FLOOR OVERALL PLAN
1/16" = 1'-0"

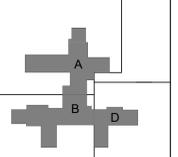

ADDENDUM 1	Description	Date	CONSULTANT		PROJECT MANAGEMENT		Drawing Title	Phase	Project Title	Project Number
			Ross & Baruzzini		HFS COMPANY					
		4/29/2022	LOW VOLTAGE/ IT Ross & Baruzzini Inc. 1600 Riveredge Parkway NW Suite 900 Atlanta, GA 30328		8718 Botts Lane San Antonio, Texas 78217 www.hfscompany.com jbianco@hfscompany.com		Approved: Project Director	FULLY SPRINKLERED	3200 VINE ST. CINCINNATI, OH. 45220	Building Number C1
									Issue Date: 04-MAY-2022	Checked By: PR
									Scale: 1/16" = 1'-0"	Drawing Number TN-160-C.1.5



GENERAL NOTES:


 
- REFER TO SHEET T-000 FOR GENERAL NOTES AND LEGENDS.
- ALL HORIZONTAL CABLING ON THIS FLOOR TO BE TERMINATED IN TR-5.
- CONTRACTOR SHALL INSTALL BACKBONE RISER SLEEVES OF THE SIZE AS INDICATED ON THE PLANS. REFER TO SECTION 27 15 00 COMMUNICATIONS STRUCTURED CABLING AND SECTION 27 05 33 RACEWAYS AND BOXES FOR COMMUNICATIONS SYSTEMS.
- CONTRACTOR SHALL X-RAY CONCRETE FLOOR BEFORE CORE DRILLING. CONTRACTOR SHALL COORDINATE WITH THE COR BEFORE BEGINNING DRILLING.
- CONTRACTOR SHALL FIRESTOP RISER SLEEVES AND EMPTY SPARE RISER SLEEVES. REFER TO SECTION 07 40 00 FIRESTOPPING.
- CONTRACTOR SHALL INSTALL AN VERTICAL LADDER TYPE CABLE TRAY ON THE WALL ABOVE THE VERTICAL RISER SLEEVES FOR BACKBONE CABLE SUPPORT AS INDICATED ON THE PLANS. THE CABLE TRAY SHALL BE SECURELY ANCHORED TO THE WALL SUFFICIENT TO SUPPORT THE TOTAL WEIGHT OF CABLES AND CABLE TRAY PLUS 50%.
- CONTRACTOR SHALL INSTALL CABLE SUPPORTS SUFFICIENT TO SUPPORT COMMUNICATIONS CABLES ON THE VERTICAL CABLE TRAY WITHOUT DAMAGING OR DEFORMING THE CABLE.
- CONTRACTOR SHALL LABEL EACH CABLE AT 42 INCHES A.F.F. ON EACH FLOOR. REFER TO SECTION 27 15 00 COMMUNICATIONS STRUCTURED CABLING.
- CONTRACTOR SHALL INSTALL NEW J-HOOKS WHERE THERE IS NO CABLE TRAY OR COMMUNICATIONS CONDUIT UNLESS OTHERWISE NOTED.
- CONTRACTOR SHALL INSTALL NEW CATEGORY 6A PATCH PANELS IN THE TELECOMMUNICATION ROOM AS INDICATED ON RACK ELEVATIONS.
- CONTRACTOR SHALL RE-TERMINATE AND TEST CABLING REMOVED FROM ANY WALL MOUNT EQUIPMENT UNLESS OTHERWISE NOTED. TESTING SHALL BE PERFORMED BY THE CONTRACTOR DURING COMMISSIONING.
- CONTRACTOR SHALL INSTALL NEW CATEGORY 6A TELECOMMUNICATIONS DATA OUTLET AS INDICATED. EXISTING COMMUNICATION OUTLET BOXES AND CONDUITS TO BE REUSED.
- CONTRACTOR SHALL REPLACE ALL DATA CABLE WITH NEW CATEGORY 6A CABLE UNLESS OTHERWISE NOTED.
- CONTRACTOR SHALL TERMINATE COMMUNICATIONS CABLES WITH NEW CATEGORY MODULAR JACKS TO MATCH THE COMMUNICATION CABLE PERFORMANCE SPECIFICATIONS. NEW MODULAR JACKS SHALL BE OF THE SAME MANUFACTURER AS THE FACE PLATES, PATCH PANELS, AND PATCH CABLES.
- CONTRACTOR SHALL INSTALL NEW CATEGORY 6A CABLES AND CONNECTIVITY COMPONENTS THAT ARE OF THE SAME MANUFACTURER, INCLUDING CABLE, MODULAR JACKS, PATCH PANELS, FACEPLATES, AND PATCH CABLES.
- CONTRACTOR SHALL TEST ALL NEW AND EXISTING RE-TERMINATED CABLES IN ACCORDANCE WITH THE SPECIFICATION 27 08 00.

KEYED NOTES:

- EXISTING TELECOMMUNICATIONS ROOM.
- EXISTING CONDITIONS WERE NOT OBSERVED. DATA SHOWN IN ROOM IS AN ESTIMATE OF WHAT WILL BE REQUIRED.
- PROVIDE (4) 4" CONDUITS TO TR ON LEVEL BELOW.
- PROVIDE (4) 4" CONDUITS TO TR ON LEVEL ABOVE.



1 TECHNOLOGY FIFTH FLOOR PARTIAL PLAN - B
1/8" = 1'-0"

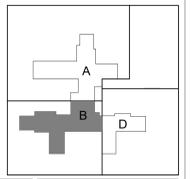

Description	Date

CONSULTANT
Ross & Baruzzini
LOW VOLTAGE/ IT
Ross & Baruzzini Inc.
1600 Riveredge Parkway NW
Suite 900
Atlanta, GA 30328

PROJECT MANAGEMENT
HFS
C O M P A N Y
8718 Botts Lane
San Antonio, Texas 78217
www.hfscorporation.com
jbianco@hfscorporation.com
Phone: (210) 816-4784
Fax: (210) 881-6808



Construction and Facilities Management
VA U.S. Department of Veterans Affairs

Drawing Title
TECHNOLOGY FIFTH FLOOR PARTIAL PLAN - B
Approved: Project Director

Phase
100% CONSTRUCTION DOCUMENTS
FULLY SPRINKLERED


 
Project Title
CINCINNATI VAMC EHRM INFRASTRUCTURE UPGRADES
Location
3200 VINE ST. CINCINNATI, OH. 45220
Issue Date:
04-MAY-2022
Scale:
1/8" = 1'-0"

Project Number
539-21-701
Building Number
C1
Drawing Number
TN-162-C.1.5

- GENERAL NOTES:**
- REFER TO SHEET T-000 FOR GENERAL NOTES AND LEGENDS.
 - ALL HORIZONTAL CABLING ON THIS FLOOR TO BE TERMINATED IN TRAYS.
 - CONTRACTOR SHALL INSTALL BACKBONE RISER SLEEVES OF THE SIZE AS INDICATED ON THE PLANS. REFER TO SECTION 27 15 00 COMMUNICATIONS STRUCTURED CABLING AND SECTION 27 05 33 RACEWAYS AND BOXES FOR COMMUNICATIONS SYSTEMS.
 - CONTRACTOR SHALL X-RAY CONCRETE FLOOR BEFORE CORE DRILLING. CONTRACTOR SHALL COORDINATE WITH THE COR BEFORE BEGINNING DRILLING.
 - CONTRACTOR SHALL FIRESTOP RISER SLEEVES AND EMPTY SPARE RISER SLEEVES. REFER TO SECTION 07 84 00 FIRESTOPPING.
 - CONTRACTOR SHALL INSTALL AN VERTICAL LADDER TYPE CABLE TRAY ON THE WALL ABOVE THE VERTICAL RISER SLEEVES FOR BACKBONE CABLE SUPPORT AS INDICATED ON THE PLANS. THE CABLE TRAY SHALL BE SECURELY ANCHORED TO THE WALL SUFFICIENT TO SUPPORT THE TOTAL WEIGHT OF CABLES AND CABLE TRAY PLUS 50%.
 - CONTRACTOR SHALL INSTALL CABLE SUPPORTS SUFFICIENT TO SUPPORT COMMUNICATIONS CABLES ON THE VERTICAL CABLE TRAY WITHOUT DAMAGING OR DEFORMING THE CABLE.
 - CONTRACTOR SHALL LABEL EACH CABLE AT 42 INCHES A.F.F. ON EACH FLOOR. REFER TO SECTION 27 15 00 COMMUNICATIONS STRUCTURED CABLING.
 - CONTRACTOR SHALL INSTALL NEW J-HOOKS WHERE THERE IS NO CABLE TRAY OR COMMUNICATIONS CONDUIT UNLESS OTHERWISE NOTED.
 - CONTRACTOR SHALL INSTALL NEW CATEGORY 6A PATCH PANELS IN THE TELECOMMUNICATION ROOM AS INDICATED ON RACK ELEVATIONS.
 - CONTRACTOR SHALL RE-TERMINATE AND TEST CABLING REMOVED FROM ANY WALL MOUNT EQUIPMENT UNLESS OTHERWISE NOTED. TESTING SHALL BE PERFORMED BY THE CONTRACTOR DURING COMMISSIONING.
 - CONTRACTOR SHALL INSTALL NEW CATEGORY 6A TELECOMMUNICATIONS/DATA OUTLET AS INDICATED. EXISTING COMMUNICATION OUTLET BOXES AND CONDUITS TO BE REUSED.
 - CONTRACTOR SHALL REPLACE ALL DATA CABLE WITH NEW CATEGORY 6A CABLE UNLESS OTHERWISE NOTED.
 - CONTRACTOR SHALL TERMINATE COMMUNICATIONS CABLES WITH NEW CATEGORY MODULAR JACKS TO MATCH THE COMMUNICATION CABLE PERFORMANCE SPECIFICATIONS. NEW MODULAR JACKS SHALL BE OF THE SAME MANUFACTURER AS THE FACE PLATES, PATCH PANELS, AND PATCH CABLES.
 - CONTRACTOR SHALL INSTALL NEW CATEGORY 6A CABLES AND CONNECTIVITY COMPONENTS THAT ARE OF THE SAME MANUFACTURER, INCLUDING CABLE, MODULAR JACKS, PATCH PANELS, FACEPLATES, AND PATCH CABLES.
 - CONTRACTOR SHALL TEST ALL NEW AND EXISTING RE-TERMINATED CABLES IN ACCORDANCE WITH THE SPECIFICATION 27 08 00.

- KEYED NOTES:**
- EXISTING TELECOMMUNICATIONS ROOM.
 - EXISTING CONDITIONS WERE NOT OBSERVED. DATA SHOWN IN ROOM IS AN ESTIMATE OF WHAT WILL BE REQUIRED.

① TECHNOLOGY FIFTH FLOOR PARTIAL PLAN - D
1/8" = 1'-0"

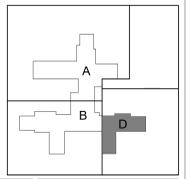

Description	Date

CONSULTANT
Ross & Baruzzini
LOW VOLTAGE/ IT
Ross & Baruzzini Inc.
1600 Riveredge Parkway NW
Suite 900
Atlanta, GA 30328

PROJECT MANAGEMENT
HFS
C O M P A N Y
8718 Botts Lane
San Antonio, Texas 78217
www.hfscmpany.com
Phone: (210) 816-4784
Fax: (210) 881-6808
jbianco@hfscmpany.com



Construction and Facilities Management
VA U.S. Department of Veterans Affairs

Drawing Title
TECHNOLOGY FIFTH FLOOR PARTIAL PLAN - D
Approved: Project Director

Phase
100% CONSTRUCTION DOCUMENTS
FULLY SPRINKLERED

Project Title
CINCINNATI VAMC EHRM INFRASTRUCTURE UPGRADES
Location
3200 VINE ST. CINCINNATI, OH. 45220
Issue Date
04-MAY-2022
Scale
1/8" = 1'-0"


Project Number
539-21-701
Building Number
C1
Drawing Number
TN-163-C.1.5

GENERAL NOTES:



- REFER TO SHEET T-000 FOR GENERAL NOTES AND LEGENDS.
- ALL HORIZONTAL CABLING ON THIS FLOOR TO BE TERMINATED IN TR-6.
- CONTRACTOR SHALL INSTALL BACKBONE RISER SLEEVES OF THE SIZE AS INDICATED ON THE PLANS. REFER TO SECTION 27 15 00 COMMUNICATIONS STRUCTURED CABLING AND SECTION 27 05 33 RACEWAYS AND BOXES FOR COMMUNICATIONS SYSTEMS.
- CONTRACTOR SHALL X-RAY CONCRETE FLOOR BEFORE CORE DRILLING. CONTRACTOR SHALL COORDINATE WITH THE COR BEFORE BEGINNING DRILLING.
- CONTRACTOR SHALL FIRESTOP RISER SLEEVES AND EMPTY SPARE RISER SLEEVES. REFER TO SECTION 07 64 00 FIRESTOPPING.
- CONTRACTOR SHALL INSTALL A VERTICAL LADDER TYPE CABLE TRAY ON THE WALL ABOVE THE VERTICAL RISER SLEEVES FOR BACKBONE CABLE SUPPORT AS INDICATED ON THE PLANS. THE CABLE TRAY SHALL BE SECURELY ANCHORED TO THE WALL SUFFICIENT TO SUPPORT THE TOTAL WEIGHT OF CABLES AND CABLE TRAY PLUS 50%.
- CONTRACTOR SHALL INSTALL CABLE SUPPORTS SUFFICIENT TO SUPPORT COMMUNICATIONS CABLES ON THE VERTICAL CABLE TRAY WITHOUT DAMAGING OR DEFORMING THE CABLE.
- CONTRACTOR SHALL LABEL EACH CABLE AT 42 INCHES A.F.F. ON EACH FLOOR. REFER TO SECTION 27 15 00 COMMUNICATIONS STRUCTURED CABLING.
- CONTRACTOR SHALL INSTALL NEW J-HOOKS WHERE THERE IS NO CABLE TRAY OR COMMUNICATIONS CONDUIT UNLESS OTHERWISE NOTED.
- CONTRACTOR SHALL INSTALL NEW CATEGORY 6A PATCH PANELS IN THE TELECOMMUNICATION ROOM AS INDICATED ON RACK ELEVATIONS.
- CONTRACTOR SHALL RE-TERMINATE AND TEST CABLING REMOVED FROM ANY WALL MOUNT EQUIPMENT UNLESS OTHERWISE NOTED. TESTING SHALL BE PERFORMED BY THE CONTRACTOR DURING COMMISSIONING.
- CONTRACTOR SHALL INSTALL NEW CATEGORY 6A TELECOMMUNICATIONS/DATA OUTLET AS INDICATED. EXISTING COMMUNICATION OUTLET BOXES AND CONDUITS TO BE REUSED.
- CONTRACTOR SHALL REPLACE ALL DATA CABLE WITH NEW CATEGORY 6A CABLE UNLESS OTHERWISE NOTED.
- CONTRACTOR SHALL TERMINATE COMMUNICATIONS CABLES WITH NEW CATEGORY MODULAR JACKS TO MATCH THE COMMUNICATION CABLE PERFORMANCE SPECIFICATIONS. NEW MODULAR JACKS SHALL BE OF THE SAME MANUFACTURER AS THE FACE PLATES, PATCH PANELS, AND PATCH CABLES.
- CONTRACTOR SHALL INSTALL NEW CATEGORY 6A CABLES AND CONNECTIVITY COMPONENTS THAT ARE OF THE SAME MANUFACTURER, INCLUDING CABLE, MODULAR JACKS, PATCH PANELS, FACEPLATES, AND PATCH CABLES.
- CONTRACTOR SHALL TEST ALL NEW AND EXISTING RE-TERMINATED CABLES IN ACCORDANCE WITH THE SPECIFICATION 27 08 00.

KEYED NOTES:

- EXISTING TELECOMMUNICATIONS ROOM.
- PROVIDE (4) 4" CONDUITS TO TR ON LEVEL BELOW.
- PROVIDE (4) 4" CONDUITS TO TR ON LEVEL ABOVE.
- 12 INCH X 4 INCH WIRE MESH CABLE TRAY

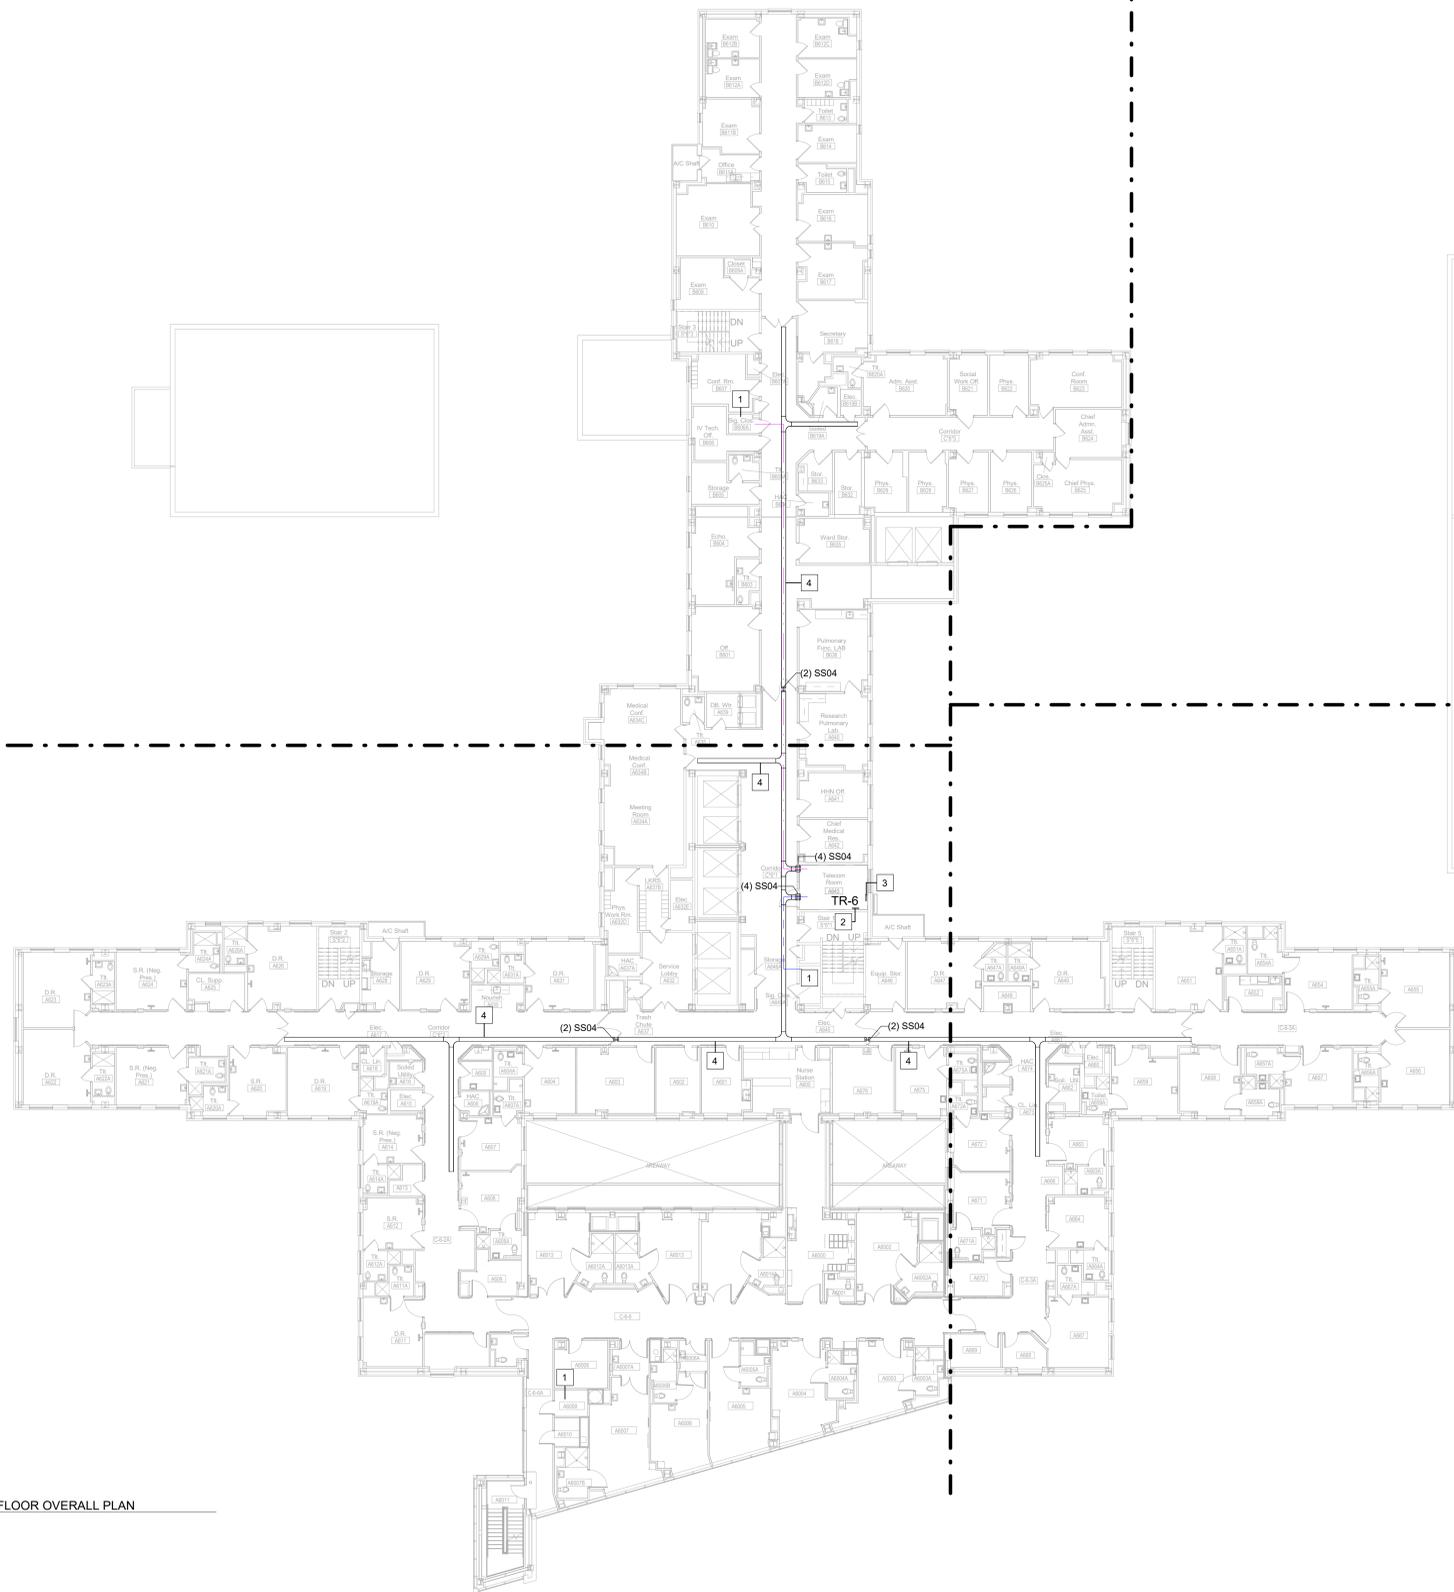

 1 TECHNOLOGY SIXTH FLOOR OVERALL PLAN
1/16" = 1'-0"

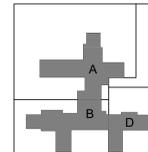

Description	Date

CONSULTANT
Ross & Baruzzini
LOW VOLTAGE/ IT
Ross & Baruzzini Inc.
1600 Riveredge Parkway NW
Suite 900
Atlanta, GA 30328

PROJECT MANAGEMENT
HFS
C O M P A N Y
8718 Botts Lane
San Antonio, Texas 78217
www.hfscorporation.com
Phone: (210) 816-4784
Fax: (210) 881-8808
jbianco@hfscorporation.com



Construction and Facilities Management
VA U.S. Department of Veterans Affairs

Drawing Title
TECHNOLOGY SIXTH FLOOR OVERALL PLAN
Approved: Project Director

Phase
100% CONSTRUCTION DOCUMENTS
FULLY SPRINKLERED

Project Title
CINCINNATI VAMC EHRM INFRASTRUCTURE UPGRADES
Location
3200 VINE ST. CINCINNATI, OH. 45220
Issue Date
04-MAY-2022
Scale
1/16" = 1'-0"


Project Number
539-21-701
Building Number
C1
Drawing Number
TN-170-C.1.6

GENERAL NOTES:



1. REFER TO SHEET T-000 FOR GENERAL NOTES AND LEGENDS.
2. ALL HORIZONTAL CABLING ON THIS FLOOR TO BE TERMINATED IN TR-6.
3. CONTRACTOR SHALL INSTALL BACKBONE RISER SLEEVES OF THE SIZE AS INDICATED ON THE PLANS. REFER TO SECTION 27 15 00 COMMUNICATIONS STRUCTURED CABLING AND SECTION 27 05 33 RACEWAYS AND BOXES FOR COMMUNICATIONS SYSTEMS.
4. CONTRACTOR SHALL X-RAY CONCRETE FLOOR BEFORE CORE DRILLING. CONTRACTOR SHALL COORDINATE WITH THE COR BEFORE BEGINNING DRILLING.
5. CONTRACTOR SHALL FIRESTOP RISER SLEEVES AND EMPTY SPARE RISER SLEEVES. REFER TO SECTION 07 84 00 FIRESTOPPING.
6. CONTRACTOR SHALL INSTALL A VERTICAL LADDER TYPE CABLE TRAY ON THE WALL ABOVE THE VERTICAL RISER SLEEVES FOR BACKBONE CABLE SUPPORT AS INDICATED ON THE PLANS. THE CABLE TRAY SHALL BE SECURELY ANCHORED TO THE WALL SUFFICIENT TO SUPPORT THE TOTAL WEIGHT OF CABLES AND CABLE TRAY PLUS 50%.
7. CONTRACTOR SHALL INSTALL CABLE SUPPORTS SUFFICIENT TO SUPPORT COMMUNICATIONS CABLES ON THE VERTICAL CABLE TRAY WITHOUT DAMAGING OR DEFORMING THE CABLE.
8. CONTRACTOR SHALL LABEL EACH CABLE AT 42 INCHES A.F.F. ON EACH FLOOR. REFER TO SECTION 27 15 00 COMMUNICATIONS STRUCTURED CABLING.
9. CONTRACTOR SHALL INSTALL NEW J-HOOKS WHERE THERE IS NO CABLE TRAY OR COMMUNICATIONS CONDUIT UNLESS OTHERWISE NOTED.
10. CONTRACTOR SHALL INSTALL NEW CATEGORY 6A PATCH PANELS IN THE TELECOMMUNICATION ROOM AS INDICATED ON RACK ELEVATIONS.
11. CONTRACTOR SHALL RE-TERMINATE AND TEST CABLING REMOVED FROM ANY WALL MOUNT EQUIPMENT UNLESS OTHERWISE NOTED. TESTING SHALL BE PERFORMED BY THE CONTRACTOR DURING COMMISSIONING.
12. CONTRACTOR SHALL INSTALL NEW CATEGORY 6A TELECOMMUNICATIONS/DATA OUTLET AS INDICATED. EXISTING COMMUNICATION OUTLET BOXES AND CONDUITS TO BE REUSED.
13. CONTRACTOR SHALL REPLACE ALL DATA CABLE WITH NEW CATEGORY 6A CABLE UNLESS OTHERWISE NOTED.
14. CONTRACTOR SHALL TERMINATE COMMUNICATIONS CABLES WITH NEW CATEGORY MODULAR JACKS TO MATCH THE COMMUNICATION CABLE PERFORMANCE SPECIFICATIONS. NEW MODULAR JACKS SHALL BE OF THE SAME MANUFACTURER AS THE FACE PLATES, PATCH PANELS, AND PATCH CABLES.
15. CONTRACTOR SHALL INSTALL NEW CATEGORY 6A CABLES AND CONNECTIVITY COMPONENTS THAT ARE OF THE SAME MANUFACTURER, INCLUDING CABLE, MODULAR JACKS, PATCH PANELS, FACEPLATES, AND PATCH CABLES.
16. CONTRACTOR SHALL TEST ALL NEW AND EXISTING RE-TERMINATED CABLES IN ACCORDANCE WITH THE SPECIFICATION 27 08 00.

KEYED NOTES:

1. EXISTING TELECOMMUNICATIONS ROOM.
2. EXISTING CONDITIONS WERE NOT OBSERVED. DATA SHOWN IN ROOM IS AN ESTIMATE OF WHAT WILL BE REQUIRED.

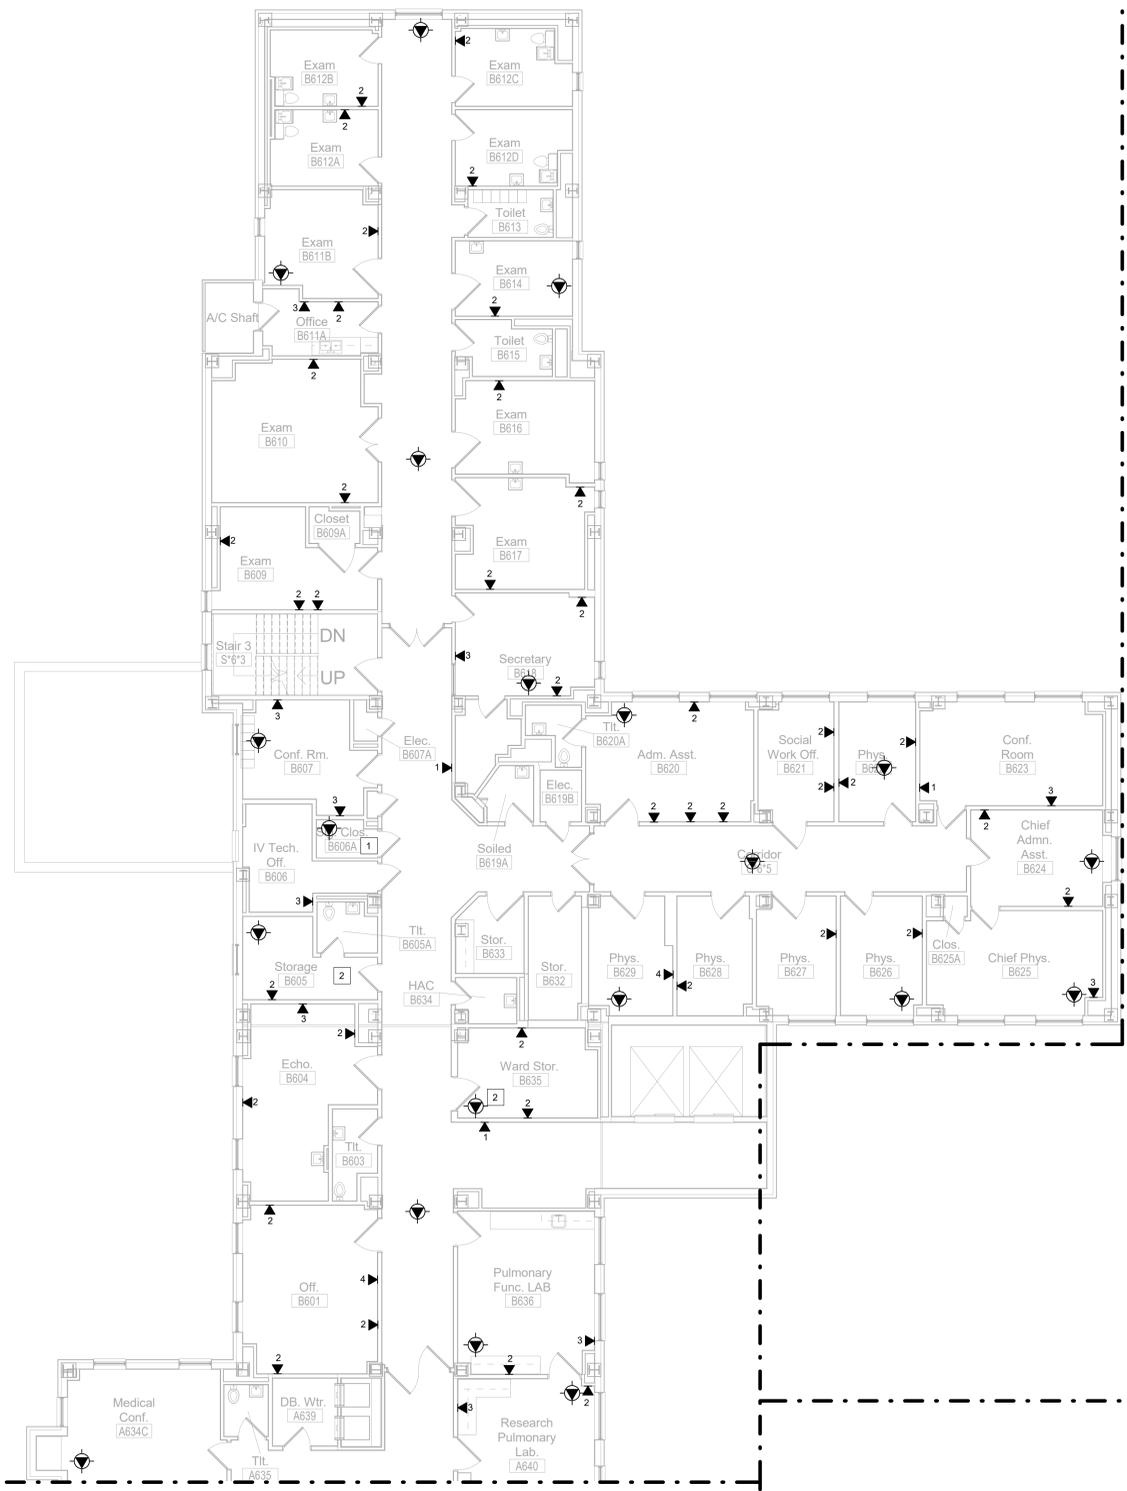

 1 TECHNOLOGY SIXTH FLOOR PARTIAL PLAN - A
1/8" = 1'-0"

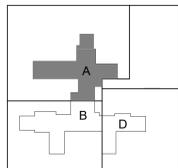

Description	Date

CONSULTANT
Ross & Baruzzini
LOW VOLTAGE/ IT
Ross & Baruzzini Inc.
1600 Riveredge Parkway NW
Suite 900
Atlanta, GA 30328

PROJECT MANAGEMENT
HFS
C O M P A N Y
8718 Botts Lane
San Antonio, Texas 78217
www.hfscorporation.com
Phone: (210) 816-4784
Fax: (210) 881-6808
jbianco@hfscorporation.com



Construction and Facilities Management
VA U.S. Department of Veterans Affairs

Drawing Title
TECHNOLOGY SIXTH FLOOR PARTIAL PLAN - A
Approved: Project Director

Phase
100% CONSTRUCTION DOCUMENTS
FULLY SPRINKLERED

Project Title
CINCINNATI VAMC EHRM INFRASTRUCTURE UPGRADES
Location
3200 VINE ST. CINCINNATI, OH. 45220
Issue Date
04-MAY-2022
Scale
1/8" = 1'-0"


Project Number
539-21-701
Building Number
C1
Drawing Number
TN-171-C.1.6

GENERAL NOTES:



- REFER TO SHEET T-000 FOR GENERAL NOTES AND LEGENDS.
- ALL HORIZONTAL CABLING ON THIS FLOOR TO BE TERMINATED IN TR 7.
- CONTRACTOR SHALL INSTALL BACKBONE RISER SLEEVES OF THE SIZE AS INDICATED ON THE PLANS. REFER TO SECTION 27 15 00 COMMUNICATIONS STRUCTURED CABLING AND SECTION 27 05 33 RACEWAYS AND BOXES FOR COMMUNICATIONS SYSTEMS.
- CONTRACTOR SHALL X-RAY CONCRETE FLOOR BEFORE CORE DRILLING. CONTRACTOR SHALL COORDINATE WITH THE COR BEFORE BEGINNING DRILLING.
- CONTRACTOR SHALL FIRESTOP RISER SLEEVES AND EMPTY SPARE RISER SLEEVES. REFER TO SECTION 07 84 00 FIRESTOPPING.
- CONTRACTOR SHALL INSTALL A VERTICAL LADDER TYPE CABLE TRAY ON THE WALL ABOVE THE VERTICAL RISER SLEEVES FOR BACKBONE CABLE SUPPORT AS INDICATED ON THE PLANS. THE CABLE TRAY SHALL BE SECURELY ANCHORED TO THE WALL SUFFICIENT TO SUPPORT THE TOTAL WEIGHT OF CABLES AND CABLE TRAY PLUS 50%.
- CONTRACTOR SHALL INSTALL CABLE SUPPORTS SUFFICIENT TO SUPPORT COMMUNICATIONS CABLES ON THE VERTICAL CABLE TRAY WITHOUT DAMAGING OR DEFORMING THE CABLE.
- CONTRACTOR SHALL LABEL EACH CABLE AT 42 INCHES A.F.F. ON EACH FLOOR. REFER TO SECTION 27 15 00 COMMUNICATIONS STRUCTURED CABLING.
- CONTRACTOR SHALL INSTALL NEW J-HOOKS WHERE THERE IS NO CABLE TRAY OR COMMUNICATIONS CONDUIT UNLESS OTHERWISE NOTED.
- CONTRACTOR SHALL INSTALL NEW CATEGORY 6A PATCH PANELS IN THE TELECOMMUNICATION ROOM AS INDICATED ON RACK ELEVATIONS.
- CONTRACTOR SHALL RE-TERMINATE AND TEST CABLING REMOVED FROM ANY WALL MOUNT EQUIPMENT UNLESS OTHERWISE NOTED. TESTING SHALL BE PERFORMED BY THE CONTRACTOR DURING COMMISSIONING.
- CONTRACTOR SHALL INSTALL NEW CATEGORY 6A TELECOMMUNICATIONS/DATA OUTLET AS INDICATED. EXISTING COMMUNICATION OUTLET BOXES AND CONDUITS TO BE REUSED.
- CONTRACTOR SHALL REPLACE ALL DATA CABLE WITH NEW CATEGORY 6A CABLE UNLESS OTHERWISE NOTED.
- CONTRACTOR SHALL TERMINATE COMMUNICATIONS CABLES WITH NEW CATEGORY MODULAR JACKS TO MATCH THE COMMUNICATION CABLE PERFORMANCE SPECIFICATIONS. NEW MODULAR JACKS SHALL BE OF THE SAME MANUFACTURER AS THE FACE PLATES, PATCH PANELS, AND PATCH CABLES.
- CONTRACTOR SHALL INSTALL NEW CATEGORY 6A CABLES AND CONNECTIVITY COMPONENTS THAT ARE OF THE SAME MANUFACTURER, INCLUDING CABLE, MODULAR JACKS, PATCH PANELS, FACEPLATES, AND PATCH CABLES.
- CONTRACTOR SHALL TEST ALL NEW AND EXISTING RE-TERMINATED CABLES IN ACCORDANCE WITH THE SPECIFICATION 27 08 00.

KEYED NOTES:

- EXISTING TELECOMMUNICATIONS ROOM.
- PROVIDE (4) 4" CONDUITS TO TR ON LEVEL BELOW.
- PROVIDE (4) 4" CONDUITS TO TR ON LEVEL ABOVE.
- 12 INCH X 4 INCH WIRE MESH CABLE TRAY

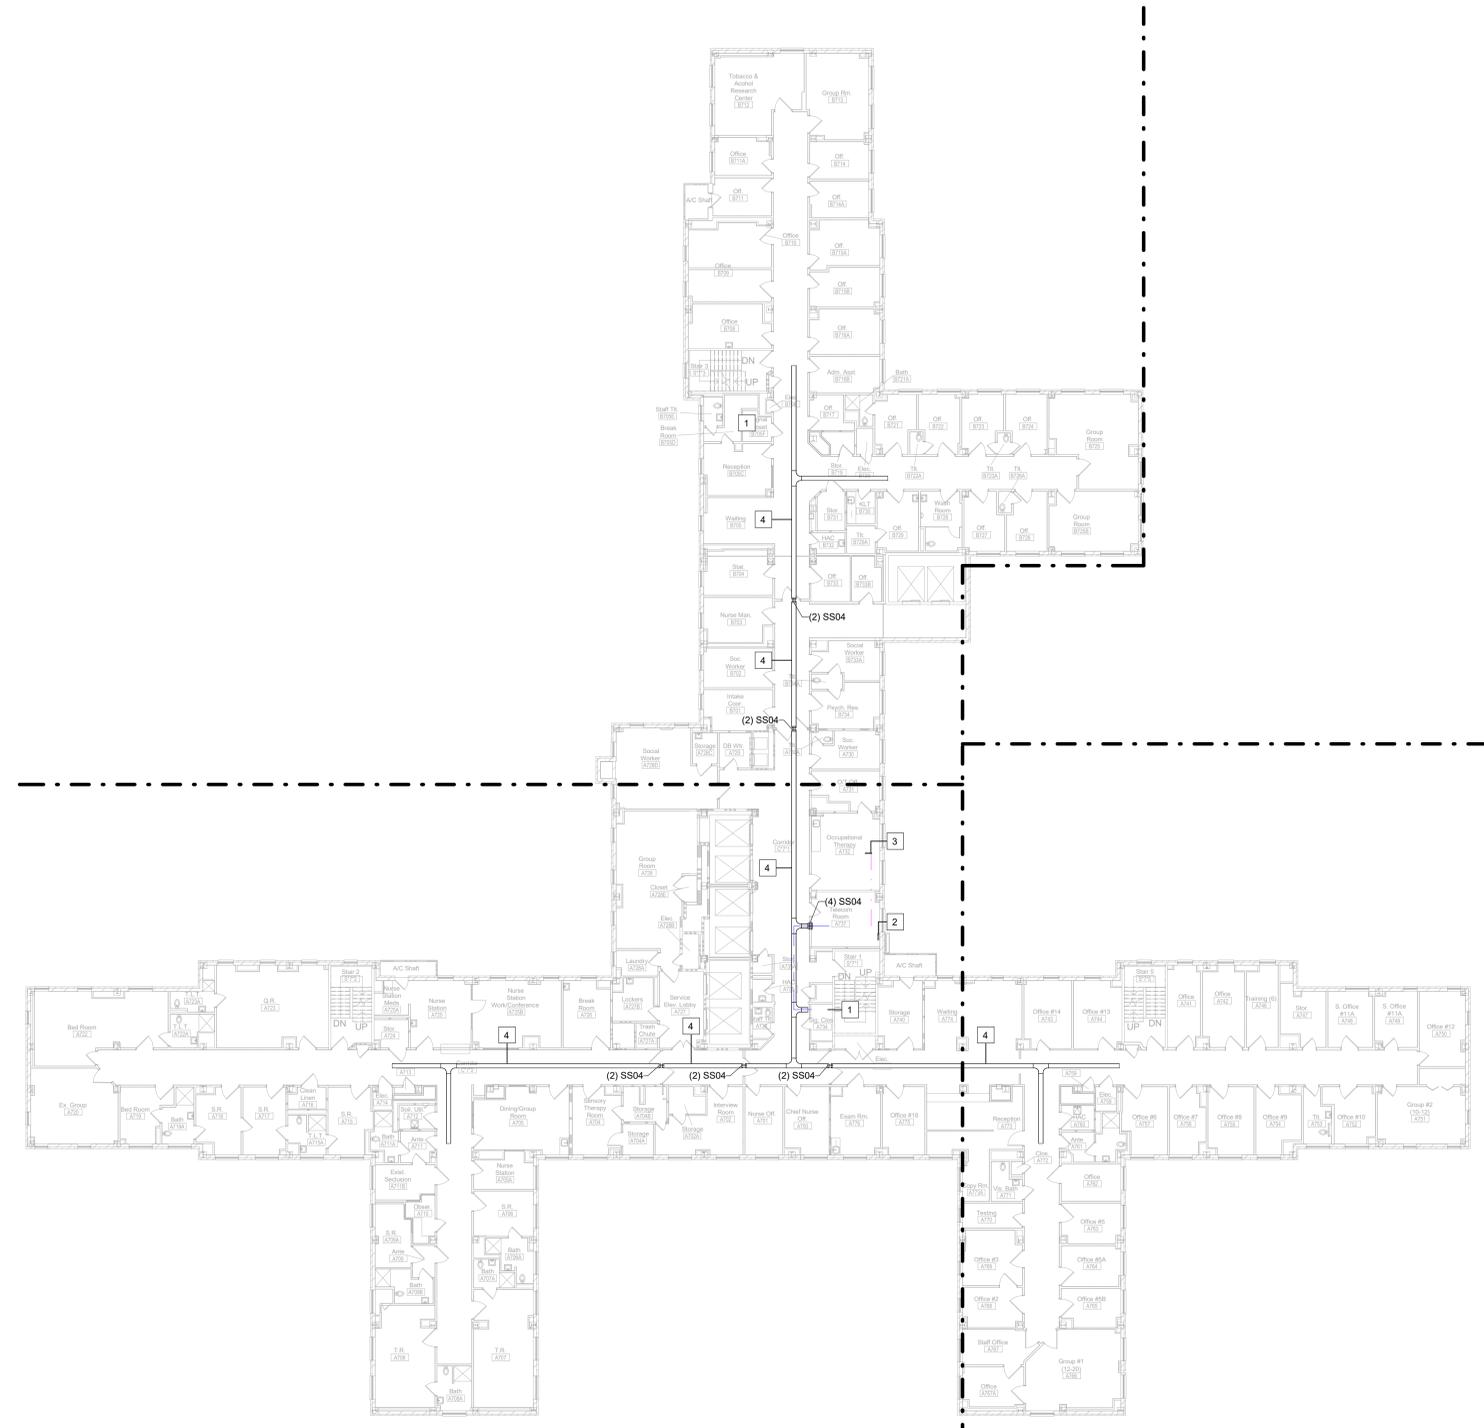

 1 TECHNOLOGY SEVENTH FLOOR OVERALL PLAN
1/16" = 1'-0"

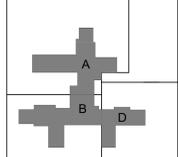


ADDENDUM 1 Description Date 4/29/2022	CONSULTANT Ross & Baruzzini LOW VOLTAGE/ IT Ross & Baruzzini Inc. 1600 Riveredge Parkway NW Suite 900 Atlanta, GA 30328	PROJECT MANAGEMENT HFS COMPANY 8718 Botts Lane San Antonio, Texas 78217 www.hfscorporation.com Phone: (210) 816-4784 Fax: (210) 881-6808 jbianco@hfscorporation.com		Construction and Facilities Management 	Drawing Title TECHNOLOGY SEVENTH FLOOR OVERALL PLAN Approved: Project Director	Phase 100% CONSTRUCTION DOCUMENTS FULLY SPRINKLERED	Project Title CINCINNATI VAMC EHRM INFRASTRUCTURE UPGRADES Location 3200 VINE ST. CINCINNATI, OH. 45220 Issue Date: 04-MAY-2022 Scale: 1/16" = 1'-0"	Project Number 539-21-701 Building Number C1 Drawing Number TN-180-C.1.7
	Checked By: PR Drawn By: TL							

GENERAL NOTES:



1. REFER TO SHEET T-000 FOR GENERAL NOTES AND LEGENDS.
2. ALL HORIZONTAL CABLING ON THIS FLOOR TO BE TERMINATED IN TR-7.
3. CONTRACTOR SHALL INSTALL BACKBONE RISER SLEEVES OF THE SIZE AS INDICATED ON THE PLANS. REFER TO SECTION 27 15 00 COMMUNICATIONS STRUCTURED CABLING AND SECTION 27 05 33 RACEWAYS AND BOXES FOR COMMUNICATIONS SYSTEMS.
4. CONTRACTOR SHALL X-RAY CONCRETE FLOOR BEFORE CORE DRILLING. CONTRACTOR SHALL COORDINATE WITH THE COR BEFORE BEGINNING DRILLING.
5. CONTRACTOR SHALL FIRESTOP RISER SLEEVES AND EMPTY SPARE RISER SLEEVES. REFER TO SECTION 07 84 00 FIRESTOPPING.
6. CONTRACTOR SHALL INSTALL AN VERTICAL LADDER TYPE CABLE TRAY ON THE WALL ABOVE THE VERTICAL RISER SLEEVES FOR BACKBONE CABLE SUPPORT AS INDICATED ON THE PLANS. THE CABLE TRAY SHALL BE SECURELY ANCHORED TO THE WALL SUFFICIENT TO SUPPORT THE TOTAL WEIGHT OF CABLES AND CABLE TRAY PLUS 50%.
7. CONTRACTOR SHALL INSTALL CABLE SUPPORTS SUFFICIENT TO SUPPORT COMMUNICATIONS CABLES ON THE VERTICAL CABLE TRAY WITHOUT DAMAGING OR DEFORMING THE CABLE.
8. CONTRACTOR SHALL LABEL EACH CABLE AT 42 INCHES A.F.F. ON EACH FLOOR. REFER TO SECTION 27 15 00 COMMUNICATIONS STRUCTURED CABLING.
9. CONTRACTOR SHALL INSTALL NEW J-HOOKS WHERE THERE IS NO CABLE TRAY OR COMMUNICATIONS CONDUIT UNLESS OTHERWISE NOTED.
10. CONTRACTOR SHALL INSTALL NEW CATEGORY 6A PATCH PANELS IN THE TELECOMMUNICATION ROOM AS INDICATED ON RACK ELEVATIONS.
11. CONTRACTOR SHALL RE-TERMINATE AND TEST CABLING REMOVED FROM ANY WALL MOUNT EQUIPMENT UNLESS OTHERWISE NOTED. TESTING SHALL BE PERFORMED BY THE CONTRACTOR DURING COMMISSIONING.
12. CONTRACTOR SHALL INSTALL NEW CATEGORY 6A TELECOMMUNICATIONS/DATA OUTLET AS INDICATED. EXISTING COMMUNICATION OUTLET BOXES AND CONDUITS TO BE REUSED.
13. CONTRACTOR SHALL REPLACE ALL DATA CABLE WITH NEW CATEGORY 6A CABLE UNLESS OTHERWISE NOTED.
14. CONTRACTOR SHALL TERMINATE COMMUNICATIONS CABLES WITH NEW CATEGORY MODULAR JACKS TO MATCH THE COMMUNICATION CABLE PERFORMANCE SPECIFICATIONS. NEW MODULAR JACKS SHALL BE OF THE SAME MANUFACTURER AS THE FACE PLATES, PATCH PANELS, AND PATCH CABLES.
15. CONTRACTOR SHALL INSTALL NEW CATEGORY 6A CABLES AND CONNECTIVITY COMPONENTS THAT ARE OF THE SAME MANUFACTURER, INCLUDING CABLE, MODULAR JACKS, PATCH PANELS, FACEPLATES, AND PATCH CABLES.
16. CONTRACTOR SHALL TEST ALL NEW AND EXISTING RE-TERMINATED CABLES IN ACCORDANCE WITH THE SPECIFICATION 27 08 00.

KEYED NOTES:

1. EXISTING TELECOMMUNICATIONS ROOM.
2. EXISTING CONDITIONS WERE NOT OBSERVED. DATA SHOWN IN ROOM IS AN ESTIMATE OF WHAT WILL BE REQUIRED.

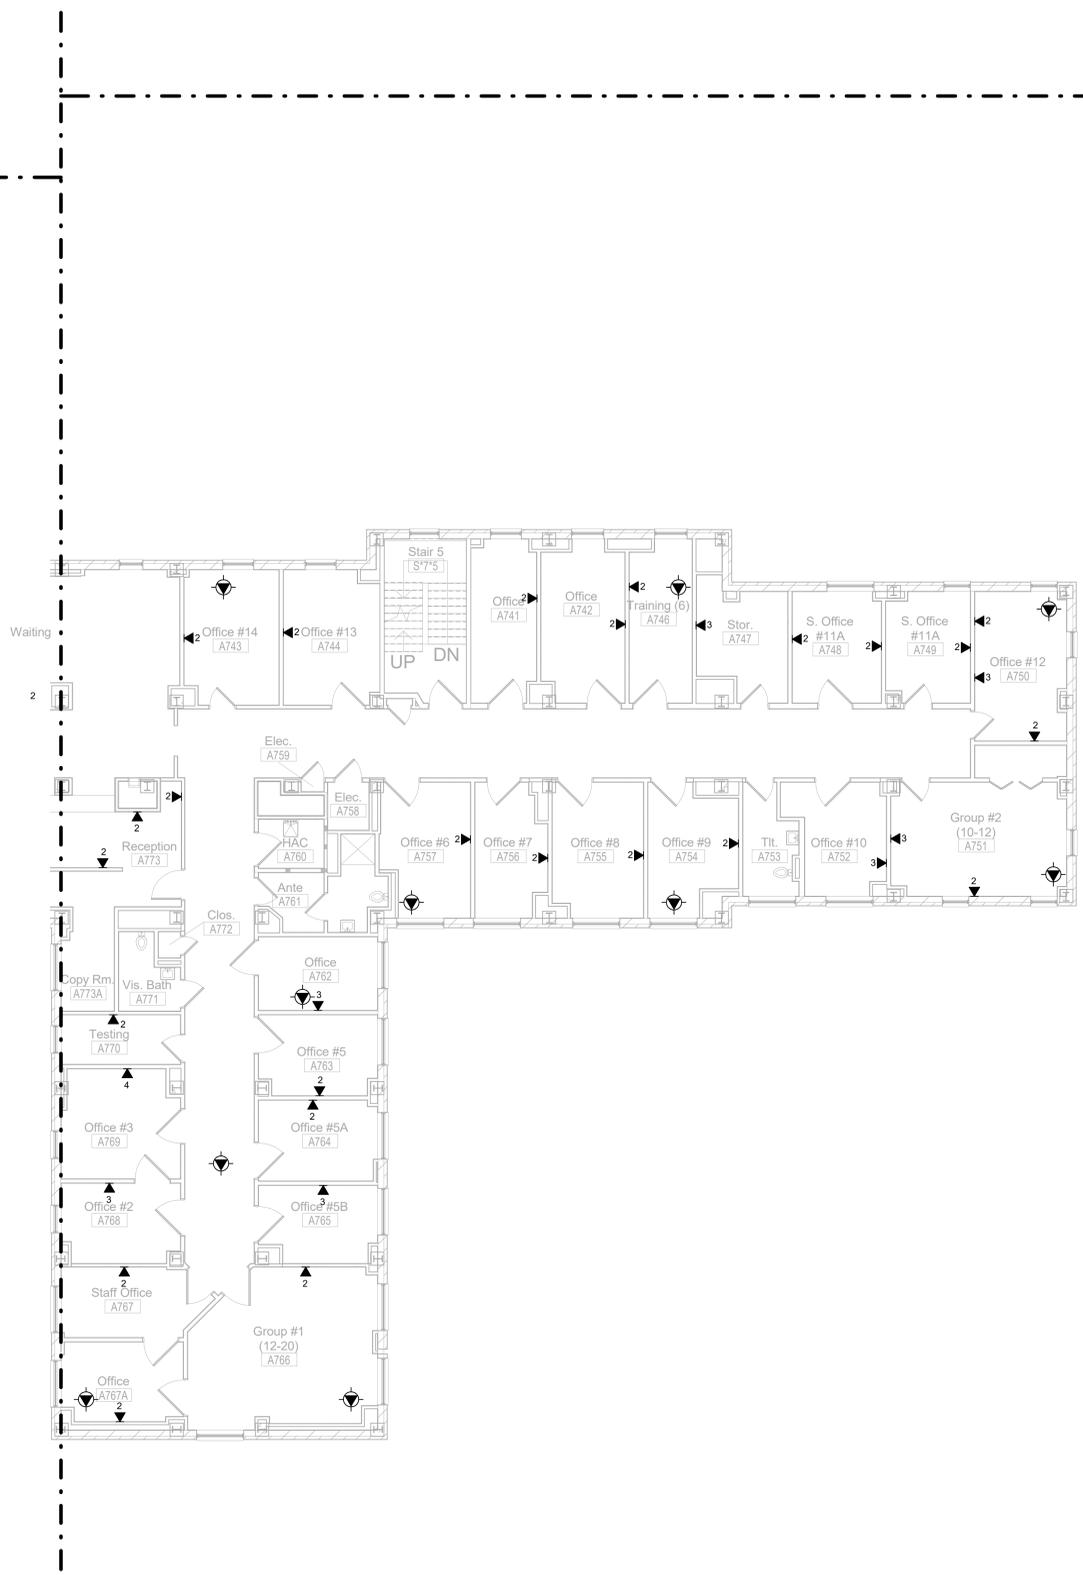

 1 TECHNOLOGY SEVENTH FLOOR PARTIAL PLAN - D
1/8" = 1'-0"

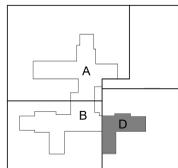


Description	Date	CONSULTANT Ross & Baruzzini LOW VOLTAGE/ IT Ross & Baruzzini Inc. 1600 Riveredge Parkway NW Suite 900 Atlanta, GA 30328	PROJECT MANAGEMENT HFS COMPANY 8718 Botts Lane San Antonio, Texas 78217 Phone: (210) 816-4784 Fax: (210) 881-6808 www.hfscmpany.com jbianco@hfscmpany.com	 BICSI ID # 124734 Expires 12-31-25 RCDD	Construction and Facilities Management VA U.S. Department of Veterans Affairs	Drawing Title	Phase	Project Title	Project Number		
						TECHNOLOGY SEVENTH FLOOR PARTIAL PLAN - D	100% CONSTRUCTION DOCUMENTS	CINCINNATI VAMC EHRM INFRASTRUCTURE UPGRADES	539-21-701		
Approved: Project Director						Fully Sprinklered	Location	Issue Date	Checked By	Drawn By	Drawing Number
						FULLY SPRINKLERED	3200 VINE ST. CINCINNATI, OH. 45220	04-MAY-2022	PR	TL	TN-183-C.1.7
							Scale: 1/8" = 1'-0"				

GENERAL NOTES:



1. REFER TO SHEET T-000 FOR GENERAL NOTES AND LEGENDS.
2. ALL HORIZONTAL CABLING ON THIS FLOOR TO BE TERMINATED IN TRS.
3. CONTRACTOR SHALL INSTALL BACKBONE RISER SLEEVES OF THE SIZE AS INDICATED ON THE PLANS. REFER TO SECTION 27 15 00 COMMUNICATIONS STRUCTURED CABLING AND SECTION 27 05 33 RACEWAYS AND BOXES FOR COMMUNICATIONS SYSTEMS.
4. CONTRACTOR SHALL X-RAY CONCRETE FLOOR BEFORE CORE DRILLING. CONTRACTOR SHALL COORDINATE WITH THE COR BEFORE BEGINNING DRILLING.
5. CONTRACTOR SHALL FIRESTOP RISER SLEEVES AND EMPTY SPARE RISER SLEEVES. REFER TO SECTION 07 84 00 FIRESTOPPING.
6. CONTRACTOR SHALL INSTALL A VERTICAL LADDER TYPE CABLE TRAY ON THE WALL ABOVE THE VERTICAL RISER SLEEVES FOR BACKBONE CABLE SUPPORT AS INDICATED ON THE PLANS. THE CABLE TRAY SHALL BE SECURELY ANCHORED TO THE WALL SUFFICIENT TO SUPPORT THE TOTAL WEIGHT OF CABLES AND CABLE TRAY PLUS 50%.
7. CONTRACTOR SHALL INSTALL CABLE SUPPORTS SUFFICIENT TO SUPPORT COMMUNICATIONS CABLES ON THE VERTICAL CABLE TRAY WITHOUT DAMAGING OR DEFORMING THE CABLE.
8. CONTRACTOR SHALL LABEL EACH CABLE AT 42 INCHES A.F.F. ON EACH FLOOR. REFER TO SECTION 27 15 00 COMMUNICATIONS STRUCTURED CABLING.
9. CONTRACTOR SHALL INSTALL NEW J-HOOKS WHERE THERE IS NO CABLE TRAY OR COMMUNICATIONS CONDUIT UNLESS OTHERWISE NOTED.
10. CONTRACTOR SHALL INSTALL NEW CATEGORY 6A PATCH PANELS IN THE TELECOMMUNICATION ROOM AS INDICATED ON RACK ELEVATIONS.
11. CONTRACTOR SHALL RE-TERMINATE AND TEST CABLING REMOVED FROM ANY WALL MOUNT EQUIPMENT UNLESS OTHERWISE NOTED. TESTING SHALL BE PERFORMED BY THE CONTRACTOR DURING COMMISSIONING.
12. CONTRACTOR SHALL INSTALL NEW CATEGORY 6A TELECOMMUNICATIONS/DATA OUTLET AS INDICATED. EXISTING COMMUNICATION OUTLET BOXES AND CONDUITS TO BE REUSED.
13. CONTRACTOR SHALL REPLACE ALL DATA CABLE WITH NEW CATEGORY 6A CABLE UNLESS OTHERWISE NOTED.
14. CONTRACTOR SHALL TERMINATE COMMUNICATIONS CABLES WITH NEW CATEGORY MODULAR JACKS TO MATCH THE COMMUNICATION CABLE PERFORMANCE SPECIFICATIONS. NEW MODULAR JACKS SHALL BE OF THE SAME MANUFACTURER AS THE FACE PLATES, PATCH PANELS, AND PATCH CABLES.
15. CONTRACTOR SHALL INSTALL NEW CATEGORY 6A CABLES AND CONNECTIVITY COMPONENTS THAT ARE OF THE SAME MANUFACTURER, INCLUDING CABLE, MODULAR JACKS, PATCH PANELS, FACEPLATES, AND PATCH CABLES.
16. CONTRACTOR SHALL TEST ALL NEW AND EXISTING RE-TERMINATED CABLES IN ACCORDANCE WITH THE SPECIFICATION RE-27 08 00.

KEYED NOTES:

1. EXISTING TELECOMMUNICATIONS ROOM.
2. PROVIDE (4) 4" CONDUITS TO TR ON LEVEL ABOVE.
3. PROVIDE (4) 4" CONDUITS TO TR ON LEVEL BELOW.
4. 12 INCH X 4 INCH WIRE MESH CABLE TRAY

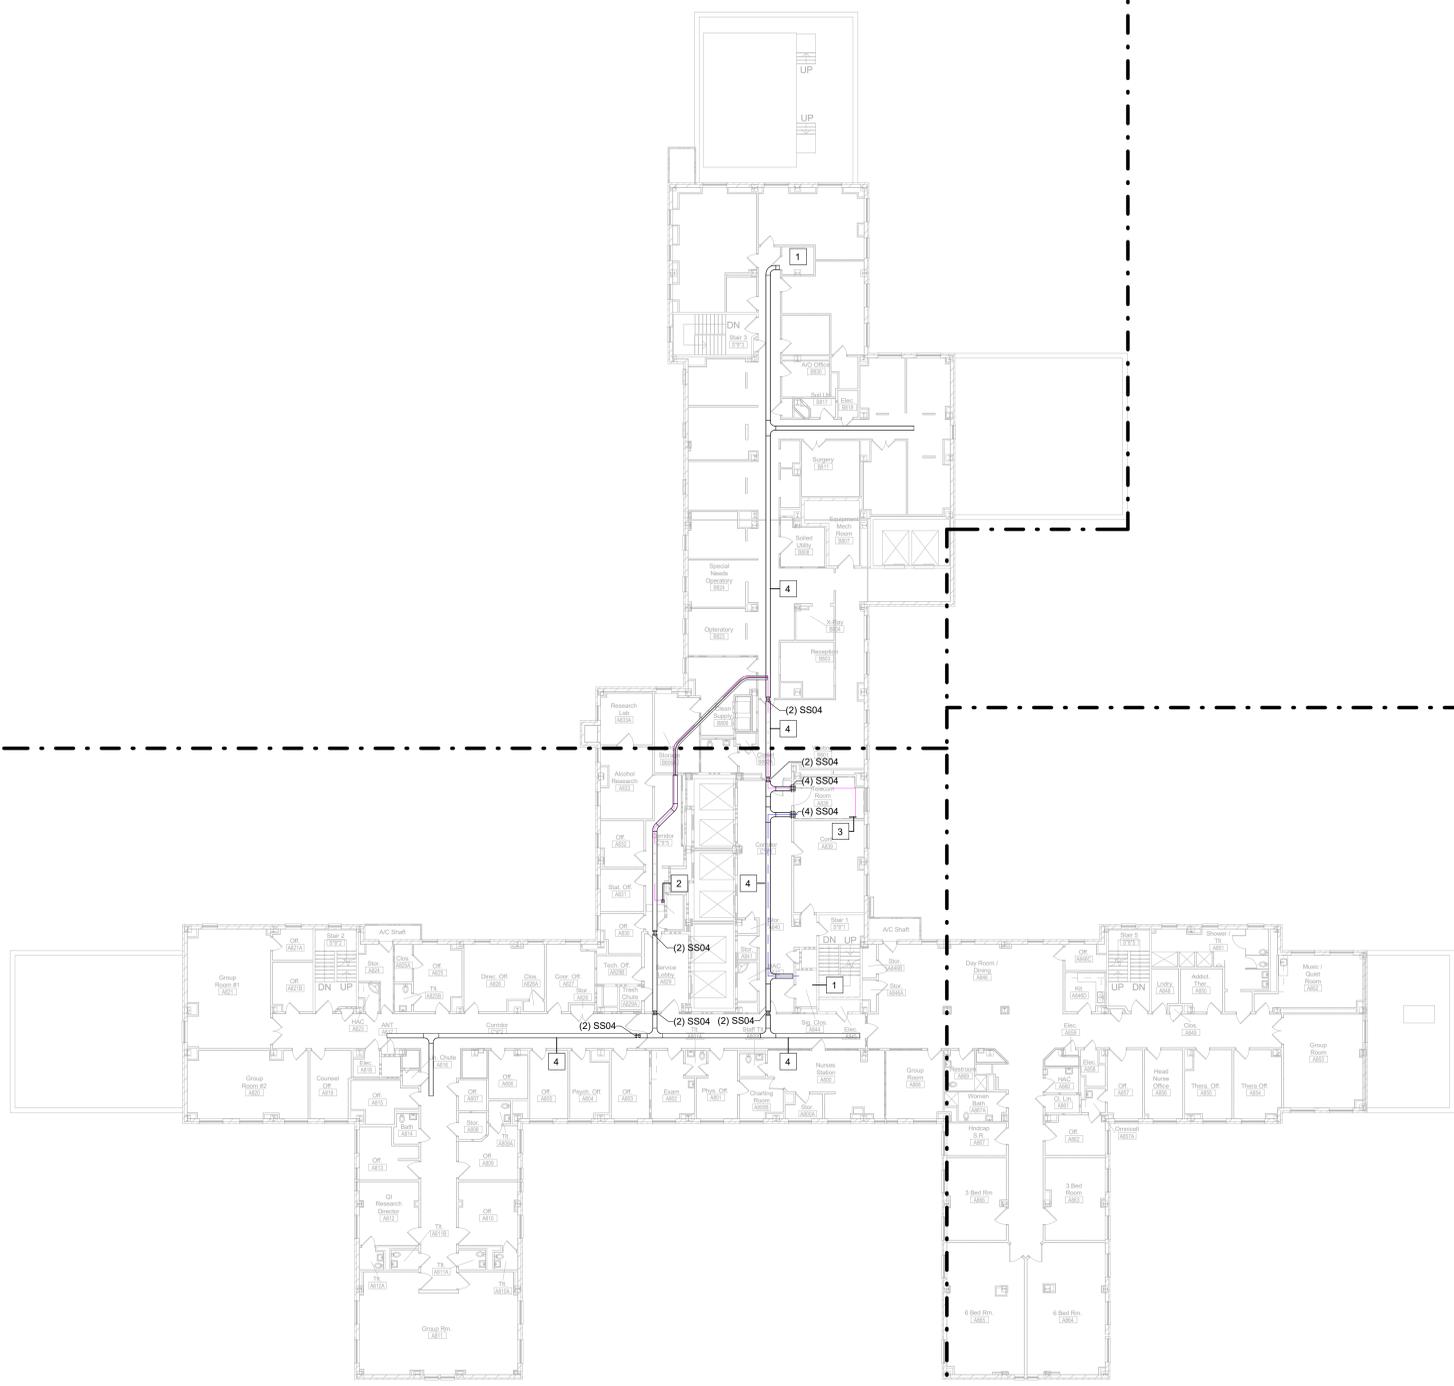

 1 TECHNOLOGY EIGHTH FLOOR OVERALL PLAN
1/16" = 1'-0"

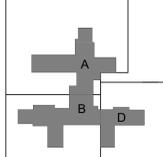

Description	Date
ADDENDUM 1	4/29/2022

CONSULTANT
Ross & Baruzzini
LOW VOLTAGE/ IT
Ross & Baruzzini Inc.
1600 Riveredge Parkway NW
Suite 900
Atlanta, GA 30328
Atlanta, GA 30328

PROJECT MANAGEMENT
HFS
C O M P A N Y
8718 Botts Lane
San Antonio, Texas 78217
www.hfscorporation.com
Phone: (210) 816-4784
Fax: (210) 881-8808
jbianco@hfscorporation.com



Construction and Facilities Management
VA U.S. Department of Veterans Affairs

Drawing Title
TECHNOLOGY EIGHTH FLOOR OVERALL PLAN
Approved: Project Director

Phase
100% CONSTRUCTION DOCUMENTS
FULLY SPRINKLERED

Project Title
CINCINNATI VAMC EHRM INFRASTRUCTURE UPGRADES
Location
3200 VINE ST. CINCINNATI, OH. 45220
Issue Date
04-MAY-2022
Scale
1/16" = 1'-0"


Project Number
539-21-701
Building Number
C1
Drawing Number
TN-190-C.1.8

GENERAL NOTES:



1. REFER TO SHEET T-000 FOR GENERAL NOTES AND LEGENDS.
2. ALL HORIZONTAL CABLING ON THIS FLOOR TO BE TERMINATED IN TRS.
3. CONTRACTOR SHALL INSTALL BACKBONE RISER SLEEVES OF THE SIZE AS INDICATED ON THE PLANS. REFER TO SECTION 27 15 00 COMMUNICATIONS STRUCTURED CABLING AND SECTION 27 05 33 RACEWAYS AND BOXES FOR COMMUNICATIONS SYSTEMS.
4. CONTRACTOR SHALL X-RAY CONCRETE FLOOR BEFORE CORE DRILLING. CONTRACTOR SHALL COORDINATE WITH THE COR BEFORE BEGINNING DRILLING.
5. CONTRACTOR SHALL FIRESTOP RISER SLEEVES AND EMPTY SPARE RISER SLEEVES. REFER TO SECTION 07 54 00 FIRESTOPPING.
6. CONTRACTOR SHALL INSTALL A VERTICAL LADDER TYPE CABLE TRAY ON THE WALL ABOVE THE VERTICAL RISER SLEEVES FOR BACKBONE CABLE SUPPORT AS INDICATED ON THE PLANS. THE CABLE TRAY SHALL BE SECURELY ANCHORED TO THE WALL SUFFICIENT TO SUPPORT THE TOTAL WEIGHT OF CABLES AND CABLE TRAY PLUS 50%.
7. CONTRACTOR SHALL INSTALL CABLE SUPPORTS SUFFICIENT TO SUPPORT COMMUNICATIONS CABLES ON THE VERTICAL CABLE TRAY WITHOUT DAMAGING OR DEFORMING THE CABLE.
8. CONTRACTOR SHALL LABEL EACH CABLE AT 42 INCHES A.F.F. ON EACH FLOOR. REFER TO SECTION 27 15 00 COMMUNICATIONS STRUCTURED CABLING.
9. CONTRACTOR SHALL INSTALL NEW J-HOOKS WHERE THERE IS NO CABLE TRAY OR COMMUNICATIONS CONDUIT UNLESS OTHERWISE NOTED.
10. CONTRACTOR SHALL INSTALL NEW CATEGORY 6A PATCH PANELS IN THE TELECOMMUNICATION ROOM AS INDICATED ON RACK ELEVATIONS.
11. CONTRACTOR SHALL RE-TERMINATE AND TEST CABLING REMOVED FROM ANY WALL MOUNT EQUIPMENT UNLESS OTHERWISE NOTED. TESTING SHALL BE PERFORMED BY THE CONTRACTOR DURING COMMISSIONING.
12. CONTRACTOR SHALL INSTALL NEW CATEGORY 6A TELECOMMUNICATIONS/DATA OUTLET AS INDICATED. EXISTING COMMUNICATION OUTLET BOXES AND CONDUITS TO BE REUSED.
13. CONTRACTOR SHALL REPLACE ALL DATA CABLE WITH NEW CATEGORY 6A CABLE UNLESS OTHERWISE NOTED.
14. CONTRACTOR SHALL TERMINATE COMMUNICATIONS CABLES WITH NEW CATEGORY MODULAR JACKS TO MATCH THE COMMUNICATION CABLE PERFORMANCE SPECIFICATIONS. NEW MODULAR JACKS SHALL BE OF THE SAME MANUFACTURER AS THE FACE PLATES, PATCH PANELS, AND PATCH CABLES.
15. CONTRACTOR SHALL INSTALL NEW CATEGORY 6A CABLES AND CONNECTIVITY COMPONENTS THAT ARE OF THE SAME MANUFACTURER, INCLUDING CABLE, MODULAR JACKS, PATCH PANELS, FACEPLATES, AND PATCH CABLES.
16. CONTRACTOR SHALL TEST ALL NEW AND EXISTING RE-TERMINATED CABLES IN ACCORDANCE WITH THE SPECIFICATION 27 08 00.

KEYED NOTES:


1. EXISTING TELECOMMUNICATIONS ROOM.
2. EXISTING CONDITIONS WERE NOT OBSERVED. DATA SHOWN IN ROOM IS AN ESTIMATE OF WHAT WILL BE REQUIRED.

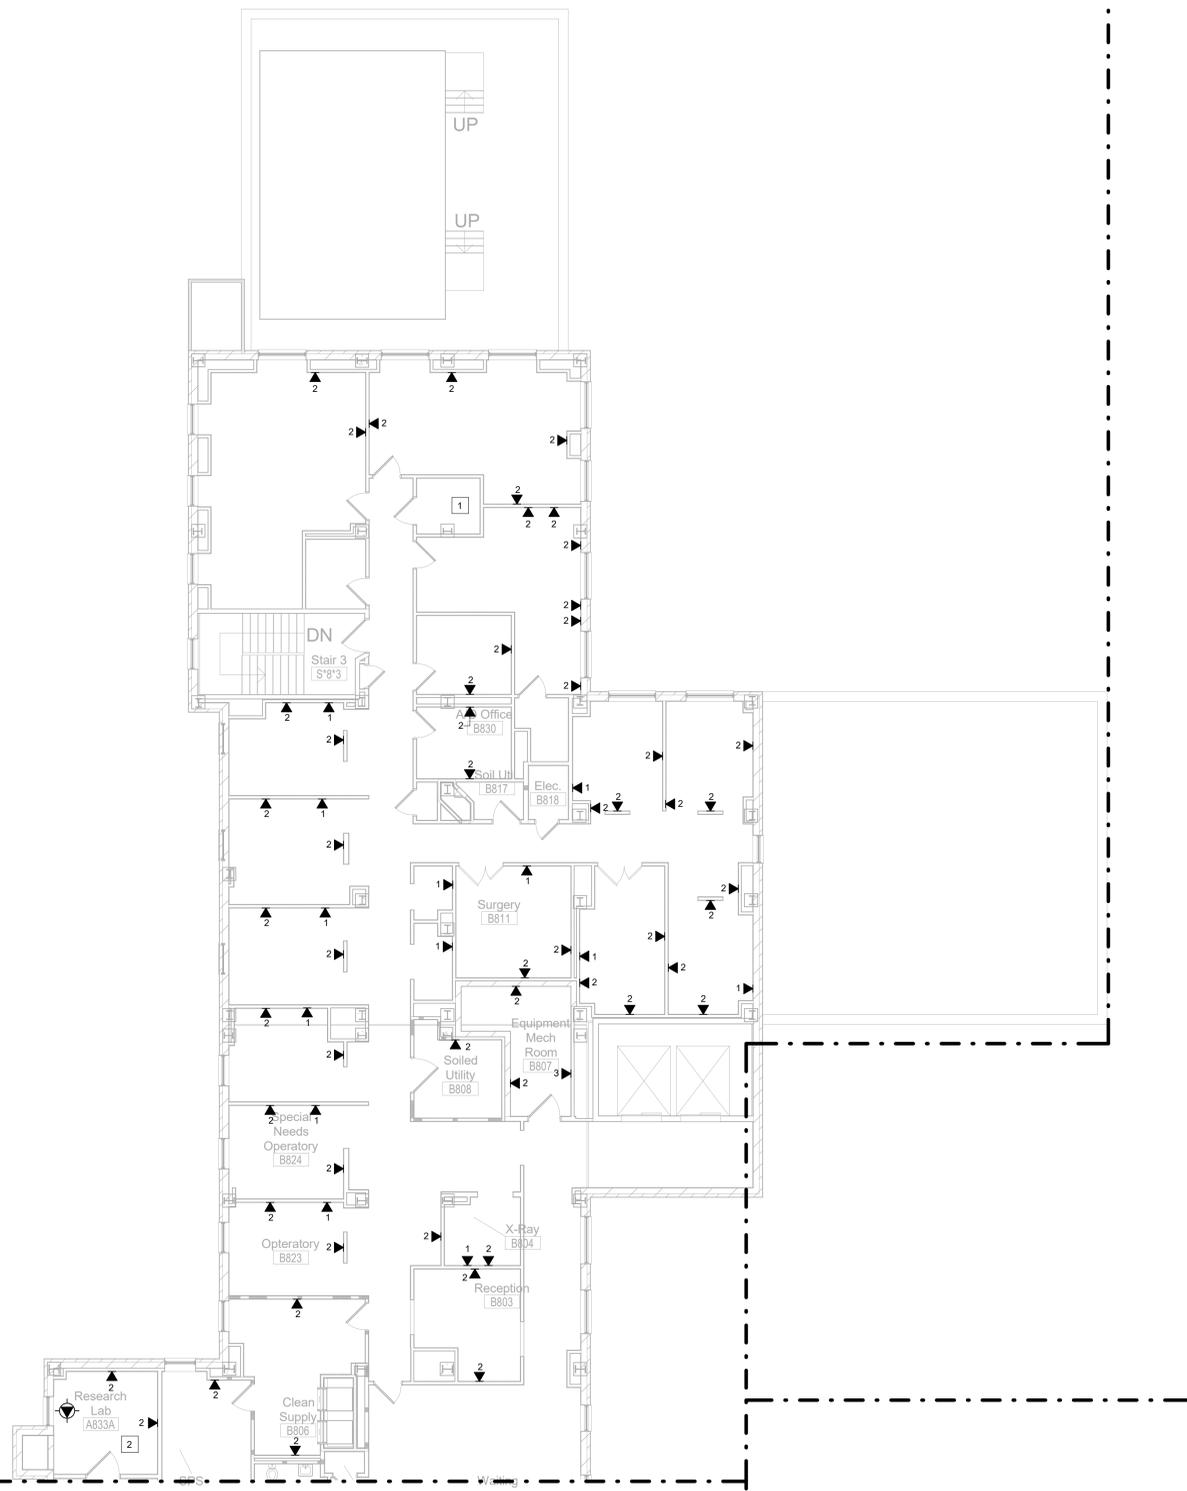

 1 TECHNOLOGY EIGHTH FLOOR PARTIAL PLAN - A
1/8" = 1'-0"

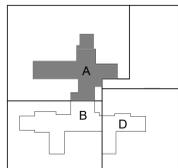



Description	Date	CONSULTANT Ross & Baruzzini LOW VOLTAGE/ IT Ross & Baruzzini Inc. 1600 Riveredge Parkway NW Suite 900 Atlanta, GA 30328	PROJECT MANAGEMENT HFS COMPANY 8718 Botts Lane San Antonio, Texas 78217 www.hfscorporation.com Phone: (210) 816-4784 Fax: (210) 881-6808 jbianco@hfscorporation.com		Construction and Facilities Management VA U.S. Department of Veterans Affairs	Drawing Title	Phase	Project Title	Project Number
						TECHNOLOGY EIGHTH FLOOR PARTIAL PLAN - A	100% CONSTRUCTION DOCUMENTS	CINCINNATI VAMC EHRM INFRASTRUCTURE UPGRADES	539-21-701
						Approved: Project Director	FULLY SPRINKLERED	Location	Building Number
								3200 VINE ST. CINCINNATI, OH. 45220	C1
								Issue Date:	Checked By:
								04-MAY-2022	PR
								Scale: 1/8" = 1'-0"	Drawn By:
									TL
									Drawing Number
									TN-191-C.1.8

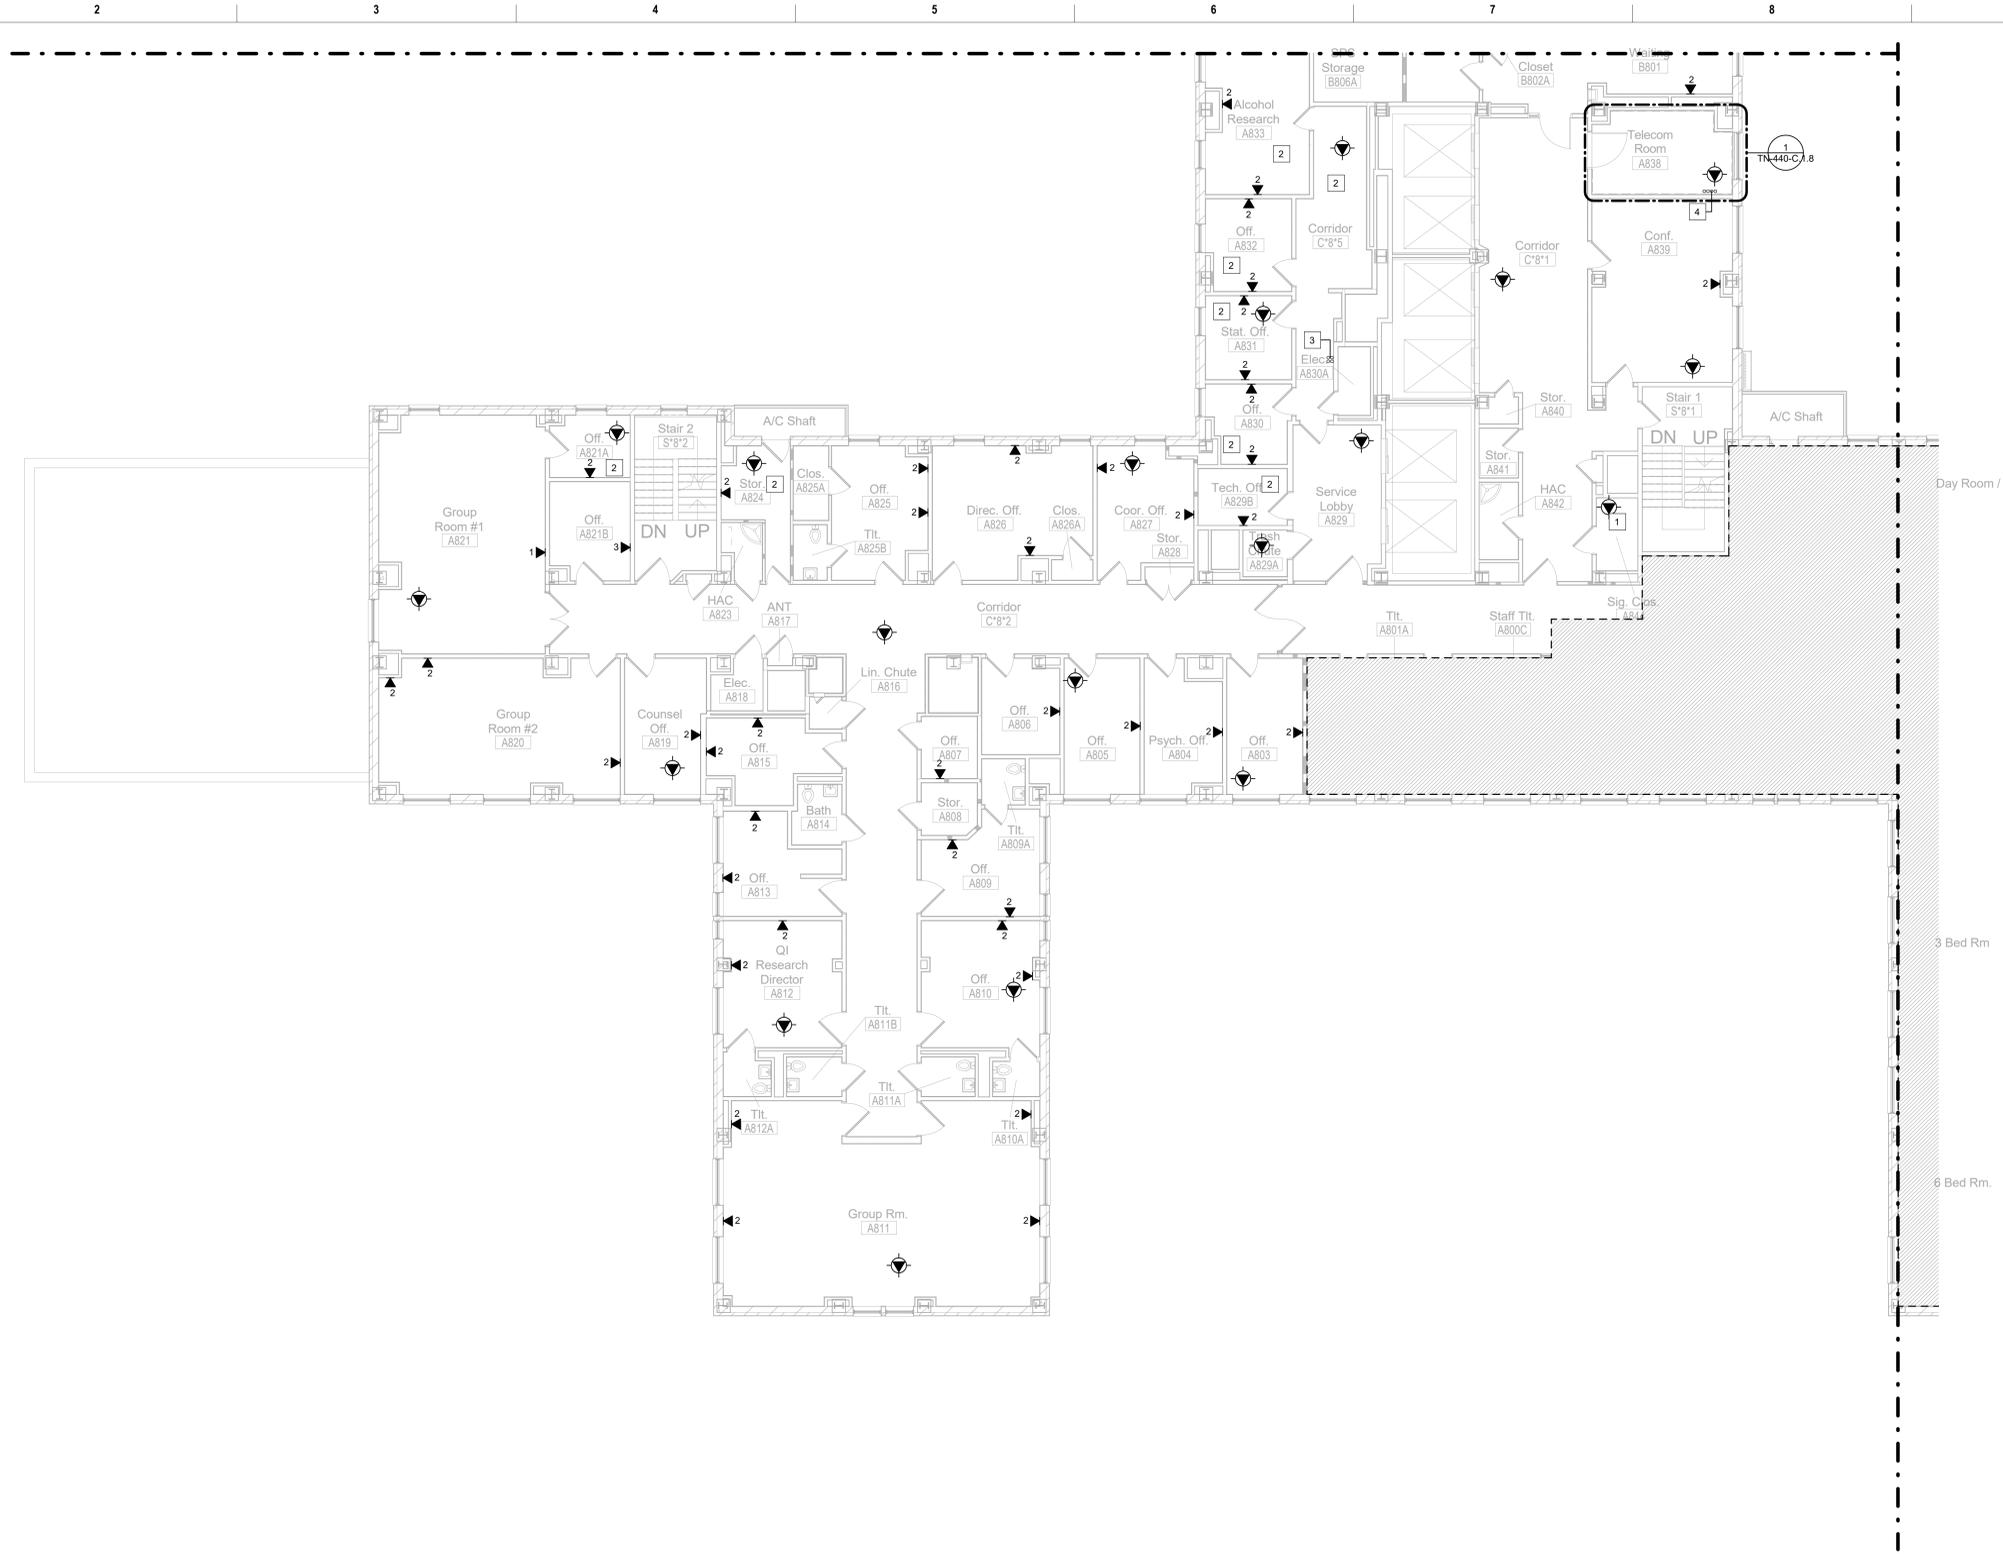


- GENERAL NOTES:**
- REFER TO SHEET T-000 FOR GENERAL NOTES AND LEGENDS.
 - ALL HORIZONTAL CABLING ON THIS FLOOR TO BE TERMINATED IN TRAYS.
 - CONTRACTOR SHALL INSTALL BACKBONE RISER SLEEVES OF THE SIZE AS INDICATED ON THE PLANS. REFER TO SECTION 27 15 00 COMMUNICATIONS STRUCTURED CABLING AND SECTION 27 05 33 RACEWAYS AND BOXES FOR COMMUNICATIONS SYSTEMS.
 - CONTRACTOR SHALL X-RAY CONCRETE FLOOR BEFORE CORE DRILLING. CONTRACTOR SHALL COORDINATE WITH THE COR BEFORE BEGINNING DRILLING.
 - CONTRACTOR SHALL FIRESTOP RISER SLEEVES AND EMPTY SPARE RISER SLEEVES. REFER TO SECTION 07 84 00 FIRESTOPPING.
 - CONTRACTOR SHALL INSTALL A VERTICAL LADDER TYPE CABLE TRAY ON THE WALL ABOVE THE VERTICAL RISER SLEEVES FOR BACKBONE CABLE SUPPORT AS INDICATED ON THE PLANS. THE CABLE TRAY SHALL BE SECURELY ANCHORED TO THE WALL SUFFICIENT TO SUPPORT THE TOTAL WEIGHT OF CABLES AND CABLE TRAY PLUS 50%.
 - CONTRACTOR SHALL INSTALL CABLE SUPPORTS SUFFICIENT TO SUPPORT COMMUNICATIONS CABLES ON THE VERTICAL CABLE TRAY WITHOUT DAMAGING OR DEFORMING THE CABLE.
 - CONTRACTOR SHALL LABEL EACH CABLE AT 42 INCHES A.F.F. ON EACH FLOOR. REFER TO SECTION 27 15 00 COMMUNICATIONS STRUCTURED CABLING.
 - CONTRACTOR SHALL INSTALL NEW J-HOOKS WHERE THERE IS NO CABLE TRAY OR COMMUNICATIONS CONDUIT UNLESS OTHERWISE NOTED.
 - CONTRACTOR SHALL INSTALL NEW CATEGORY 6A PATCH PANELS IN THE TELECOMMUNICATION ROOM AS INDICATED ON RACK ELEVATIONS.
 - CONTRACTOR SHALL RE-TERMINATE AND TEST CABLING REMOVED FROM ANY WALL MOUNT EQUIPMENT UNLESS OTHERWISE NOTED. TESTING SHALL BE PERFORMED BY THE CONTRACTOR DURING COMMISSIONING.
 - CONTRACTOR SHALL INSTALL NEW CATEGORY 6A TELECOMMUNICATIONS/ DATA OUTLET AS INDICATED. EXISTING COMMUNICATION OUTLET BOXES AND CONDUITS TO BE REUSED.
 - CONTRACTOR SHALL REPLACE ALL DATA CABLE WITH NEW CATEGORY 6A CABLE UNLESS OTHERWISE NOTED.
 - CONTRACTOR SHALL TERMINATE COMMUNICATIONS CABLES WITH NEW CATEGORY MODULAR JACKS TO MATCH THE COMMUNICATION CABLE PERFORMANCE SPECIFICATIONS. NEW MODULAR JACKS SHALL BE OF THE SAME MANUFACTURER AS THE FACE PLATES, PATCH PANELS, AND PATCH CABLES.
 - CONTRACTOR SHALL INSTALL NEW CATEGORY 6A CABLES AND CONNECTIVITY COMPONENTS THAT ARE OF THE SAME MANUFACTURER, INCLUDING CABLE, MODULAR JACKS, PATCH PANELS, FACEPLATES, AND PATCH CABLES.
 - CONTRACTOR SHALL TEST ALL NEW AND EXISTING RE-TERMINATED CABLES IN ACCORDANCE WITH THE SPECIFICATION 27 08 00.

 - KEYED NOTES:**
- EXISTING TELECOMMUNICATIONS ROOM.
 - EXISTING CONDITIONS WERE NOT OBSERVED. DATA SHOWN IN ROOM IS AN ESTIMATE OF WHAT WILL BE REQUIRED.
 - PROVIDE (4) 4" CONDUITS TO TR ON LEVEL ABOVE.
 - PROVIDE (4) 4" CONDUITS TO TR ON LEVEL BELOW.

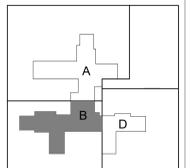

1 TECHNOLOGY EIGHTH FLOOR PARTIAL PLAN - B
1/8" = 1'-0"

Description Date		CONSULTANT Ross & Baruzzini LOW VOLTAGE/ IT Ross & Baruzzini Inc. 1600 Riveredge Parkway NW Suite 900 Atlanta, GA 30328		PROJECT MANAGEMENT HFS C O M P A N Y 8718 Botts Lane San Antonio, Texas 78217 www.hfscompany.com jbianco@hfscompany.com		 Construction and Facilities Management VA U.S. Department of Veterans Affairs		Drawing Title TECHNOLOGY EIGHTH FLOOR PARTIAL PLAN - B Approved: Project Director		Phase 100% CONSTRUCTION DOCUMENTS FULLY SPRINKLERED		Project Title CINCINNATI VAMC EHRM INFRASTRUCTURE UPGRADES Location 3200 VINE ST. CINCINNATI, OH. 45220 Issue Date: 04-MAY-2022 Scale: 1/8" = 1'-0"		Project Number 539-21-701 Building Number C1 Drawing Number TN-192-C.1.8	
---------------------	--	---	--	---	--	---	--	--	--	---	--	---	--	--	--

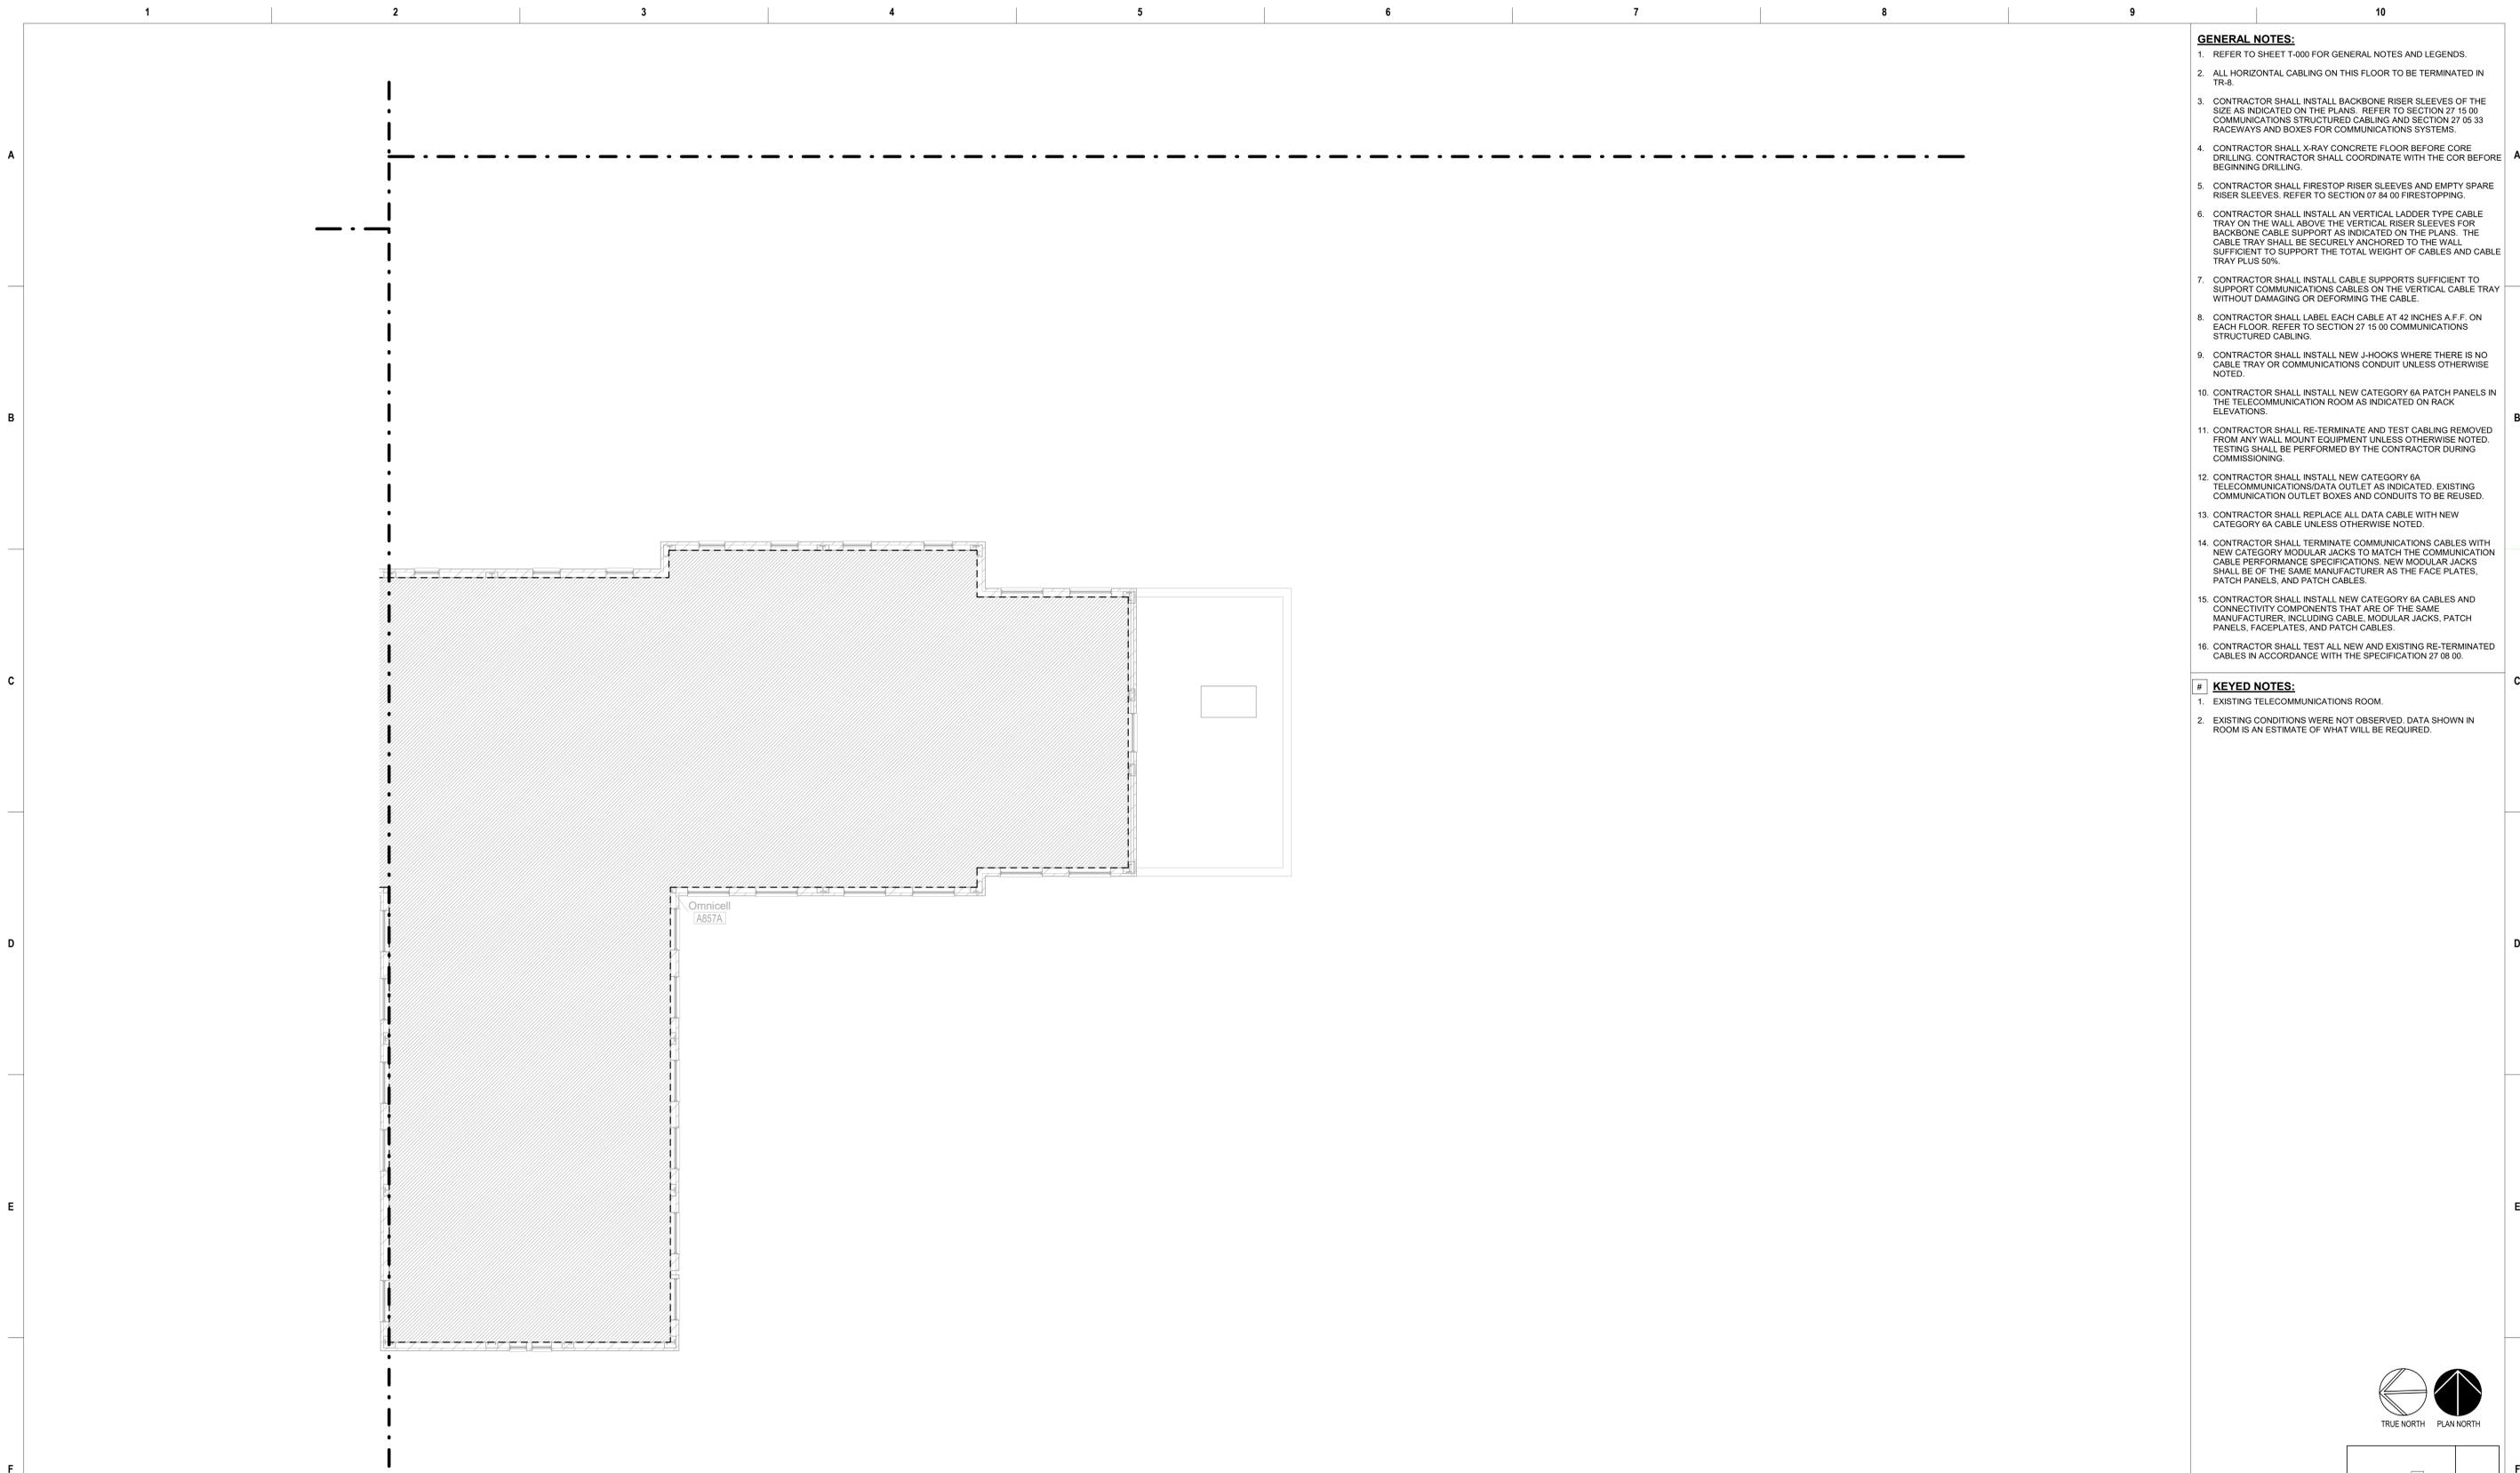


① TECHNOLOGY EIGHTH FLOOR PARTIAL PLAN - D
1/8" = 1'-0"

GENERAL NOTES:

1. REFER TO SHEET T-000 FOR GENERAL NOTES AND LEGENDS.
2. ALL HORIZONTAL CABLING ON THIS FLOOR TO BE TERMINATED IN TRAYS.
3. CONTRACTOR SHALL INSTALL BACKBONE RISER SLEEVES OF THE SIZE AS INDICATED ON THE PLANS. REFER TO SECTION 27 15 00 COMMUNICATIONS STRUCTURED CABLING AND SECTION 27 05 33 RACEWAYS AND BOXES FOR COMMUNICATIONS SYSTEMS.
4. CONTRACTOR SHALL X-RAY CONCRETE FLOOR BEFORE CORE DRILLING. CONTRACTOR SHALL COORDINATE WITH THE COR BEFORE BEGINNING DRILLING.
5. CONTRACTOR SHALL FIRESTOP RISER SLEEVES AND EMPTY SPARE RISER SLEEVES. REFER TO SECTION 07 64 00 FIRESTOPPING.
6. CONTRACTOR SHALL INSTALL A VERTICAL LADDER TYPE CABLE TRAY ON THE WALL ABOVE THE VERTICAL RISER SLEEVES FOR BACKBONE CABLE SUPPORT AS INDICATED ON THE PLANS. THE CABLE TRAY SHALL BE SECURELY ANCHORED TO THE WALL SUFFICIENT TO SUPPORT THE TOTAL WEIGHT OF CABLES AND CABLE TRAY PLUS 50%.
7. CONTRACTOR SHALL INSTALL CABLE SUPPORTS SUFFICIENT TO SUPPORT COMMUNICATIONS CABLES ON THE VERTICAL CABLE TRAY WITHOUT DAMAGING OR DEFORMING THE CABLE.
8. CONTRACTOR SHALL LABEL EACH CABLE AT 42 INCHES A.F.F. ON EACH FLOOR. REFER TO SECTION 27 15 00 COMMUNICATIONS STRUCTURED CABLING.
9. CONTRACTOR SHALL INSTALL NEW J-HOOKS WHERE THERE IS NO CABLE TRAY OR COMMUNICATIONS CONDUIT UNLESS OTHERWISE NOTED.
10. CONTRACTOR SHALL INSTALL NEW CATEGORY 6A PATCH PANELS IN THE TELECOMMUNICATION ROOM AS INDICATED ON RACK ELEVATIONS.
11. CONTRACTOR SHALL RE-TERMINATE AND TEST CABLING REMOVED FROM ANY WALL MOUNT EQUIPMENT UNLESS OTHERWISE NOTED. TESTING SHALL BE PERFORMED BY THE CONTRACTOR DURING COMMISSIONING.
12. CONTRACTOR SHALL INSTALL NEW CATEGORY 6A TELECOMMUNICATIONS/ DATA OUTLET AS INDICATED. EXISTING COMMUNICATION OUTLET BOXES AND CONDUITS TO BE REUSED.
13. CONTRACTOR SHALL REPLACE ALL DATA CABLE WITH NEW CATEGORY 6A CABLE UNLESS OTHERWISE NOTED.
14. CONTRACTOR SHALL TERMINATE COMMUNICATIONS CABLES WITH NEW CATEGORY MODULAR JACKS TO MATCH THE COMMUNICATION CABLE PERFORMANCE SPECIFICATIONS. NEW MODULAR JACKS SHALL BE OF THE SAME MANUFACTURER AS THE FACE PLATES, PATCH PANELS, AND PATCH CABLES.
15. CONTRACTOR SHALL INSTALL NEW CATEGORY 6A CABLES AND CONNECTIVITY COMPONENTS THAT ARE OF THE SAME MANUFACTURER, INCLUDING CABLE, MODULAR JACKS, PATCH PANELS, FACEPLATES, AND PATCH CABLES.
16. CONTRACTOR SHALL TEST ALL NEW AND EXISTING RE-TERMINATED CABLES IN ACCORDANCE WITH THE SPECIFICATION 27 08 00.

KEYED NOTES:

1. EXISTING TELECOMMUNICATIONS ROOM.
2. EXISTING CONDITIONS WERE NOT OBSERVED. DATA SHOWN IN ROOM IS AN ESTIMATE OF WHAT WILL BE REQUIRED.

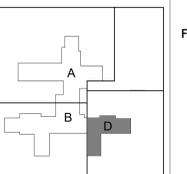

Description	Date

CONSULTANT
Ross & Baruzzini
LOW VOLTAGE/ IT
Ross & Baruzzini Inc.
1600 Riveredge Parkway NW
Suite 900
Atlanta, GA 30328
jbianco@hfscompany.com

PROJECT MANAGEMENT
HFS
C O M P A N Y
8718 Botts Lane Phone: (210) 816-4784
San Antonio, Texas 78217 Fax: (210) 881-6808
www.hfscompany.com
jbianco@hfscompany.com



Construction and Facilities Management
VA U.S. Department of Veterans Affairs

Drawing Title
TECHNOLOGY EIGHTH FLOOR PARTIAL PLAN - D
Approved: Project Director



Phase
100% CONSTRUCTION DOCUMENTS
FULLY SPRINKLERED

Project Title
CINCINNATI VAMC EHRM INFRASTRUCTURE UPGRADES
Location
3200 VINE ST. CINCINNATI, OH. 45220
Issue Date:
04-MAY-2022
Scale:
1/8" = 1'-0"

Project Number
539-21-701
Building Number
C1
Drawing Number
TN-193-C.1.8


- GENERAL NOTES:**
- REFER TO SHEET T-000 FOR GENERAL NOTES AND LEGENDS.
 - ALL HORIZONTAL CABLING ON THIS FLOOR TO BE TERMINATED IN TR-9.
 - CONTRACTOR SHALL INSTALL BACKBONE RISER SLEEVES OF THE SIZE AS INDICATED ON THE PLANS. REFER TO SECTION 27 15 00 COMMUNICATIONS STRUCTURED CABLING AND SECTION 27 05 33 RACEWAYS AND BOXES FOR COMMUNICATIONS SYSTEMS.
 - CONTRACTOR SHALL X-RAY CONCRETE FLOOR BEFORE CORE DRILLING. CONTRACTOR SHALL COORDINATE WITH THE COR BEFORE BEGINNING DRILLING.
 - CONTRACTOR SHALL FIRESTOP RISER SLEEVES AND EMPTY SPARE RISER SLEEVES. REFER TO SECTION 07 84 00 FIRESTOPPING.
 - CONTRACTOR SHALL INSTALL A VERTICAL LADDER TYPE CABLE TRAY ON THE WALL ABOVE THE VERTICAL RISER SLEEVES FOR BACKBONE CABLE SUPPORT AS INDICATED ON THE PLANS. THE CABLE TRAY SHALL BE SECURELY ANCHORED TO THE WALL SUFFICIENT TO SUPPORT THE TOTAL WEIGHT OF CABLES AND CABLE TRAY PLUS 50%.
 - CONTRACTOR SHALL INSTALL CABLE SUPPORTS SUFFICIENT TO SUPPORT COMMUNICATIONS CABLES ON THE VERTICAL CABLE TRAY WITHOUT DAMAGING OR DEFORMING THE CABLE.
 - CONTRACTOR SHALL LABEL EACH CABLE AT 42 INCHES A.F.F. ON EACH FLOOR. REFER TO SECTION 27 15 00 COMMUNICATIONS STRUCTURED CABLING.
 - CONTRACTOR SHALL INSTALL NEW J-HOOKS WHERE THERE IS NO CABLE TRAY OR COMMUNICATIONS CONDUIT UNLESS OTHERWISE NOTED.
 - CONTRACTOR SHALL INSTALL NEW CATEGORY 6A PATCH PANELS IN THE TELECOMMUNICATION ROOM AS INDICATED ON RACK ELEVATIONS.
 - CONTRACTOR SHALL RE-TERMINATE AND TEST CABLING REMOVED FROM ANY WALL MOUNT EQUIPMENT UNLESS OTHERWISE NOTED. TESTING SHALL BE PERFORMED BY THE CONTRACTOR DURING COMMISSIONING.
 - CONTRACTOR SHALL INSTALL NEW CATEGORY 6A TELECOMMUNICATIONS/DATA OUTLET AS INDICATED. EXISTING COMMUNICATION OUTLET BOXES AND CONDUITS TO BE REUSED.
 - CONTRACTOR SHALL REPLACE ALL DATA CABLE WITH NEW CATEGORY 6A CABLE UNLESS OTHERWISE NOTED.
 - CONTRACTOR SHALL TERMINATE COMMUNICATIONS CABLES WITH NEW CATEGORY MODULAR JACKS TO MATCH THE COMMUNICATION CABLE PERFORMANCE SPECIFICATIONS. NEW MODULAR JACKS SHALL BE OF THE SAME MANUFACTURER AS THE FACE PLATES, PATCH PANELS, AND PATCH CABLES.
 - CONTRACTOR SHALL INSTALL NEW CATEGORY 6A CABLES AND CONNECTIVITY COMPONENTS THAT ARE OF THE SAME MANUFACTURER, INCLUDING CABLE, MODULAR JACKS, PATCH PANELS, FACEPLATES, AND PATCH CABLES.
 - CONTRACTOR SHALL TEST ALL NEW AND EXISTING RE-TERMINATED CABLES IN ACCORDANCE WITH THE SPECIFICATION 27 08 00.

- KEYED NOTES:**
- EXISTING TELECOMMUNICATIONS ROOM.
 - EXISTING CONDITIONS WERE NOT OBSERVED. DATA SHOWN IN ROOM IS AN ESTIMATE OF WHAT WILL BE REQUIRED.

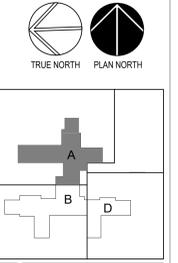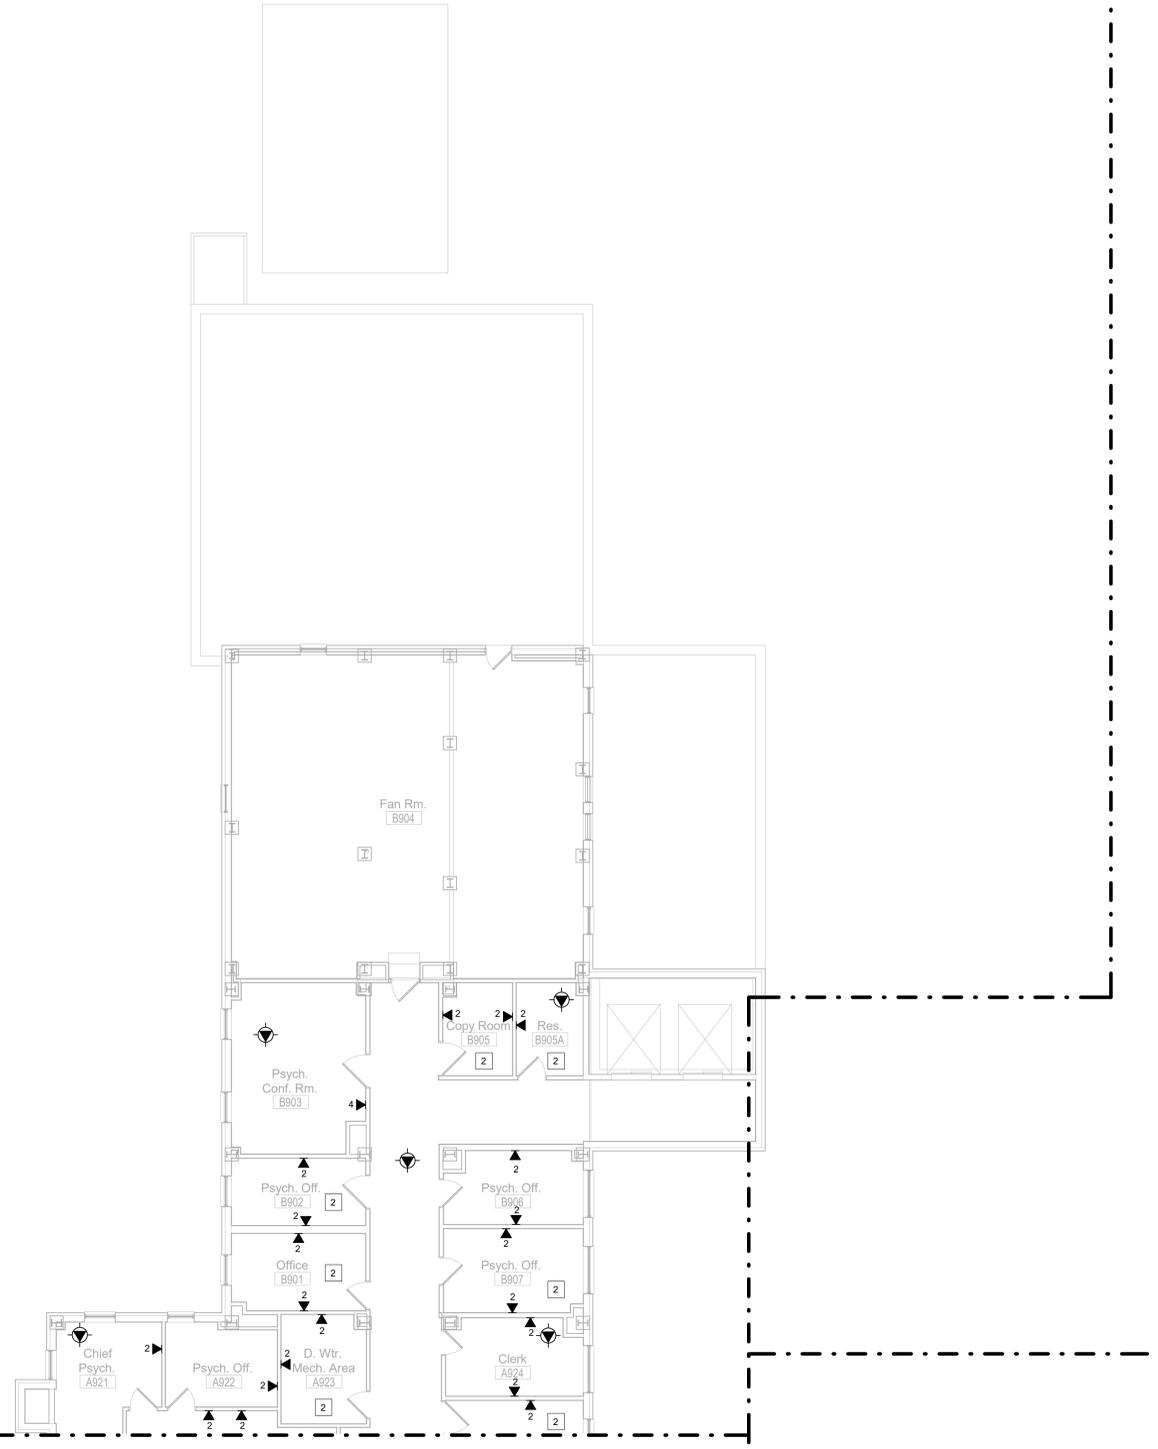



① TECHNOLOGY NINETH FLOOR PARTIAL PLAN - A
1/8" = 1'-0"

Description	Date	CONSULTANT Ross & Baruzzini LOW VOLTAGE/ IT Ross & Baruzzini Inc. 1600 Riveredge Parkway NW Suite 900 Atlanta, GA 30328	PROJECT MANAGEMENT HFS COMPANY 8718 Botts Lane San Antonio, Texas 78217 www.hfscorpany.com jbianco@hfscorpany.com	 BICSI Registered Communications Distributor RCDD	Construction and Facilities Management VA U.S. Department of Veterans Affairs	Drawing Title	Phase	Project Title	Project Number	
						TECHNOLOGY NINTH FLOOR PARTIAL PLAN - A	100% CONSTRUCTION DOCUMENTS	CINCINNATI VAMC EHRM INFRASTRUCTURE UPGRADES	539-21-701	
						Approved: Project Director	FULLY SPRINKLERED	Location	Building Number	
								3200 VINE ST. CINCINNATI, OH. 45220	C1	
								Issue Date:	Checked By:	Drawn By:
								04-MAY-2022	PR	TL
								Scale: 1/8" = 1'-0"	Drawing Number	
									TN-201-C.1.9	

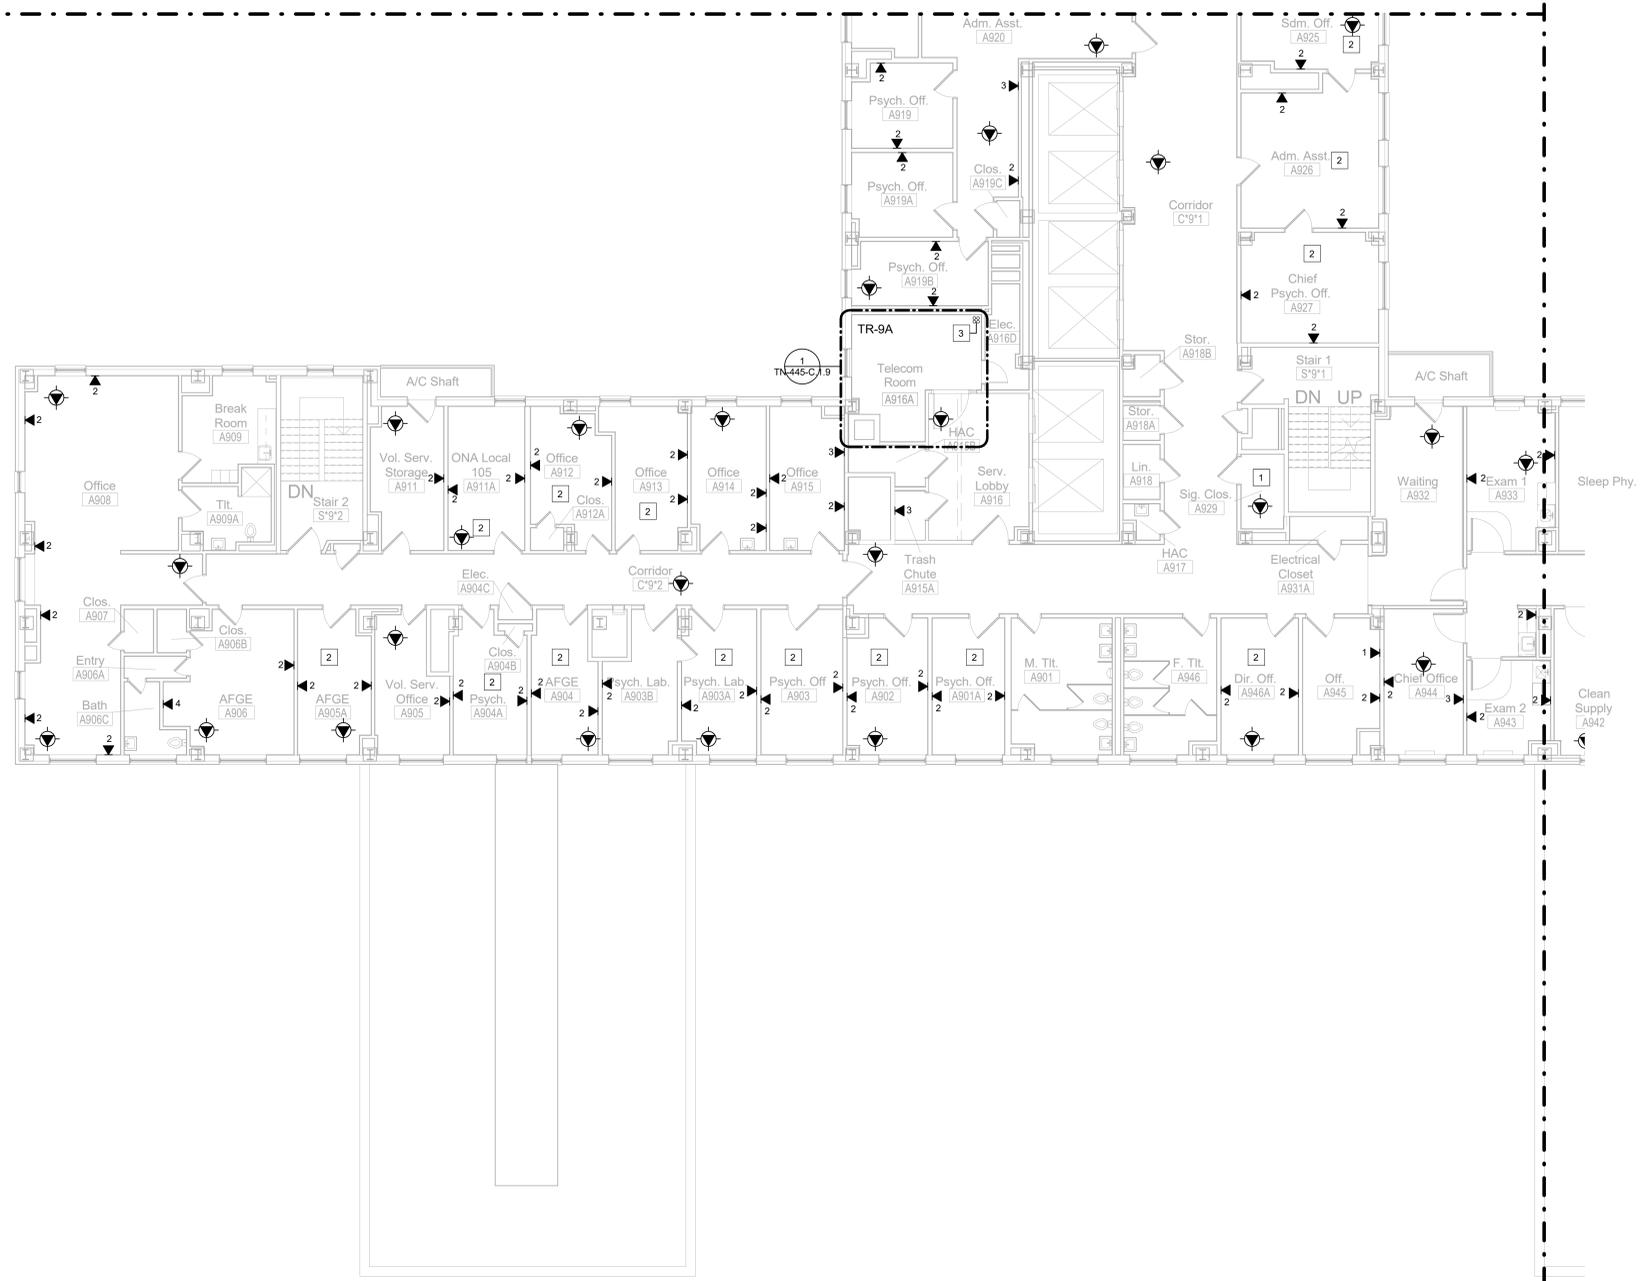

- GENERAL NOTES:**
- REFER TO SHEET T-000 FOR GENERAL NOTES AND LEGENDS.
 - ALL HORIZONTAL CABLING ON THIS FLOOR TO BE TERMINATED IN TR-9.
 - CONTRACTOR SHALL INSTALL BACKBONE RISER SLEEVES OF THE SIZE AS INDICATED ON THE PLANS. REFER TO SECTION 27 15 00 COMMUNICATIONS STRUCTURED CABLING AND SECTION 27 05 33 RACEWAYS AND BOXES FOR COMMUNICATIONS SYSTEMS.
 - CONTRACTOR SHALL X-RAY CONCRETE FLOOR BEFORE CORE DRILLING. CONTRACTOR SHALL COORDINATE WITH THE COR BEFORE BEGINNING DRILLING.
 - CONTRACTOR SHALL FIRESTOP RISER SLEEVES AND EMPTY SPARE RISER SLEEVES. REFER TO SECTION 07 84 00 FIRESTOPPING.
 - CONTRACTOR SHALL INSTALL AN VERTICAL LADDER TYPE CABLE TRAY ON THE WALL ABOVE THE VERTICAL RISER SLEEVES FOR BACKBONE CABLE SUPPORT AS INDICATED ON THE PLANS. THE CABLE TRAY SHALL BE SECURELY ANCHORED TO THE WALL SUFFICIENT TO SUPPORT THE TOTAL WEIGHT OF CABLES AND CABLE TRAY PLUS 50%.
 - CONTRACTOR SHALL INSTALL CABLE SUPPORTS SUFFICIENT TO SUPPORT COMMUNICATIONS CABLES ON THE VERTICAL CABLE TRAY WITHOUT DAMAGING OR DEFORMING THE CABLE.
 - CONTRACTOR SHALL LABEL EACH CABLE AT 42 INCHES A.F.F. ON EACH FLOOR. REFER TO SECTION 27 15 00 COMMUNICATIONS STRUCTURED CABLING.
 - CONTRACTOR SHALL INSTALL NEW J-HOOKS WHERE THERE IS NO CABLE TRAY OR COMMUNICATIONS CONDUIT UNLESS OTHERWISE NOTED.
 - CONTRACTOR SHALL INSTALL NEW CATEGORY 6A PATCH PANELS IN THE TELECOMMUNICATION ROOM AS INDICATED ON RACK ELEVATIONS.
 - CONTRACTOR SHALL RE-TERMINATE AND TEST CABLING REMOVED FROM ANY WALL MOUNT EQUIPMENT UNLESS OTHERWISE NOTED. TESTING SHALL BE PERFORMED BY THE CONTRACTOR DURING COMMISSIONING.
 - CONTRACTOR SHALL INSTALL NEW CATEGORY 6A TELECOMMUNICATIONS/ DATA OUTLET AS INDICATED. EXISTING COMMUNICATION OUTLET BOXES AND CONDUITS TO BE REUSED.
 - CONTRACTOR SHALL REPLACE ALL DATA CABLE WITH NEW CATEGORY 6A CABLE UNLESS OTHERWISE NOTED.
 - CONTRACTOR SHALL TERMINATE COMMUNICATIONS CABLES WITH NEW CATEGORY MODULAR JACKS TO MATCH THE COMMUNICATION CABLE PERFORMANCE SPECIFICATIONS. NEW MODULAR JACKS SHALL BE OF THE SAME MANUFACTURER AS THE FACE PLATES, PATCH PANELS, AND PATCH CABLES.
 - CONTRACTOR SHALL INSTALL NEW CATEGORY 6A CABLES AND CONNECTIVITY COMPONENTS THAT ARE OF THE SAME MANUFACTURER, INCLUDING CABLE, MODULAR JACKS, PATCH PANELS, FACEPLATES, AND PATCH CABLES.
 - CONTRACTOR SHALL TEST ALL NEW AND EXISTING RE-TERMINATED CABLES IN ACCORDANCE WITH THE SPECIFICATION 27 08 00.
- KEYED NOTES:**
- EXISTING TELECOMMUNICATIONS ROOM.
 - EXISTING CONDITIONS WERE NOT OBSERVED. DATA SHOWN IN ROOM IS AN ESTIMATE OF WHAT WILL BE REQUIRED.
 - PROVIDE (5) 4" CONDUITS TO LEVEL BELOW FOR LEVEL 8 HORIZONTAL CABLING AND FIBER BACKBONE PATHWAY.

 1 TECHNOLOGY NINTH FLOOR PARTIAL PLAN - B
1/8" = 1'-0"

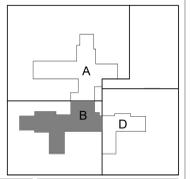


Description Date		CONSULTANT Ross & Baruzzini LOW VOLTAGE/ IT Ross & Baruzzini Inc. 1600 Riveredge Parkway NW Suite 900 Atlanta, GA 30328	PROJECT MANAGEMENT HFS C O M P A N Y 8718 Botts Lane San Antonio, Texas 78217 www.hfscmpany.com jbianco@hfscmpany.com	Bicsi Registered Communications Distribution Engineers RCDD	Construction and Facilities Management U.S. Department of Veterans Affairs	Drawing Title TECHNOLOGY NINTH FLOOR PARTIAL PLAN - B Approved: Project Director	Phase 100% CONSTRUCTION DOCUMENTS FULLY SPRINKLERED	Project Title CINCINNATI VAMC EHRM INFRASTRUCTURE UPGRADES Location 3200 VINE ST. CINCINNATI, OH. 45220 Issue Date: 04-MAY-2022 Scale: 1/8" = 1'-0"	Project Number 539-21-701 Building Number C1 Drawing Number TN-202-C.1.9
---------------------	--	---	---	---	--	---	---	---	--

GENERAL NOTES:



- REFER TO SHEET T-000 FOR GENERAL NOTES AND LEGENDS.
- ALL HORIZONTAL CABLING ON THIS FLOOR TO BE TERMINATED IN TR-9.
- CONTRACTOR SHALL INSTALL BACKBONE RISER SLEEVES OF THE SIZE AS INDICATED ON THE PLANS. REFER TO SECTION 27 15 00 COMMUNICATIONS STRUCTURED CABLING AND SECTION 27 05 33 RACEWAYS AND BOXES FOR COMMUNICATIONS SYSTEMS.
- CONTRACTOR SHALL X-RAY CONCRETE FLOOR BEFORE CORE DRILLING. CONTRACTOR SHALL COORDINATE WITH THE COR BEFORE BEGINNING DRILLING.
- CONTRACTOR SHALL FIRESTOP RISER SLEEVES AND EMPTY SPARE RISER SLEEVES. REFER TO SECTION 07 84 00 FIRESTOPPING.
- CONTRACTOR SHALL INSTALL A VERTICAL LADDER TYPE CABLE TRAY ON THE WALL ABOVE THE VERTICAL RISER SLEEVES FOR BACKBONE CABLE SUPPORT AS INDICATED ON THE PLANS. THE CABLE TRAY SHALL BE SECURELY ANCHORED TO THE WALL SUFFICIENT TO SUPPORT THE TOTAL WEIGHT OF CABLES AND CABLE TRAY PLUS 50%.
- CONTRACTOR SHALL INSTALL CABLE SUPPORTS SUFFICIENT TO SUPPORT COMMUNICATIONS CABLES ON THE VERTICAL CABLE TRAY WITHOUT DAMAGING OR DEFORMING THE CABLE.
- CONTRACTOR SHALL LABEL EACH CABLE AT 42 INCHES A.F.F. ON EACH FLOOR. REFER TO SECTION 27 15 00 COMMUNICATIONS STRUCTURED CABLING.
- CONTRACTOR SHALL INSTALL NEW J-HOOKS WHERE THERE IS NO CABLE TRAY OR COMMUNICATIONS CONDUIT UNLESS OTHERWISE NOTED.
- CONTRACTOR SHALL INSTALL NEW CATEGORY 6A PATCH PANELS IN THE TELECOMMUNICATION ROOM AS INDICATED ON RACK ELEVATIONS.
- CONTRACTOR SHALL RE-TERMINATE AND TEST CABLING REMOVED FROM ANY WALL MOUNT EQUIPMENT UNLESS OTHERWISE NOTED. TESTING SHALL BE PERFORMED BY THE CONTRACTOR DURING COMMISSIONING.
- CONTRACTOR SHALL INSTALL NEW CATEGORY 6A TELECOMMUNICATIONS/DATA OUTLET AS INDICATED. EXISTING COMMUNICATION OUTLET BOXES AND CONDUITS TO BE REUSED.
- CONTRACTOR SHALL REPLACE ALL DATA CABLE WITH NEW CATEGORY 6A CABLE UNLESS OTHERWISE NOTED.
- CONTRACTOR SHALL TERMINATE COMMUNICATIONS CABLES WITH NEW CATEGORY MODULAR JACKS TO MATCH THE COMMUNICATION CABLE PERFORMANCE SPECIFICATIONS. NEW MODULAR JACKS SHALL BE OF THE SAME MANUFACTURER AS THE FACE PLATES, PATCH PANELS, AND PATCH CABLES.
- CONTRACTOR SHALL INSTALL NEW CATEGORY 6A CABLES AND CONNECTIVITY COMPONENTS THAT ARE OF THE SAME MANUFACTURER, INCLUDING CABLE, MODULAR JACKS, PATCH PANELS, FACEPLATES, AND PATCH CABLES.
- CONTRACTOR SHALL TEST ALL NEW AND EXISTING RE-TERMINATED CABLES IN ACCORDANCE WITH THE SPECIFICATION 27 08 00.

KEYED NOTES:

- EXISTING TELECOMMUNICATIONS ROOM.
- EXISTING CONDITIONS WERE NOT OBSERVED. DATA SHOWN IN ROOM IS AN ESTIMATE OF WHAT WILL BE REQUIRED.
- XXX

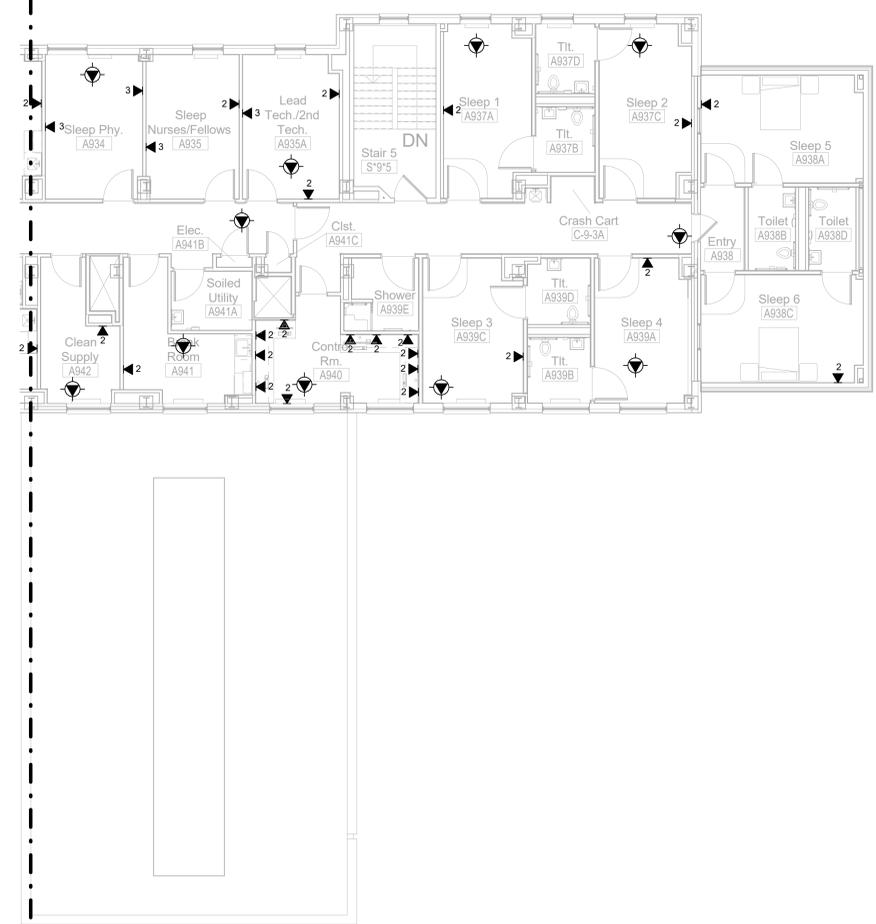

 ① TECHNOLOGY NINTH FLOOR PARTIAL PLAN - D
1/8" = 1'-0"

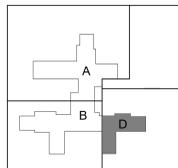

Description	Date	CONSULTANT Ross & Baruzzini LOW VOLTAGE/ IT Ross & Baruzzini Inc. 1600 Riveredge Parkway NW Suite 900 Atlanta, GA 30328	PROJECT MANAGEMENT HFS COMPANY 8718 Botts Lane San Antonio, Texas 78217 www.hfscorporation.com jbianco@hfscorporation.com	 BICSI ID # 124734 Expires 12-31-25 RCDD	Construction and Facilities Management VA U.S. Department of Veterans Affairs	Drawing Title	Phase	Project Title	Project Number
						TECHNOLOGY NINTH FLOOR PARTIAL PLAN - D	100% CONSTRUCTION DOCUMENTS	CINCINNATI VAMC EHRM INFRASTRUCTURE UPGRADES	539-21-701
						Approved: Project Director	FULLY SPRINKLERED	Location	Building Number
								3200 VINE ST. CINCINNATI, OH. 45220	C1
								Issue Date: 04-MAY-2022	Checked By: PR
								Scale: 1/8" = 1'-0"	Drawn By: TL
									Drawing Number
									TN-203-C.1.9



GENERAL NOTES

1. CONTRACTOR SHALL INSTALL BACKBONE RISER SLEEVES OF THE SIZE AS INDICATED ON THE PLANS. REFER TO SECTION 27 15 00 COMMUNICATIONS STRUCTURED CABLING AND SECTION 27 05 33 RACEWAYS AND BOXES FOR COMMUNICATIONS SYSTEMS.
2. CONTRACTOR SHALL X-RAY CONCRETE FLOOR BEFORE CORE DRILLING. CONTRACTOR SHALL COORDINATE WITH THE COR BEFORE BEGINNING DRILLING.
3. CONTRACTOR SHALL FIRESTOP RISER SLEEVES AND EMPTY SPARE RISER SLEEVES. REFER TO SECTION 07 84 00 FIRESTOPPING.
4. CONTRACTOR SHALL INSTALL AN VERTICAL LADDER TYPE CABLE TRAY ON THE WALL ABOVE THE VERTICAL RISER SLEEVES FOR BACKBONE CABLE SUPPORT AS INDICATED ON THE PLANS. THE CABLE TRAY SHALL BE SECURELY ANCHORED TO THE WALL SUFFICIENT TO SUPPORT THE TOTAL WEIGHT OF CABLES AND CABLE TRAY PLUS 50%.
5. CONTRACTOR SHALL INSTALL CABLE SUPPORTS SUFFICIENT TO SUPPORT COMMUNICATIONS CABLES ON THE VERTICAL CABLE TRAY WITHOUT DAMAGING OR DEFORMING THE CABLE.
6. CONTRACTOR SHALL LABEL EACH CABLE AT 42 INCHES A.F.F. ON EACH FLOOR. REFER TO SECTION 27 15 00 COMMUNICATIONS STRUCTURED CABLING.
7. CONTRACTOR SHALL INSTALL NEW J-HOOKS WHERE THERE IS NO CABLE TRAY OR COMMUNICATIONS CONDUIT UNLESS OTHERWISE NOTED.
8. CONTRACTOR SHALL INSTALL NEW CATEGORY 6A PATCH PANELS IN THE TELECOMMUNICATION ROOM AS INDICATED ON RACK ELEVATIONS.
9. CONTRACTOR SHALL RE-TERMINATE AND TEST CABLING REMOVED FROM ANY WALL MOUNT EQUIPMENT UNLESS OTHERWISE NOTED. TESTING SHALL BE PERFORMED BY THE CONTRACTOR DURING COMMISSIONING.
10. CONTRACTOR SHALL INSTALL NEW CATEGORY 6A TELECOMMUNICATIONS/DATA OUTLET AS INDICATED. EXISTING COMMUNICATION OUTLET BOXES AND CONDUITS TO BE REUSED.
11. CONTRACTOR SHALL REPLACE ALL DATA CABLE WITH NEW CATEGORY 6A CABLE UNLESS OTHERWISE NOTED.
12. CONTRACTOR SHALL TERMINATE COMMUNICATIONS CABLES WITH NEW CATEGORY 6A CABLES TO MATCH THE COMMUNICATION CABLE PERFORMANCE SPECIFICATIONS. NEW MODULAR JACKS SHALL BE OF THE SAME MANUFACTURER AS THE FACE PLATES, PATCH PANELS, AND PATCH CABLES.
13. CONTRACTOR SHALL INSTALL NEW CATEGORY 6A CABLES AND CONNECTIVITY COMPONENTS THAT ARE OF THE SAME MANUFACTURER, INCLUDING CABLE, MODULAR JACKS, PATCH PANELS, FACEPLATES, AND PATCH CABLES.
14. CONTRACTOR SHALL TEST ALL NEW AND EXISTING RE-TERMINATED CABLES IN ACCORDANCE WITH THE SPECIFICATION 27 08 00.


KEYED NOTES

1. BACKBONE RISER CEILING PENETRATION
2. FIREWALL PENETRATION
3. 12 INCH X 4 INCH WIRE MESH CABLE TRAY
4. 18 INCH X 4 INCH WIRE MESH CABLE TRAY
5. 24 INCH X 4 INCH WIRE MESH CABLE TRAY
6. SLEEVES IN FLOOR ABOVE.
7. (2) 4" DIAMETER SLEEVES
8. (2) 2" DIAMETER SLEEVES
9. (2) 1-1/2" DIAMETER SLEEVES

KEY PLAN

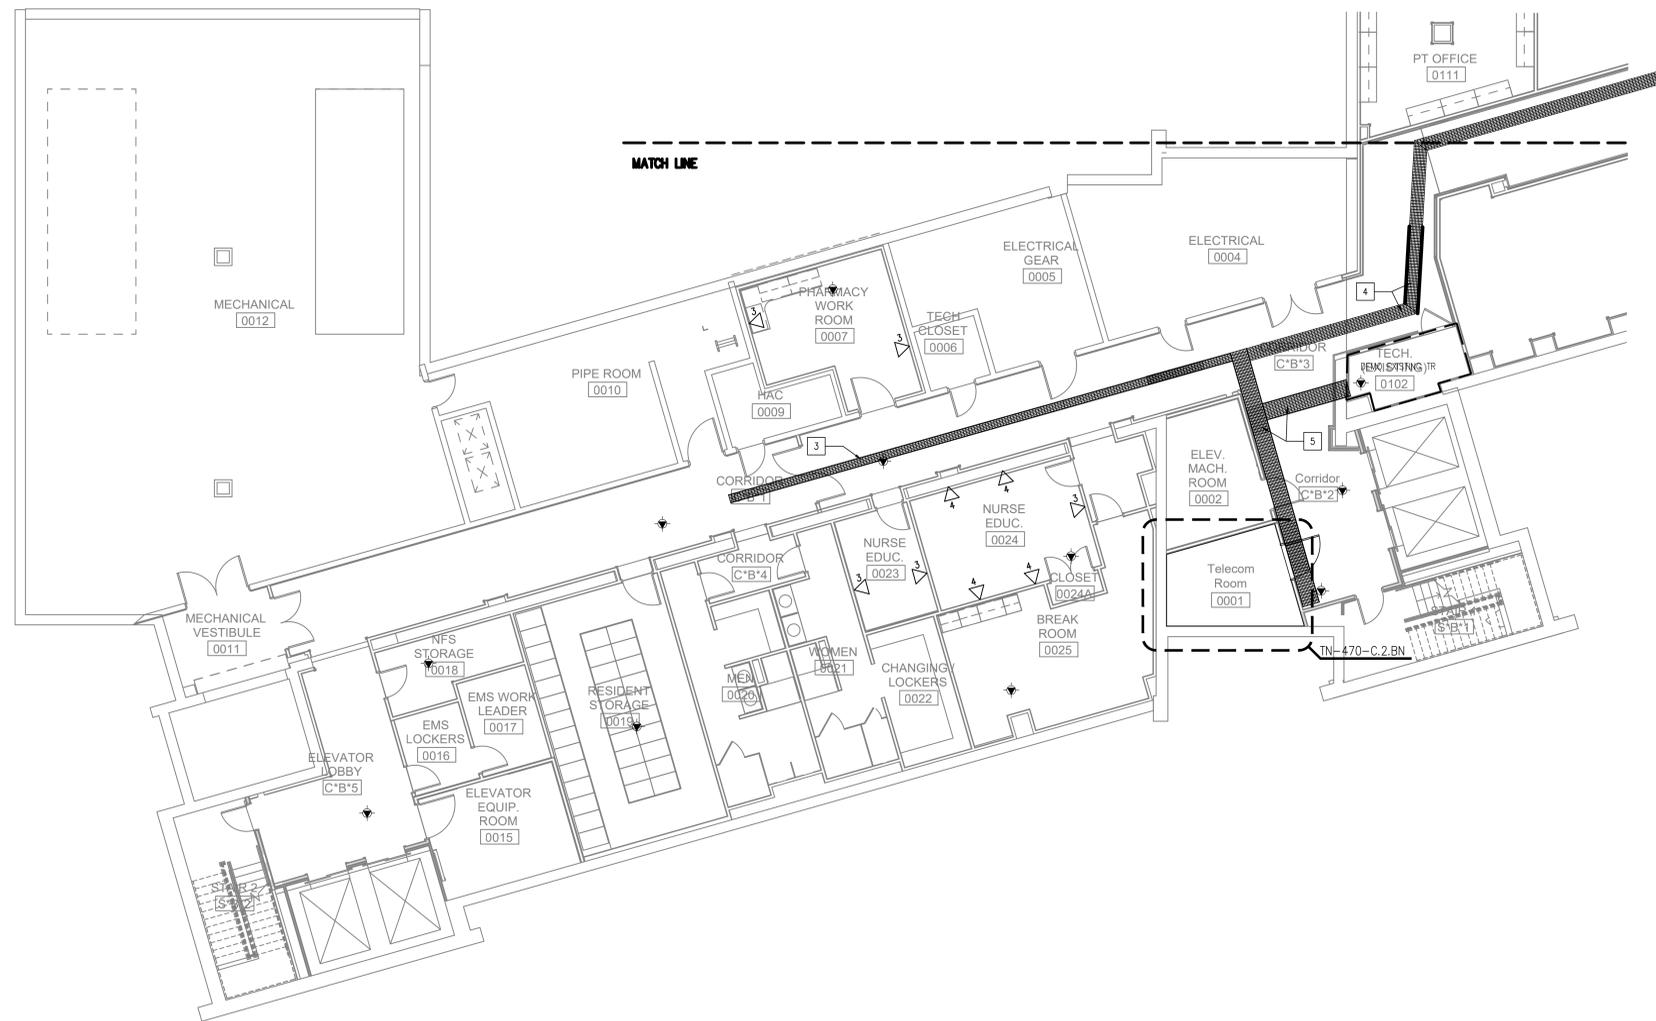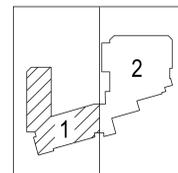

 1 FLOOR PLAN - BLDG. 2 - BASEMENT - NORTH
SCALE: 1/8" = 1'-0"



Revisions:	Date:

CONSULTANT

HFS

C O M P A N Y

8718 Botts Lane Phone: (210) 816-4784
San Antonio, Texas 78217 Fax: (210) 881-6808
www.hfscompany.com jbianco@hfscompany.com

PROJECT MANAGEMENT

HFS

C O M P A N Y

8718 Botts Lane Phone: (210) 816-4784
San Antonio, Texas 78217 Fax: (210) 881-6808
www.hfscompany.com jbianco@hfscompany.com

REGISTERED COMMUNICATIONS DISTRIBUTION DESIGNER

Bicsi

Raymond Martinez Jr.
BICSID # 143493
EXPIRES 12-31-24

RCDD

04-MAY-22

Construction and Facilities Management

VA U.S. Department of Veterans Affairs

Drawing Title
**BLDG. 2 - BASEMENT - NORTH
TECHNOLOGY DATA OUTLET PLAN**

Approved: Project Director

Phase
100% CONSTRUCTION DOCUMENTS

FULLY SPRINKLERED

Project Title
**CINCINNATI VAMC EHRM
INFRASTRUCTURE UPGRADES**

Location
3200 VINE ST., CINCINNATI, OH

Issue Date
04-MAY-2022


Checked
NA

Drawn
RMjr

Project Number
539-21-701

Building Number
2

Drawing Number
TN-210-C.2.BN

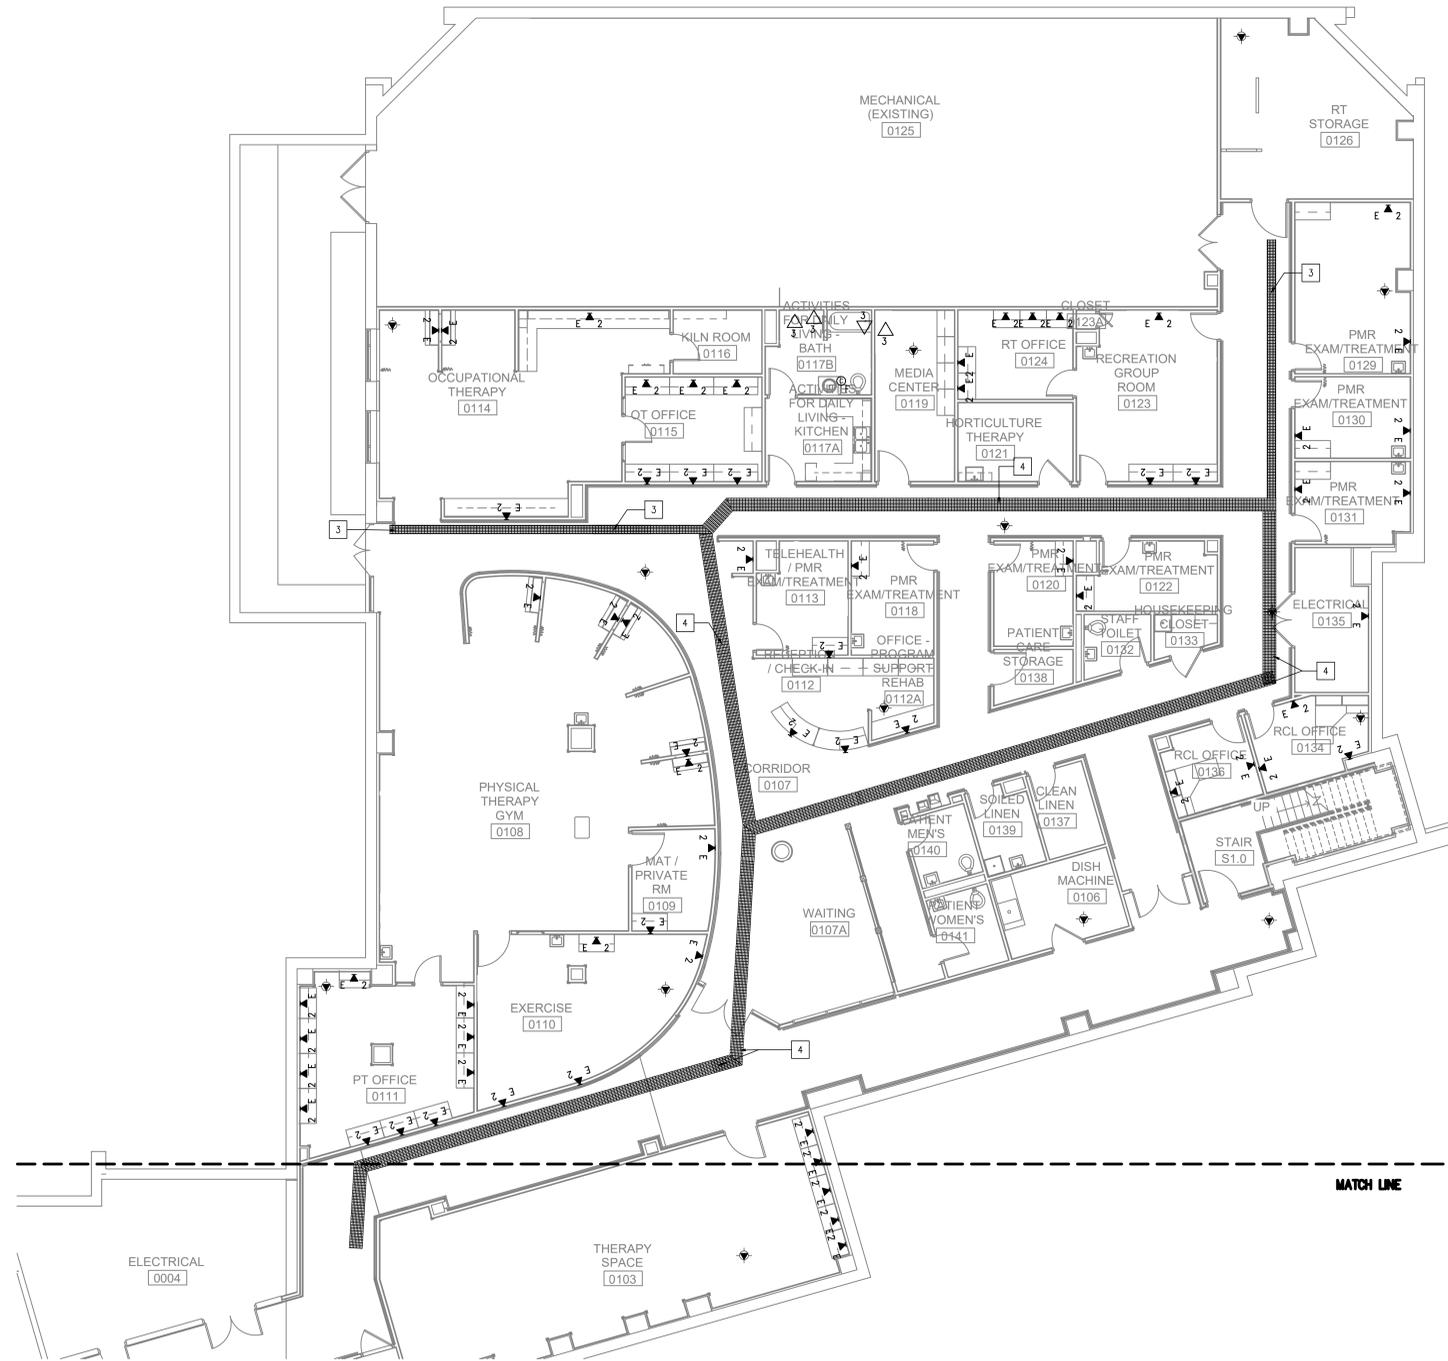


GENERAL NOTES

1. CONTRACTOR SHALL INSTALL BACKBONE RISER SLEEVES OF THE SIZE AS INDICATED ON THE PLANS. REFER TO SECTION 27 15 00 COMMUNICATIONS STRUCTURED CABLING AND SECTION 27 05 33 RACEWAYS AND BOXES FOR COMMUNICATIONS SYSTEMS.
2. CONTRACTOR SHALL X-RAY CONCRETE FLOOR BEFORE CORE DRILLING. CONTRACTOR SHALL COORDINATE WITH THE COR BEFORE BEGINNING DRILLING.
3. CONTRACTOR SHALL FIRESTOP RISER SLEEVES AND EMPTY SPARE RISER SLEEVES. REFER TO SECTION 07 84 00 FIRESTOPPING.
4. CONTRACTOR SHALL INSTALL AN VERTICAL LADDER TYPE CABLE TRAY ON THE WALL ABOVE THE VERTICAL RISER SLEEVES FOR BACKBONE CABLE SUPPORT AS INDICATED ON THE PLANS. THE CABLE TRAY SHALL BE SECURELY ANCHORED TO THE WALL SUFFICIENT TO SUPPORT THE TOTAL WEIGHT OF CABLES AND CABLE TRAY PLUS 50%.
5. CONTRACTOR SHALL INSTALL CABLE SUPPORTS SUFFICIENT TO SUPPORT COMMUNICATIONS CABLES ON THE VERTICAL CABLE TRAY WITHOUT DAMAGING OR DEFORMING THE CABLE.
6. CONTRACTOR SHALL LABEL EACH CABLE AT 42 INCHES A.F.F. ON EACH FLOOR. REFER TO SECTION 27 15 00 COMMUNICATIONS STRUCTURED CABLING.
7. CONTRACTOR SHALL INSTALL NEW J-HOOKS WHERE THERE IS NO CABLE TRAY OR COMMUNICATIONS CONDUIT UNLESS OTHERWISE NOTED.
8. CONTRACTOR SHALL INSTALL NEW CATEGORY 6A PATCH PANELS IN THE TELECOMMUNICATION ROOM AS INDICATED ON RACK ELEVATIONS.
9. CONTRACTOR SHALL RE-TERMINATE AND TEST CABLING REMOVED FROM ANY WALL MOUNT EQUIPMENT UNLESS OTHERWISE NOTED. TESTING SHALL BE PERFORMED BY THE CONTRACTOR DURING COMMISSIONING.
10. CONTRACTOR SHALL INSTALL NEW CATEGORY 6A TELECOMMUNICATIONS/DATA OUTLET AS INDICATED. EXISTING COMMUNICATION OUTLET BOXES AND CONDUITS TO BE REUSED.
11. CONTRACTOR SHALL REPLACE ALL DATA CABLE WITH NEW CATEGORY 6A CABLE UNLESS OTHERWISE NOTED.
12. CONTRACTOR SHALL TERMINATE COMMUNICATIONS CABLES WITH NEW CATEGORY MODULAR JACKS TO MATCH THE COMMUNICATION CABLE PERFORMANCE SPECIFICATIONS. NEW MODULAR JACKS SHALL BE OF THE SAME MANUFACTURER AS THE FACE PLATES, PATCH PANELS, AND PATCH CABLES.
13. CONTRACTOR SHALL INSTALL NEW CATEGORY 6A CABLES AND CONNECTIVITY COMPONENTS THAT ARE OF THE SAME MANUFACTURER, INCLUDING CABLE, MODULAR JACKS, PATCH PANELS, FACEPLATES, AND PATCH CABLES.
14. CONTRACTOR SHALL TEST ALL NEW AND EXISTING RE-TERMINATED CABLES IN ACCORDANCE WITH THE SPECIFICATION 27 08 00.


KEYED NOTES

1. BACKBONE RISER CEILING PENETRATION
2. FIREWALL PENETRATION
3. 12 INCH X 4 INCH WIRE MESH CABLE TRAY
4. 18 INCH X 4 INCH WIRE MESH CABLE TRAY
5. 24 INCH X 4 INCH WIRE MESH CABLE TRAY
6. SLEEVES IN FLOOR ABOVE.
7. (2) 4" DIAMETER SLEEVES
8. (2) 2" DIAMETER SLEEVES
9. (2) 1-1/2" DIAMETER SLEEVES

KEY PLAN

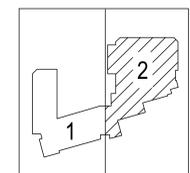

 1 FLOOR PLAN - BLDG. 2 - BASEMENT - SOUTH
SCALE: 1/8" = 1'-0"



Revisions:	Date:

CONSULTANT

HFS COMPANY

8718 Botts Lane
San Antonio, Texas 78217
www.hfscompany.com

Phone: (210) 816-4784
Fax: (210) 881-6808
jbianco@hfscompany.com

PROJECT MANAGEMENT

HFS COMPANY

8718 Botts Lane
San Antonio, Texas 78217
www.hfscompany.com

Phone: (210) 816-4784
Fax: (210) 881-6808
jbianco@hfscompany.com

COMMUNICATIONS DISTRIBUTION DESIGNER

Bicsi
Raymond Martinez Jr.
BICSI ID # 143495
EXPIRES 12-31-24
RCDD
04-MAY-22

Construction and Facilities Management

VA U.S. Department of Veterans Affairs

Drawing Title
BLDG. 2 - BASEMENT - SOUTH TECHNOLOGY DATA OUTLET PLAN

Approved: Project Director

Phase
100% CONSTRUCTION DOCUMENTS

FULLY SPRINKLERED

Project Title
CINCINNATI VAMC EHRM INFRASTRUCTURE UPGRADES

Location
3200 VINE ST., CINCINNATI, OH

Issue Date
04-MAY-2022

Checked
NA

Drawn
RMjr

Project Number
539-21-701

Building Number
2

Drawing Number
TN-210-C.2.BS




GENERAL NOTES

1. CONTRACTOR SHALL INSTALL BACKBONE RISER SLEEVES OF THE SIZE AS INDICATED ON THE PLANS. REFER TO SECTION 27 15 00 COMMUNICATIONS STRUCTURED CABLING AND SECTION 27 05 33 RACEWAYS AND BOXES FOR COMMUNICATIONS SYSTEMS.
2. CONTRACTOR SHALL X-RAY CONCRETE FLOOR BEFORE CORE DRILLING. CONTRACTOR SHALL COORDINATE WITH THE COR BEFORE BEGINNING DRILLING.
3. CONTRACTOR SHALL FIRESTOP RISER SLEEVES AND EMPTY SPARE RISER SLEEVES. REFER TO SECTION 07 84 00 FIRESTOPPING.
4. CONTRACTOR SHALL INSTALL AN VERTICAL LADDER TYPE CABLE TRAY ON THE WALL ABOVE THE VERTICAL RISER SLEEVES FOR BACKBONE CABLE SUPPORT AS INDICATED ON THE PLANS. THE CABLE TRAY SHALL BE SECURELY ANCHORED TO THE WALL SUFFICIENT TO SUPPORT THE TOTAL WEIGHT OF CABLES AND CABLE TRAY PLUS 50%.
5. CONTRACTOR SHALL INSTALL CABLE SUPPORTS SUFFICIENT TO SUPPORT COMMUNICATIONS CABLES ON THE VERTICAL CABLE TRAY WITHOUT DAMAGING OR DEFORMING THE CABLE.
6. CONTRACTOR SHALL LABEL EACH CABLE AT 42 INCHES A.F.F. ON EACH FLOOR. REFER TO SECTION 27 15 00 COMMUNICATIONS STRUCTURED CABLING.
7. CONTRACTOR SHALL INSTALL NEW J-HOOKS WHERE THERE IS NO CABLE TRAY OR COMMUNICATIONS CONDUIT UNLESS OTHERWISE NOTED.
8. CONTRACTOR SHALL INSTALL NEW CATEGORY 6A PATCH PANELS IN THE TELECOMMUNICATION ROOM AS INDICATED ON RACK ELEVATIONS.
9. CONTRACTOR SHALL RE-TERMINATE AND TEST CABLING REMOVED FROM ANY WALL MOUNT EQUIPMENT UNLESS OTHERWISE NOTED. TESTING SHALL BE PERFORMED BY THE CONTRACTOR DURING COMMISSIONING.
10. CONTRACTOR SHALL INSTALL NEW CATEGORY 6A TELECOMMUNICATIONS/DATA OUTLET AS INDICATED. EXISTING COMMUNICATION OUTLET BOXES AND CONDUITS TO BE REUSED.
11. CONTRACTOR SHALL REPLACE ALL DATA CABLE WITH NEW CATEGORY 6A CABLE UNLESS OTHERWISE NOTED.
12. CONTRACTOR SHALL TERMINATE COMMUNICATIONS CABLES WITH NEW CATEGORY MODULAR JACKS TO MATCH THE COMMUNICATION CABLE PERFORMANCE SPECIFICATIONS. NEW MODULAR JACKS SHALL BE OF THE SAME MANUFACTURER AS THE FACE PLATES, PATCH PANELS, AND PATCH CABLES.
13. CONTRACTOR SHALL INSTALL NEW CATEGORY 6A CABLES AND CONNECTIVITY COMPONENTS THAT ARE OF THE SAME MANUFACTURER, INCLUDING CABLE, MODULAR JACKS, PATCH PANELS, FACEPLATES, AND PATCH CABLES.
14. CONTRACTOR SHALL TEST ALL NEW AND EXISTING RE-TERMINATED CABLES IN ACCORDANCE WITH THE SPECIFICATION 27 08 00.


KEYED NOTES

1. BACKBONE RISER CEILING PENETRATION
2. FIREWALL PENETRATION
3. 12 INCH X 4 INCH WIRE MESH CABLE TRAY
4. 18 INCH X 4 INCH WIRE MESH CABLE TRAY
5. 24 INCH X 4 INCH WIRE MESH CABLE TRAY
6. SLEEVES IN FLOOR ABOVE.
7. (2) 4" DIAMETER SLEEVES
8. (2) 2" DIAMETER SLEEVES
9. (2) 1-1/2" DIAMETER SLEEVES

KEY PLAN

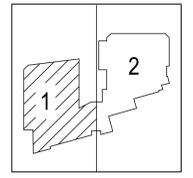

 1 FLOOR PLAN - BLDG. 2 - FIRST FLOOR - NORTH
SCALE: 1/8" = 1'-0"



Revisions:	Date:

CONSULTANT

HFS

COMPANY

8718 Botts Lane Phone: (210) 816-4784
San Antonio, Texas 78217 Fax: (210) 881-6808
www.hfscorporation.com jbianco@hfscorporation.com

PROJECT MANAGEMENT

HFS

COMPANY

8718 Botts Lane Phone: (210) 816-4784
San Antonio, Texas 78217 Fax: (210) 881-6808
www.hfscorporation.com jbianco@hfscorporation.com

REGISTERED COMMUNICATIONS DISTRIBUTION DESIGNER

Bicsi

Raymond Martinez Jr.
BICSI ID # 143493
Expires 12-31-24
RCDD
04-MAY-22

Construction and Facilities Management

VA U.S. Department of Veterans Affairs

Drawing Title
BLDG. 2 - FIRST FLOOR - NORTH TECHNOLOGY DATA OUTLET PLAN

Approved: Project Director

Phase
100% CONSTRUCTION DOCUMENTS

FULLY SPRINKLERED

Project Title
CINCINNATI VAMC EHRM INFRASTRUCTURE UPGRADES

Location
3200 VINE ST., CINCINNATI, OH

Issue Date
04-MAY-2022


Checked
NA

Drawn
RMjr

Project Number
539-21-701

Building Number
2

Drawing Number
TN-211-C.2.1N

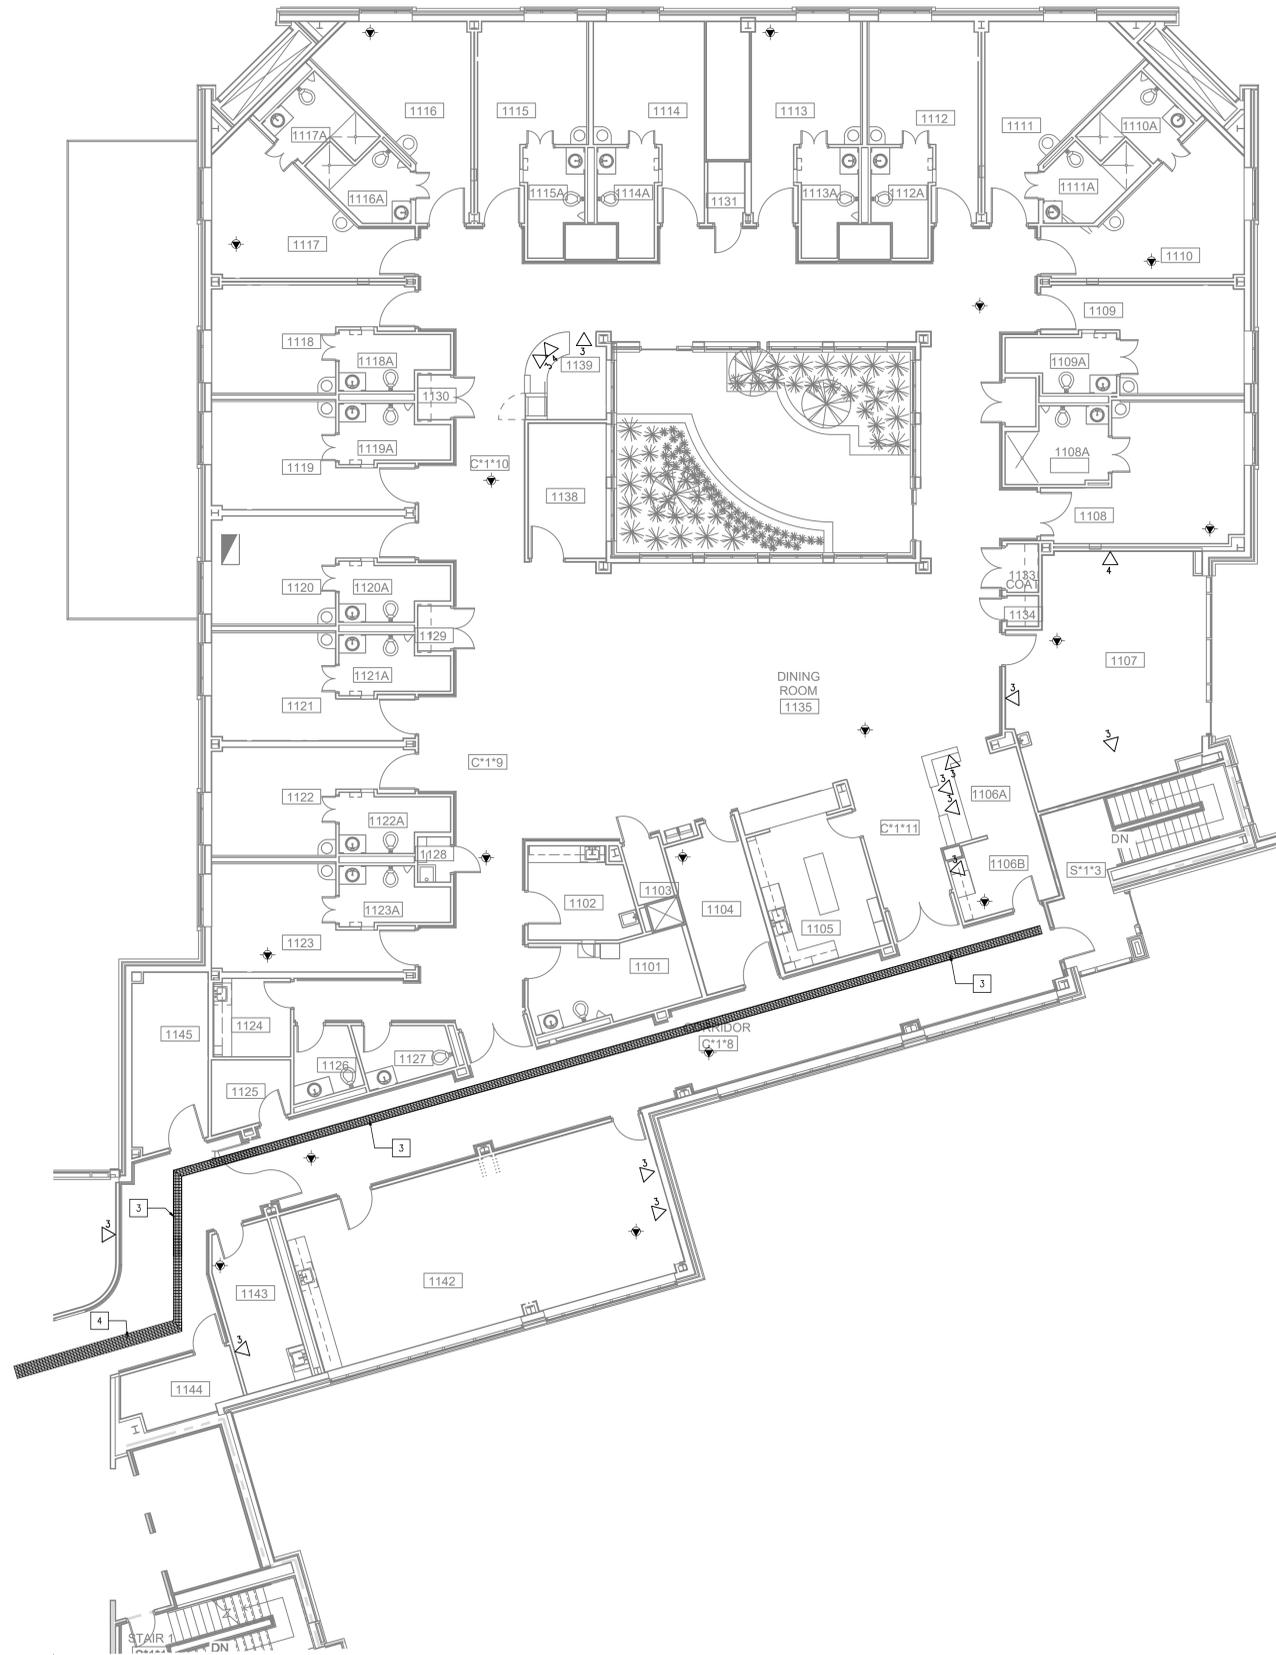



GENERAL NOTES

1. CONTRACTOR SHALL INSTALL BACKBONE RISER SLEEVES OF THE SIZE AS INDICATED ON THE PLANS. REFER TO SECTION 27 15 00 COMMUNICATIONS STRUCTURED CABLING AND SECTION 27 05 33 RACEWAYS AND BOXES FOR COMMUNICATIONS SYSTEMS.
2. CONTRACTOR SHALL X-RAY CONCRETE FLOOR BEFORE CORE DRILLING. CONTRACTOR SHALL COORDINATE WITH THE COR BEFORE BEGINNING DRILLING.
3. CONTRACTOR SHALL FIRESTOP RISER SLEEVES AND EMPTY SPARE RISER SLEEVES. REFER TO SECTION 07 84 00 FIRESTOPPING.
4. CONTRACTOR SHALL INSTALL AN VERTICAL LADDER TYPE CABLE TRAY ON THE WALL ABOVE THE VERTICAL RISER SLEEVES FOR BACKBONE CABLE SUPPORT AS INDICATED ON THE PLANS. THE CABLE TRAY SHALL BE SECURELY ANCHORED TO THE WALL SUFFICIENT TO SUPPORT THE TOTAL WEIGHT OF CABLES AND CABLE TRAY PLUS 50%.
5. CONTRACTOR SHALL INSTALL CABLE SUPPORTS SUFFICIENT TO SUPPORT COMMUNICATIONS CABLES ON THE VERTICAL CABLE TRAY WITHOUT DAMAGING OR DEFORMING THE CABLE.
6. CONTRACTOR SHALL LABEL EACH CABLE AT 42 INCHES A.F.F. ON EACH FLOOR. REFER TO SECTION 27 15 00 COMMUNICATIONS STRUCTURED CABLING.
2. CONTRACTOR SHALL INSTALL NEW J-HOOKS WHERE THERE IS NO CABLE TRAY OR COMMUNICATIONS CONDUIT UNLESS OTHERWISE NOTED.
3. CONTRACTOR SHALL INSTALL NEW CATEGORY 6A PATCH PANELS IN THE TELECOMMUNICATION ROOM AS INDICATED ON RACK ELEVATIONS.
4. CONTRACTOR SHALL RE-TERMINATE AND TEST CABLING REMOVED FROM ANY WALL MOUNT EQUIPMENT UNLESS OTHERWISE NOTED. TESTING SHALL BE PERFORMED BY THE CONTRACTOR DURING COMMISSIONING.
5. CONTRACTOR SHALL INSTALL NEW CATEGORY 6A TELECOMMUNICATIONS/DATA OUTLET AS INDICATED. EXISTING COMMUNICATION OUTLET BOXES AND CONDUITS TO BE REUSED.
6. CONTRACTOR SHALL REPLACE ALL DATA CABLE WITH NEW CATEGORY 6A CABLE UNLESS OTHERWISE NOTED.
7. CONTRACTOR SHALL TERMINATE COMMUNICATIONS CABLES WITH NEW CATEGORY MODULAR JACKS TO MATCH THE COMMUNICATION CABLE PERFORMANCE SPECIFICATIONS. NEW MODULAR JACKS SHALL BE OF THE SAME MANUFACTURER AS THE FACE PLATES, PATCH PANELS, AND PATCH CABLES.
8. CONTRACTOR SHALL INSTALL NEW CATEGORY 6A CABLES AND CONNECTIVITY COMPONENTS THAT ARE OF THE SAME MANUFACTURER, INCLUDING CABLE, MODULAR JACKS, PATCH PANELS, FACEPLATES, AND PATCH CABLES.
9. CONTRACTOR SHALL TEST ALL NEW AND EXISTING RE-TERMINATED CABLES IN ACCORDANCE WITH THE SPECIFICATION 27 08 00.

KEYED NOTES

1. BACKBONE RISER CEILING PENETRATION
2. FIREWALL PENETRATION
3. 12 INCH X 4 INCH WIRE MESH CABLE TRAY
4. 18 INCH X 4 INCH WIRE MESH CABLE TRAY
5. 24 INCH X 4 INCH WIRE MESH CABLE TRAY
6. SLEEVES IN FLOOR ABOVE.
7. (2) 4" DIAMETER SLEEVES
8. (2) 2" DIAMETER SLEEVES
9. (2) 1-1/2" DIAMETER SLEEVES

 KEY PLAN

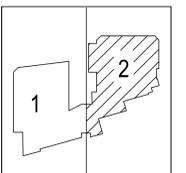

1 FLOOR PLAN - BLDG. 2 - FIRST FLOOR - SOUTH
SCALE: 1/8" = 1'-0"

Revisions:	Date:

CONSULTANT

8718 Botts Lane
San Antonio, Texas 78217
www.hfscompany.com

Phone: (210) 816-4784
Fax: (210) 881-6808
jbianco@hfscompany.com

PROJECT MANAGEMENT

8718 Botts Lane
San Antonio, Texas 78217
www.hfscompany.com

Phone: (210) 816-4784
Fax: (210) 881-6808
jbianco@hfscompany.com

Bicsi
Raymond Martinez Jr.
BICSI ID # 143493
Expires 12-31-24
RCDD
04-MAY-22

Construction and Facilities Management

Drawing Title
BLDG. 2 - FIRST FLOOR - SOUTH TECHNOLOGY DATA OUTLET PLAN

Approved: Project Director

Phase
100% CONSTRUCTION DOCUMENTS

FULLY SPRINKLERED

Project Title
CINCINNATI VAMC EHRM INFRASTRUCTURE UPGRADES

Location
3200 VINE ST., CINCINNATI, OH

Issue Date
04-MAY-2022

Checked
NA

Drawn
RMjr

Project Number
539-21-701

Building Number
2

Drawing Number
TN-211-C.2.1S



GENERAL NOTES

1. CONTRACTOR SHALL INSTALL BACKBONE RISER SLEEVES OF THE SIZE AS INDICATED ON THE PLANS. REFER TO SECTION 27 15 00 COMMUNICATIONS STRUCTURED CABLING AND SECTION 27 05 33 RACEWAYS AND BOXES FOR COMMUNICATIONS SYSTEMS.
2. CONTRACTOR SHALL X-RAY CONCRETE FLOOR BEFORE CORE DRILLING. CONTRACTOR SHALL COORDINATE WITH THE COR BEFORE BEGINNING DRILLING.
3. CONTRACTOR SHALL FIRESTOP RISER SLEEVES AND EMPTY SPARE RISER SLEEVES. REFER TO SECTION 07 84 00 FIRESTOPPING.
4. CONTRACTOR SHALL INSTALL AN VERTICAL LADDER TYPE CABLE TRAY ON THE WALL ABOVE THE VERTICAL RISER SLEEVES FOR BACKBONE CABLE SUPPORT AS INDICATED ON THE PLANS. THE CABLE TRAY SHALL BE SECURELY ANCHORED TO THE WALL SUFFICIENT TO SUPPORT THE TOTAL WEIGHT OF CABLES AND CABLE TRAY PLUS 50%.
5. CONTRACTOR SHALL INSTALL CABLE SUPPORTS SUFFICIENT TO SUPPORT COMMUNICATIONS CABLES ON THE VERTICAL CABLE TRAY WITHOUT DAMAGING OR DEFORMING THE CABLE.
6. CONTRACTOR SHALL LABEL EACH CABLE AT 42 INCHES A.F.F. ON EACH FLOOR. REFER TO SECTION 27 15 00 COMMUNICATIONS STRUCTURED CABLING.
7. CONTRACTOR SHALL INSTALL NEW J-HOOKS WHERE THERE IS NO CABLE TRAY OR COMMUNICATIONS CONDUIT UNLESS OTHERWISE NOTED.
8. CONTRACTOR SHALL INSTALL NEW CATEGORY 6A PATCH PANELS IN THE TELECOMMUNICATION ROOM AS INDICATED ON RACK ELEVATIONS.
9. CONTRACTOR SHALL RE-TERMINATE AND TEST CABLING REMOVED FROM ANY WALL MOUNT EQUIPMENT UNLESS OTHERWISE NOTED. TESTING SHALL BE PERFORMED BY THE CONTRACTOR DURING COMMISSIONING.
10. CONTRACTOR SHALL INSTALL NEW CATEGORY 6A TELECOMMUNICATIONS/DATA OUTLET AS INDICATED. EXISTING COMMUNICATION OUTLET BOXES AND CONDUITS TO BE REUSED.
11. CONTRACTOR SHALL REPLACE ALL DATA CABLE WITH NEW CATEGORY 6A CABLE UNLESS OTHERWISE NOTED.
12. CONTRACTOR SHALL TERMINATE COMMUNICATIONS CABLES WITH NEW CATEGORY 6A MODULAR JACKS TO MATCH THE COMMUNICATION CABLE PERFORMANCE SPECIFICATIONS. NEW MODULAR JACKS SHALL BE OF THE SAME MANUFACTURER AS THE FACE PLATES, PATCH PANELS, AND PATCH CABLES.
13. CONTRACTOR SHALL INSTALL NEW CATEGORY 6A CABLES AND CONNECTIVITY COMPONENTS THAT ARE OF THE SAME MANUFACTURER, INCLUDING CABLE, MODULAR JACKS, PATCH PANELS, FACEPLATES, AND PATCH CABLES.
14. CONTRACTOR SHALL TEST ALL NEW AND EXISTING RE-TERMINATED CABLES IN ACCORDANCE WITH THE SPECIFICATION 27 08 00.


KEYED NOTES

1. BACKBONE RISER CEILING PENETRATION
2. FIREWALL PENETRATION
3. 12 INCH X 4 INCH WIRE MESH CABLE TRAY
4. 18 INCH X 4 INCH WIRE MESH CABLE TRAY
5. 24 INCH X 4 INCH WIRE MESH CABLE TRAY
6. SLEEVES IN FLOOR ABOVE.
7. (2) 4" DIAMETER SLEEVES
8. (2) 2" DIAMETER SLEEVES
9. (2) 1-1/2" DIAMETER SLEEVES

KEY PLAN

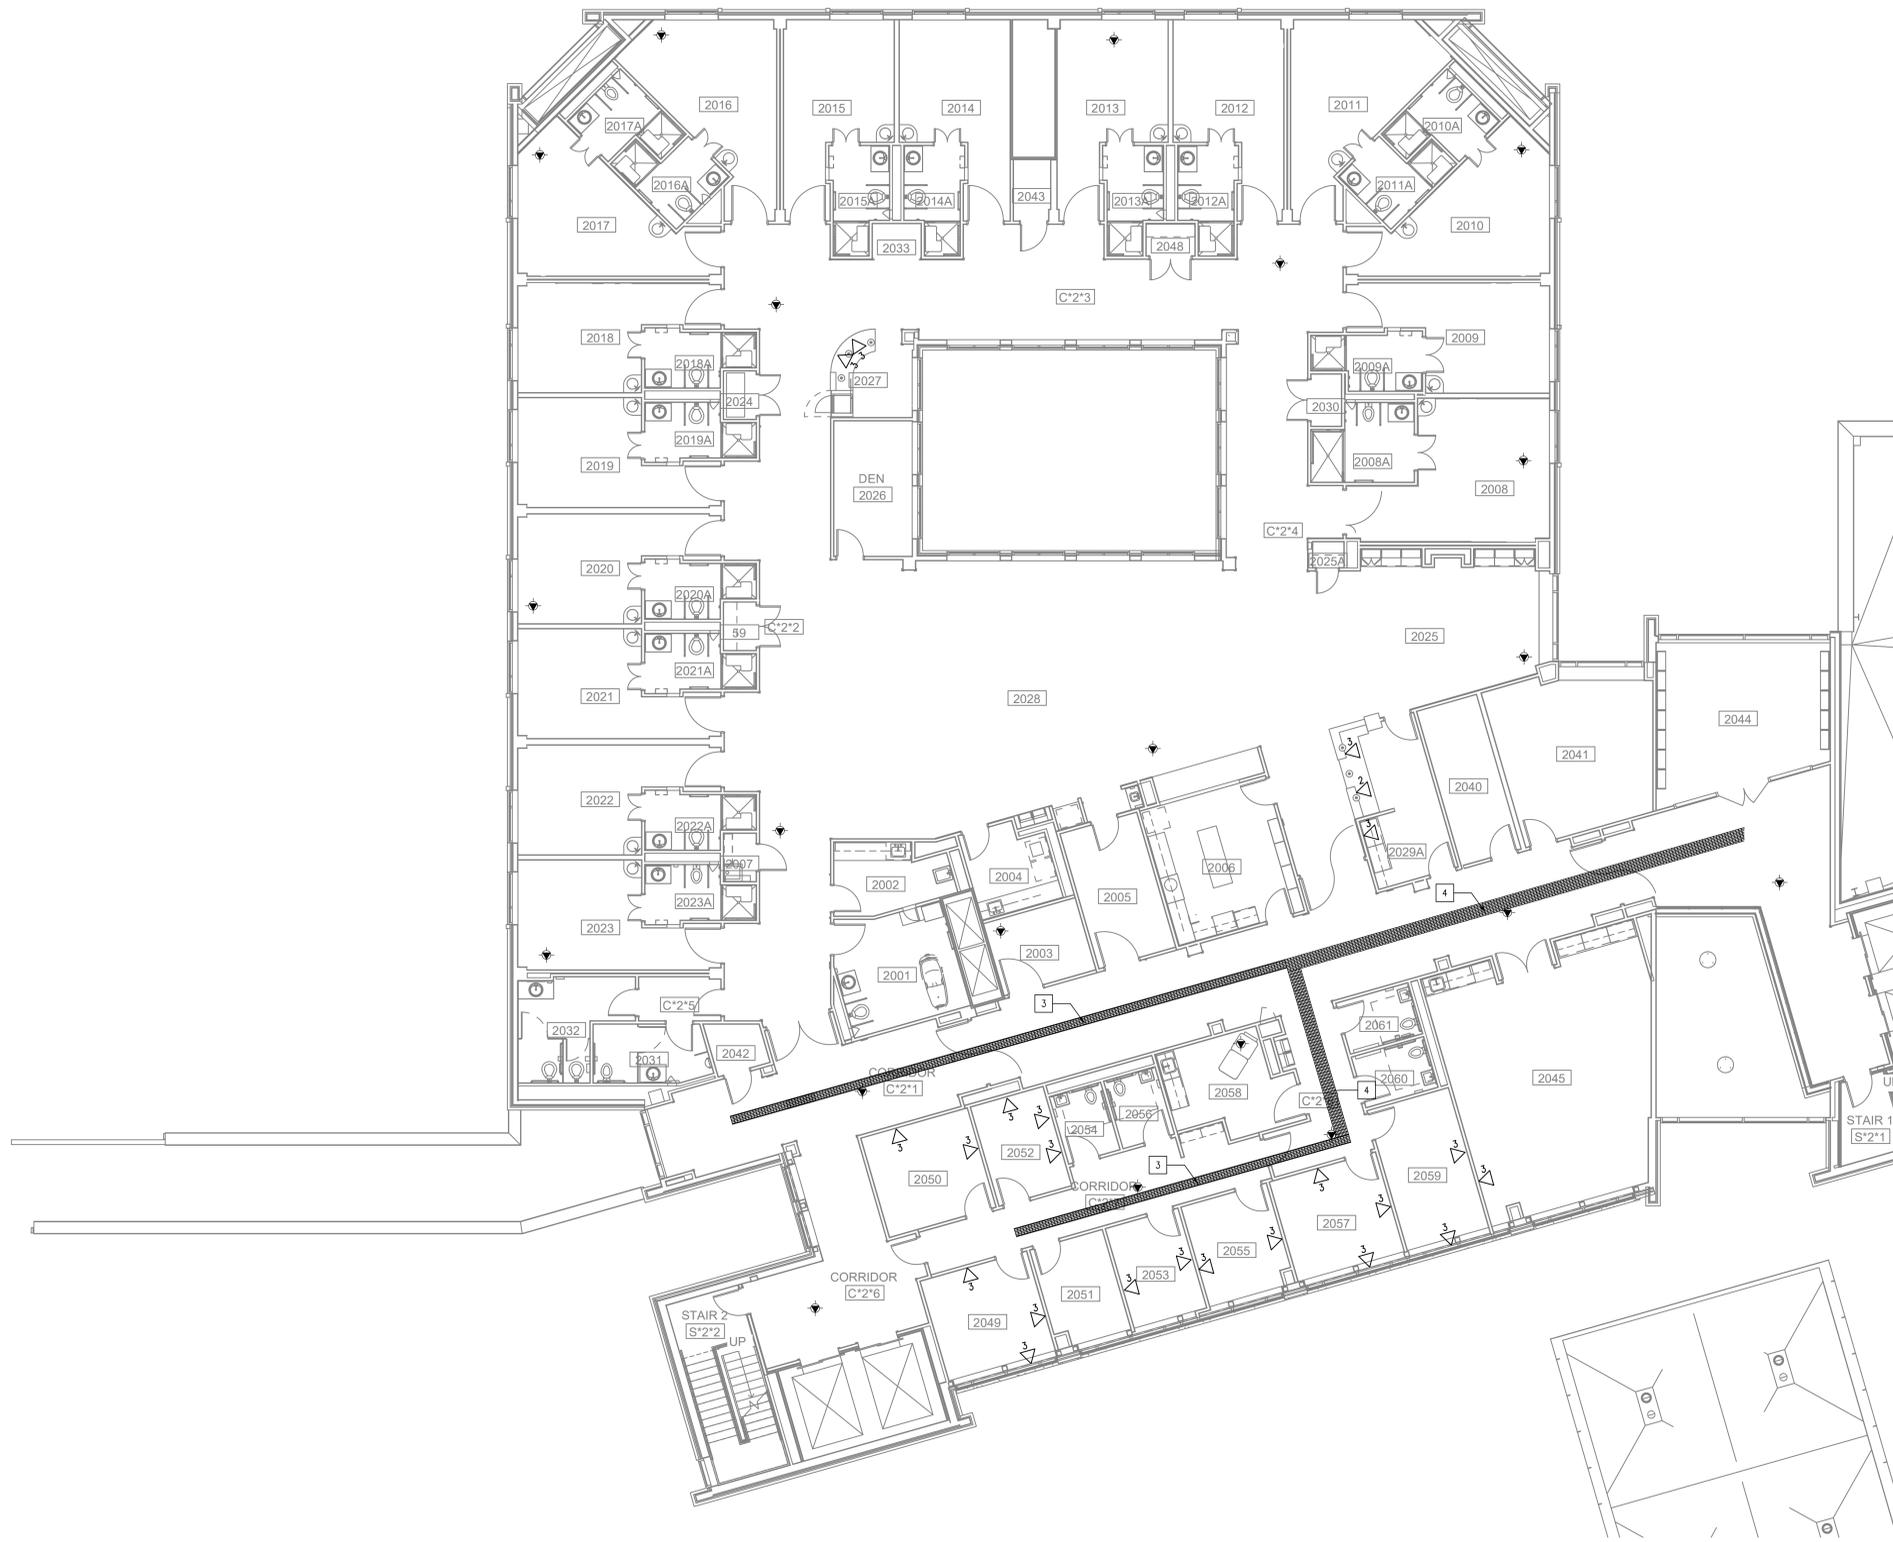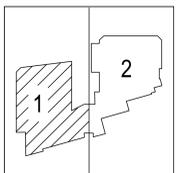

 1 FLOOR PLAN - BLDG. 2 - SECOND FLOOR- NORTH
SCALE: 1/8" = 1'-0"



Revisions:	Date:

CONSULTANT

HFS COMPANY

8718 Botts Lane
San Antonio, Texas 78217
www.hfscompany.com

Phone: (210) 816-4784
Fax: (210) 881-6808
jbianco@hfscompany.com

PROJECT MANAGEMENT

HFS COMPANY

8718 Botts Lane
San Antonio, Texas 78217
www.hfscompany.com

Phone: (210) 816-4784
Fax: (210) 881-6808
jbianco@hfscompany.com

REGISTERED COMMUNICATIONS DISTRIBUTION DESIGNER

Bicsi

Raymond Martinez Jr.
BICSI ID # 143493
Expires 12-31-24
RCDD
04-MAY-22

Construction and Facilities Management

VA U.S. Department of Veterans Affairs

Drawing Title
BLDG. 2 - SECOND FLOOR - NORTH TECHNOLOGY DATA OUTLET PLAN

Approved: Project Director

Phase
100% CONSTRUCTION DOCUMENTS

FULLY SPRINKLERED

Project Title
CINCINNATI VAMC EHRM INFRASTRUCTURE UPGRADES

Location
3200 VINE ST., CINCINNATI, OH

Issue Date
04-MAY-2022

Checked
NA

Drawn
RMjr

Project Number
539-21-701

Building Number
2


Drawing Number
TN-212-C.2.2N

DEMO NOTES

- EXISTING CABLE TRAYS SHALL BE RE-USED UNLESS OTHERWISE NOTED.
- EXISTING J-HOOKS SHALL BE RE-USED UNLESS OTHERWISE NOTED.
- EXISTING TELECOMMUNICATIONS ROOM OR IT CLOSET. CONTRACTOR SHALL DEMO ALL PATCH PANELS AND CABLEING RELATED TO THIS PROJECT. CONTRACTOR SHALL REMOVE ALL DATA CABLES FROM THE DEVICE TO THE SOURCE. CONTRACTOR SHALL COORDINATE WITH THE COR PRIOR TO BEGINNING WORK IN EACH TELECOM ROOM (TR) OR IT CLOSET.
- DO NOT REMOVE ANY WALL MOUNT EQUIPMENT, ELECTRICAL CABLES AND EQUIPMENT, OR ANY CABLEING OR DEVICE THAT IS NOT DATA RELATED. COORDINATE WITH COR PRIOR TO REMOVING CABLEING FROM WALL FIELDS OR FROM WALL MOUNTED EQUIPMENT.
- BUILDING AUTOMATION SYSTEMS (BAS) OR ELECTRONIC SECURITY SYSTEMS CABLES SHALL NOT BE REMOVED. COORDINATE WITH COR TO IDENTIFY BAS OR SECURITY CABLES.
- EXISTING TELECOMMUNICATIONS OUTLET. CONTRACTOR SHALL REMOVE ALL DEVICE FACEPLATES AND MODULAR JACKS. EXISTING OUTLET BOXES AND CONDUITS SHALL BE PRESERVED FOR REUSE.
- CONTRACTOR SHALL REMOVE ALL DATA CABLES EXCEPT CATEGORY 6A OR UNLESS OTHERWISE NOTED. CONTRACTOR SHALL COORDINATE WITH THE COR PRIOR TO REMOVING CABLES, OUTLETS, FACE PLATES, PATCH PANELS, AND PATCH CABLES.
- CABLES SHALL NOT BE ABANDONED IN PLACE WITHOUT PRIOR APPROVAL OF THE COR.
- WHERE CABLES ARE TO BE REMOVED, CONTRACTOR SHALL COMPLETELY REMOVE THE CABLE FROM OUTLET TO PATCH PANEL.
- CONTRACTOR SHALL REMOVE NON-CATEGORY 6/A FACE PLATES, MODULAR JACKS, AND PATCH PANELS AFTER CUT OVER TO NEW CATEGORY 6A CABLE PLANT.
- CABLE SUPPORTS, SUCH AS CABLE TRAYS, OR J-HOOKS, THAT ARE NOT TO BE REUSED SHALL BE PRESERVED FOR REUSE. COORDINATE WITH THE COR PRIOR TO REMOVING CABLE SUPPORTS.
- NURSE CALL SYSTEM TO BE MAINTAINED IN TR ROOM. CONTRACTOR SHALL COORDINATE NEW EQUIPMENT LOCATION WITH THE COR PRIOR TO MOVING THE NURSE CALL SYSTEM OR BEFORE WALL DEMOLITION BEGINS.
- PRIOR TO RELOCATING WALL MOUNTED TV, CONTRACTOR SHALL COORDINATE WITH THE COR FOR THE NEW LOCATION AND PROVIDE NEW CATEGORY 6A DATA AND ELECTRICAL OUTLETS.

SHEET NOTES:


- THIS AREA IS NEW CONSTRUCTION. ALL CABLE AND MODULAR JACKS, AND TERMINATIONS IN THE EXISTING TR-202 ARE CATEGORY 6A. CABLES TERMINATED IN THE EXISTING TR-202 WILL BE REMOVED AND REINSTALLED IN THE NEW TR - RM 204.
- IT IS ANTICIPATED THAT THERE IS SUFFICIENT CABLE LENGTH TO ALLOW THE CABLES TO BE RELOCATED FROM THE EXISTING TR-202 TO TR-205. CONTRACTOR IS RESPONSIBLE FOR VERIFYING THAT THE CABLES CAN BE RELOCATED AND REINSTALLED IN TR-204.
- CATEGORY 6A CABLES AND OUTLETS WILL BE TESTED FOR CERTIFICATION AS PART OF THE COMMISSIONING.

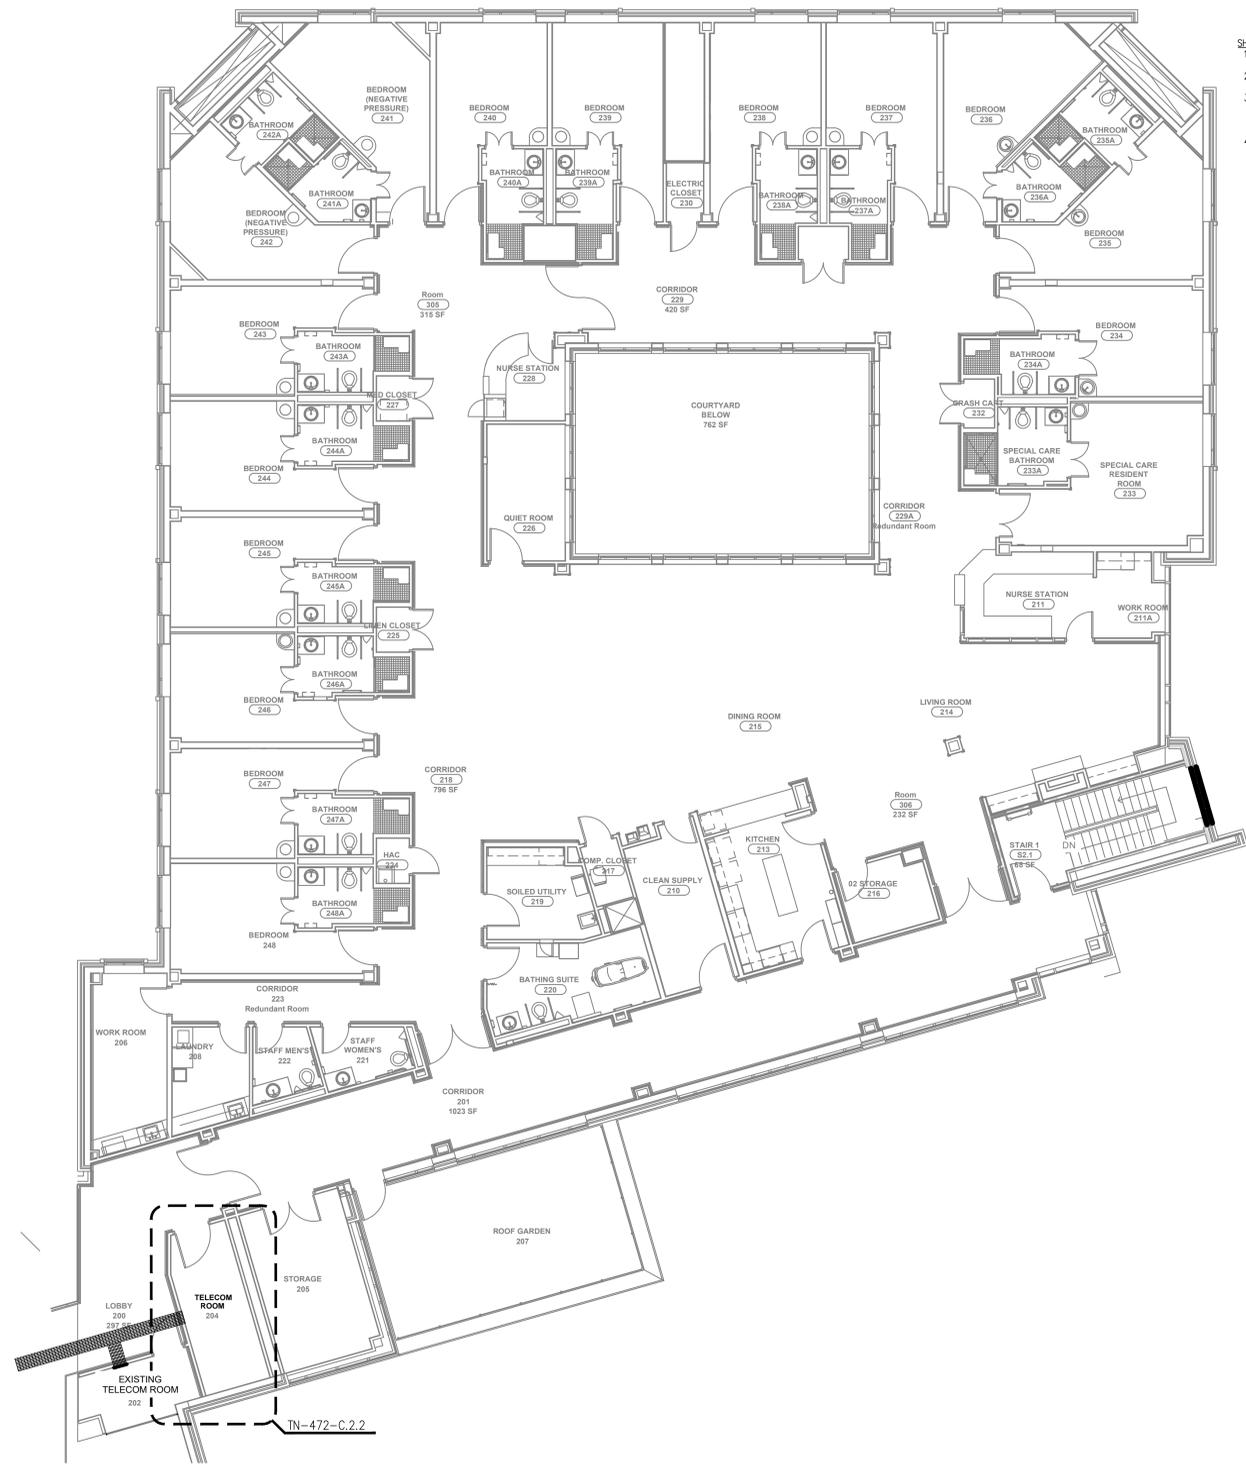

KEYED NOTES

- OUTLET MOUNTED BELOW COUNTER.
- OUTLET MOUNTED ABOVE COUNTER.
- SURFACE MOUNTED, WIREMOLD TYPE RACEWAY
- SURFACE MOUNTED TO UNDERSIDE OF CABLE TRAY.
- CABLE CHASE.
- EXISTING CABLE TRAY

KEY PLAN

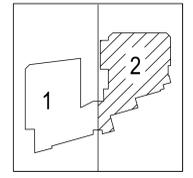

1 FLOOR PLAN - BLDG. 2 - SECOND FLOOR - SOUTH
SCALE: 1/8" = 1'-0"

Revisions:	Date:

CONSULTANT

HFS

COMPANY

8718 Botts Lane
San Antonio, Texas 78217
www.hfscompany.com

Phone: (210) 816-4784
Fax: (210) 881-6808
jbianco@hfscompany.com

PROJECT MANAGEMENT

HFS

COMPANY

8718 Botts Lane
San Antonio, Texas 78217
www.hfscompany.com

Phone: (210) 816-4784
Fax: (210) 881-6808
jbianco@hfscompany.com

REGISTERED COMMUNICATIONS DISTRIBUTION DESIGNER

Bicsi

Raymond Martinez Jr.
BICSI ID # 143493
EXPIRES 12-31-24

RCDD

04-MAY-22

Construction and Facilities Management

VA U.S. Department of Veterans Affairs

Drawing Title
BLDG. 2 - SECOND FLOOR - SOUTH TECHNOLOGY DATA OUTLET PLAN

Approved: Project Director

Phase
100% CONSTRUCTION DOCUMENTS

FULLY SPRINKLERED

Project Title
CINCINNATI VAMC EHRM INFRASTRUCTURE UPGRADES

Location
3200 VINE ST., CINCINNATI, OH

Issue Date
04-MAY-2022

Checked
NA

Drawn
RMjr


Project Number
539-21-701

Building Number
2

Drawing Number
TN-212-C.2.2S

GENERAL NOTES



1. CONTRACTOR SHALL INSTALL BACKBONE RISER SLEEVES OF THE SIZE AS INDICATED ON THE PLANS. REFER TO SECTION 27 15 00 COMMUNICATIONS STRUCTURED CABLING AND SECTION 27 05 33 RACEWAYS AND BOXES FOR COMMUNICATIONS SYSTEMS.
2. CONTRACTOR SHALL X-RAY CONCRETE FLOOR BEFORE CORE DRILLING. CONTRACTOR SHALL COORDINATE WITH THE COR BEFORE BEGINNING DRILLING.
3. CONTRACTOR SHALL FIRESTOP RISER SLEEVES AND EMPTY SPARE RISER SLEEVES. REFER TO SECTION 07 84 00 FIRESTOPPING.
4. CONTRACTOR SHALL INSTALL AN VERTICAL LADDER TYPE CABLE TRAY ON THE WALL ABOVE THE VERTICAL RISER SLEEVES FOR BACKBONE CABLE SUPPORT AS INDICATED ON THE PLANS. THE CABLE TRAY SHALL BE SECURELY ANCHORED TO THE WALL SUFFICIENT TO SUPPORT THE TOTAL WEIGHT OF CABLES AND CABLE TRAY PLUS 50%.
5. CONTRACTOR SHALL INSTALL CABLE SUPPORTS SUFFICIENT TO SUPPORT COMMUNICATIONS CABLES ON THE VERTICAL CABLE TRAY WITHOUT DAMAGING OR DEFORMING THE CABLE.
6. CONTRACTOR SHALL LABEL EACH CABLE AT 42 INCHES A.F.F. ON EACH FLOOR. REFER TO SECTION 27 15 00 COMMUNICATIONS STRUCTURED CABLING.
7. CONTRACTOR SHALL INSTALL NEW J-HOOKS WHERE THERE IS NO CABLE TRAY OR COMMUNICATIONS CONDUIT UNLESS OTHERWISE NOTED.
8. CONTRACTOR SHALL INSTALL NEW CATEGORY 6A PATCH PANELS IN THE TELECOMMUNICATION ROOM AS INDICATED ON RACK ELEVATIONS.
9. CONTRACTOR SHALL RE-TERMINATE AND TEST CABLING REMOVED FROM ANY WALL MOUNT EQUIPMENT UNLESS OTHERWISE NOTED. TESTING SHALL BE PERFORMED BY THE CONTRACTOR DURING COMMISSIONING.
10. CONTRACTOR SHALL INSTALL NEW CATEGORY 6A TELECOMMUNICATIONS/DATA OUTLET AS INDICATED. EXISTING COMMUNICATION OUTLET BOXES AND CONDUITS TO BE REUSED.
11. CONTRACTOR SHALL REPLACE ALL DATA CABLE WITH NEW CATEGORY 6A CABLE UNLESS OTHERWISE NOTED.
12. CONTRACTOR SHALL TERMINATE COMMUNICATIONS CABLES WITH NEW CATEGORY 6A MODULAR JACKS TO MATCH THE COMMUNICATION CABLE PERFORMANCE SPECIFICATIONS. NEW MODULAR JACKS SHALL BE OF THE SAME MANUFACTURER AS THE FACE PLATES, PATCH PANELS, AND PATCH CABLES.
13. CONTRACTOR SHALL INSTALL NEW CATEGORY 6A CABLES AND CONNECTIVITY COMPONENTS THAT ARE OF THE SAME MANUFACTURER, INCLUDING CABLE, MODULAR JACKS, PATCH PANELS, FACEPLATES, AND PATCH CABLES.
14. CONTRACTOR SHALL TEST ALL NEW AND EXISTING RE-TERMINATED CABLES IN ACCORDANCE WITH THE SPECIFICATION 27 08 00.

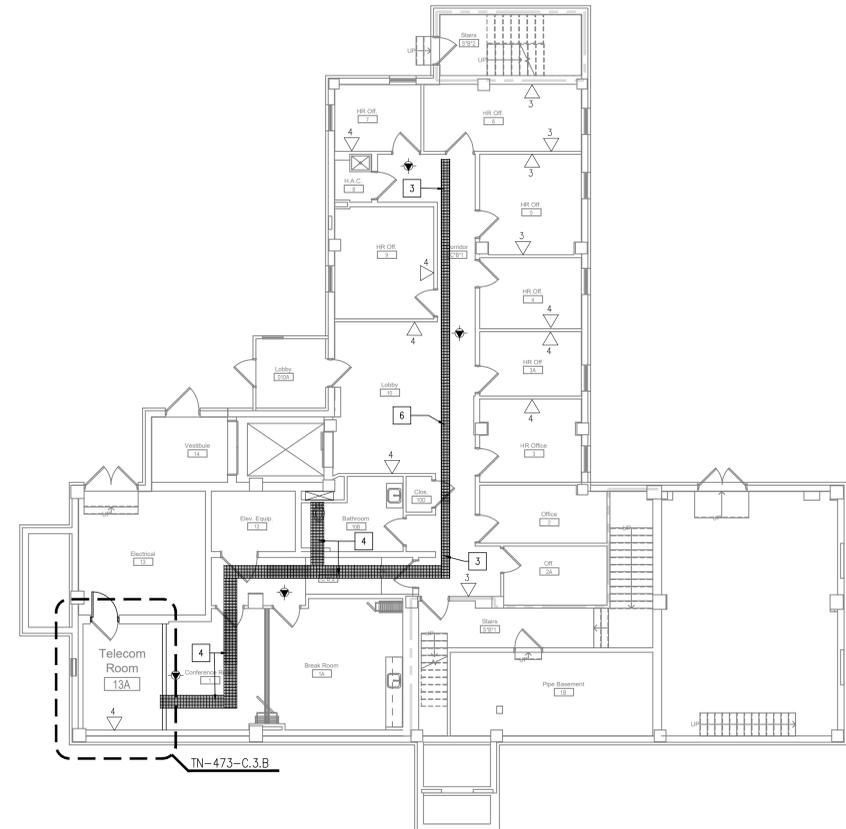

KEYED NOTES

1. BACKBONE RISER CEILING PENETRATION
2. FIREWALL PENETRATION
3. 12 INCH X 4 INCH WIRE MESH CABLE TRAY
4. 18 INCH X 4 INCH WIRE MESH CABLE TRAY
5. 24 INCH X 4 INCH WIRE MESH CABLE TRAY
6. SLEEVES IN FLOOR ABOVE.
7. (2) 4" DIAMETER SLEEVES
8. (2) 2" DIAMETER SLEEVES
9. (2) 1-1/2" DIAMETER SLEEVES

 KEY PLAN

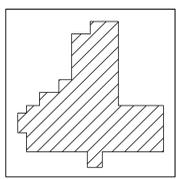

1 FLOOR PLAN - BLDG. 3 - BASEMENT
SCALE: 1/8" = 1'-0"

Revisions:	Date:

CONSULTANT

8718 Botts Lane
San Antonio, Texas 78217
www.hfscompany.com

Phone: (210) 816-4784
Fax: (210) 881-6808
jbianco@hfscompany.com

PROJECT MANAGEMENT

8718 Botts Lane
San Antonio, Texas 78217
www.hfscompany.com

Phone: (210) 816-4784
Fax: (210) 881-6808
jbianco@hfscompany.com

REGISTERED COMMUNICATIONS DISTRIBUTION DESIGNER

Raymond Martinez Jr.
BICSI ID # 143493
Expires 12-31-24
RCDD
04-MAY-22

Construction and Facilities Management

U.S. Department of Veterans Affairs

Drawing Title
BLDG. 3 - BASEMENT TECHNOLOGY DATA OUTLET PLAN

Approved: Project Director

Phase
100% CONSTRUCTION DOCUMENTS

FULLY SPRINKLERED

Project Title
CINCINNATI VAMC EHRM INFRASTRUCTURE UPGRADES

Location
3200 VINE ST., CINCINNATI, OH

Issue Date
04-MAY-2022

Checked
NA

Drawn
RMjr


Project Number
539-21-701

Building Number
3

Drawing Number
TN-220-C.3.B

GENERAL NOTES



- CONTRACTOR SHALL INSTALL BACKBONE RISER SLEEVES OF THE SIZE AS INDICATED ON THE PLANS. REFER TO SECTION 27 15 00 COMMUNICATIONS STRUCTURED CABLING AND SECTION 27 05 33 RACEWAYS AND BOXES FOR COMMUNICATIONS SYSTEMS.
- CONTRACTOR SHALL X-RAY CONCRETE FLOOR BEFORE CORE DRILLING. CONTRACTOR SHALL COORDINATE WITH THE COR BEFORE BEGINNING DRILLING.
- CONTRACTOR SHALL FIRESTOP RISER SLEEVES AND EMPTY SPARE RISER SLEEVES. REFER TO SECTION 07 84 00 FIRESTOPPING.
- CONTRACTOR SHALL INSTALL AN VERTICAL LADDER TYPE CABLE TRAY ON THE WALL ABOVE THE VERTICAL RISER SLEEVES FOR BACKBONE CABLE SUPPORT AS INDICATED ON THE PLANS. THE CABLE TRAY SHALL BE SECURELY ANCHORED TO THE WALL SUFFICIENT TO SUPPORT THE TOTAL WEIGHT OF CABLES AND CABLE TRAY PLUS 50%.
- CONTRACTOR SHALL INSTALL CABLE SUPPORTS SUFFICIENT TO SUPPORT COMMUNICATIONS CABLES ON THE VERTICAL CABLE TRAY WITHOUT DAMAGING OR DEFORMING THE CABLE.
- CONTRACTOR SHALL LABEL EACH CABLE AT 42 INCHES A.F.F. ON EACH FLOOR. REFER TO SECTION 27 15 00 COMMUNICATIONS STRUCTURED CABLING.
- CONTRACTOR SHALL INSTALL NEW J-HOOKS WHERE THERE IS NO CABLE TRAY OR COMMUNICATIONS CONDUIT UNLESS OTHERWISE NOTED.
- CONTRACTOR SHALL INSTALL NEW CATEGORY 6A PATCH PANELS IN THE TELECOMMUNICATION ROOM AS INDICATED ON RACK ELEVATIONS.
- CONTRACTOR SHALL RE-TERMINATE AND TEST CABLING REMOVED FROM ANY WALL MOUNT EQUIPMENT UNLESS OTHERWISE NOTED. TESTING SHALL BE PERFORMED BY THE CONTRACTOR DURING COMMISSIONING.
- CONTRACTOR SHALL INSTALL NEW CATEGORY 6A TELECOMMUNICATIONS/DATA OUTLET AS INDICATED. EXISTING COMMUNICATION OUTLET BOXES AND CONDUITS TO BE REUSED.
- CONTRACTOR SHALL REPLACE ALL DATA CABLE WITH NEW CATEGORY 6A CABLE UNLESS OTHERWISE NOTED.
- CONTRACTOR SHALL TERMINATE COMMUNICATIONS CABLES WITH NEW CATEGORY MODULAR JACKS TO MATCH THE COMMUNICATION CABLE PERFORMANCE SPECIFICATIONS. NEW MODULAR JACKS SHALL BE OF THE SAME MANUFACTURER AS THE FACE PLATES, PATCH PANELS, AND PATCH CABLES.
- CONTRACTOR SHALL INSTALL NEW CATEGORY 6A CABLES AND CONNECTIVITY COMPONENTS THAT ARE OF THE SAME MANUFACTURER, INCLUDING CABLE, MODULAR JACKS, PATCH PANELS, FACEPLATES, AND PATCH CABLES.
- CONTRACTOR SHALL TEST ALL NEW AND EXISTING RE-TERMINATED CABLES IN ACCORDANCE WITH THE SPECIFICATION 27 08 00.

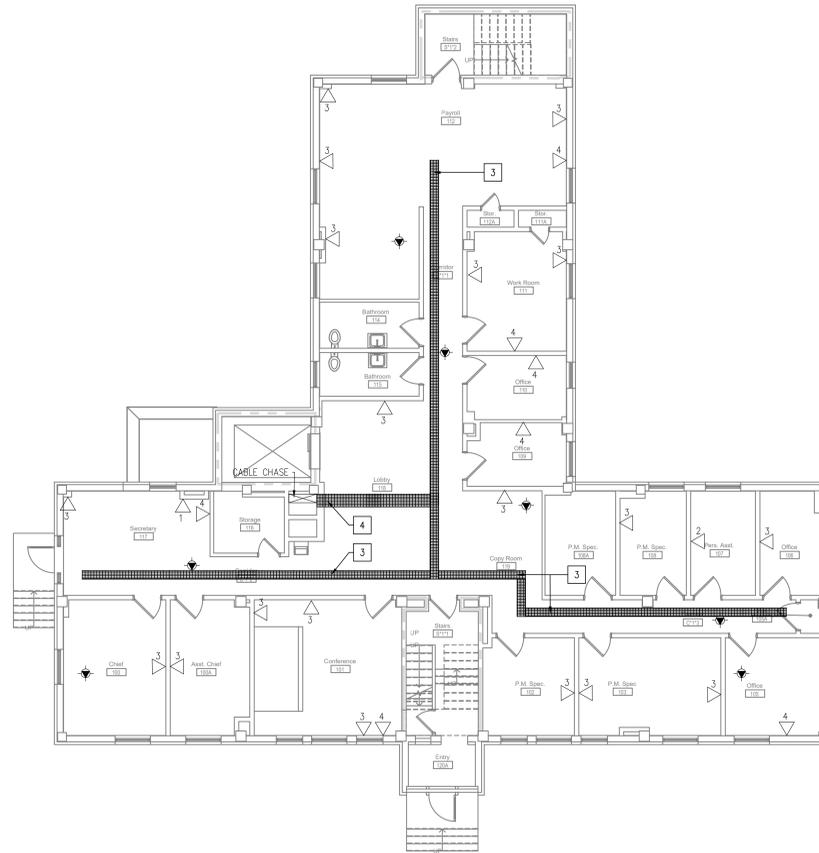

KEYED NOTES

- BACKBONE RISER CEILING PENETRATION
- FIREWALL PENETRATION
- 12 INCH X 4 INCH WIRE MESH CABLE TRAY
- 18 INCH X 4 INCH WIRE MESH CABLE TRAY
- 24 INCH X 4 INCH WIRE MESH CABLE TRAY
- SLEEVES IN FLOOR ABOVE.
- (2) 4" DIAMETER SLEEVES
- (2) 2" DIAMETER SLEEVES
- (2) 1-1/2" DIAMETER SLEEVES

 KEY PLAN

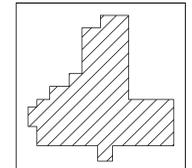

1 FLOOR PLAN - BLDG. 3 - FIRST FLOOR
SCALE: 1/8" = 1'-0"

Revisions:	Date:

CONSULTANT

HFS

C O M P A N Y

8718 Botts Lane Phone: (210) 816-4784
San Antonio, Texas 78217 Fax: (210) 881-6808
www.hfscompany.com jbianco@hfscompany.com

PROJECT MANAGEMENT

HFS

C O M P A N Y

8718 Botts Lane Phone: (210) 816-4784
San Antonio, Texas 78217 Fax: (210) 881-6808
www.hfscompany.com jbianco@hfscompany.com

Bicsi

Raymond Martinez Jr.
BICSI ID # 143493
Expires 12-31-24
RCDD
04-MAY-22

Construction and Facilities Management

VA U.S. Department of Veterans Affairs

Drawing Title
BLDG. 3 - FIRST FLOOR TECHNOLOGY DATA OUTLET PLAN

Approved: Project Director

Phase
100% CONSTRUCTION DOCUMENTS

FULLY SPRINKLERED

Project Title
CINCINNATI VAMC EHRM INFRASTRUCTURE UPGRADES

Location
3200 VINE ST., CINCINNATI, OH

Issue Date
04-MAY-2022

Checked
NA

Drawn
RMjr


Project Number
539-21-701

Building Number
3

Drawing Number
TN-221-C.3.1

GENERAL NOTES


1. CONTRACTOR SHALL INSTALL BACKBONE RISER SLEEVES OF THE SIZE AS INDICATED ON THE PLANS. REFER TO SECTION 27 15 00 COMMUNICATIONS STRUCTURED CABLING AND SECTION 27 05 33 RACEWAYS AND BOXES FOR COMMUNICATIONS SYSTEMS.
2. CONTRACTOR SHALL X-RAY CONCRETE FLOOR BEFORE CORE DRILLING. CONTRACTOR SHALL COORDINATE WITH THE COR BEFORE BEGINNING DRILLING.
3. CONTRACTOR SHALL FIRESTOP RISER SLEEVES AND EMPTY SPARE RISER SLEEVES. REFER TO SECTION 07 84 00 FIRESTOPPING.
4. CONTRACTOR SHALL INSTALL AN VERTICAL LADDER TYPE CABLE TRAY ON THE WALL ABOVE THE VERTICAL RISER SLEEVES FOR BACKBONE CABLE SUPPORT AS INDICATED ON THE PLANS. THE CABLE TRAY SHALL BE SECURELY ANCHORED TO THE WALL SUFFICIENT TO SUPPORT THE TOTAL WEIGHT OF CABLES AND CABLE TRAY PLUS 50%.
5. CONTRACTOR SHALL INSTALL CABLE SUPPORTS SUFFICIENT TO SUPPORT COMMUNICATIONS CABLES ON THE VERTICAL CABLE TRAY WITHOUT DAMAGING OR DEFORMING THE CABLE.
6. CONTRACTOR SHALL LABEL EACH CABLE AT 42 INCHES A.F.F. ON EACH FLOOR. REFER TO SECTION 27 15 00 COMMUNICATIONS STRUCTURED CABLING.
7. CONTRACTOR SHALL INSTALL NEW J-HOOKS WHERE THERE IS NO CABLE TRAY OR COMMUNICATIONS CONDUIT UNLESS OTHERWISE NOTED.
8. CONTRACTOR SHALL INSTALL NEW CATEGORY 6A PATCH PANELS IN THE TELECOMMUNICATION ROOM AS INDICATED ON RACK ELEVATIONS.
9. CONTRACTOR SHALL RE-TERMINATE AND TEST CABLING REMOVED FROM ANY WALL MOUNT EQUIPMENT UNLESS OTHERWISE NOTED. TESTING SHALL BE PERFORMED BY THE CONTRACTOR DURING COMMISSIONING.
10. CONTRACTOR SHALL INSTALL NEW CATEGORY 6A TELECOMMUNICATIONS/DATA OUTLET AS INDICATED. EXISTING COMMUNICATION OUTLET BOXES AND CONDUITS TO BE REUSED.
11. CONTRACTOR SHALL REPLACE ALL DATA CABLE WITH NEW CATEGORY 6A CABLE UNLESS OTHERWISE NOTED.
12. CONTRACTOR SHALL TERMINATE COMMUNICATIONS CABLES WITH NEW CATEGORY 6A CABLES AND CONNECTIVITY COMPONENTS THAT ARE OF THE SAME MANUFACTURER, INCLUDING CABLE, MODULAR JACKS, PATCH PANELS, FACEPLATES, AND PATCH CABLES.
13. CONTRACTOR SHALL TEST ALL NEW AND EXISTING RE-TERMINATED CABLES IN ACCORDANCE WITH THE SPECIFICATION 27 08 00.

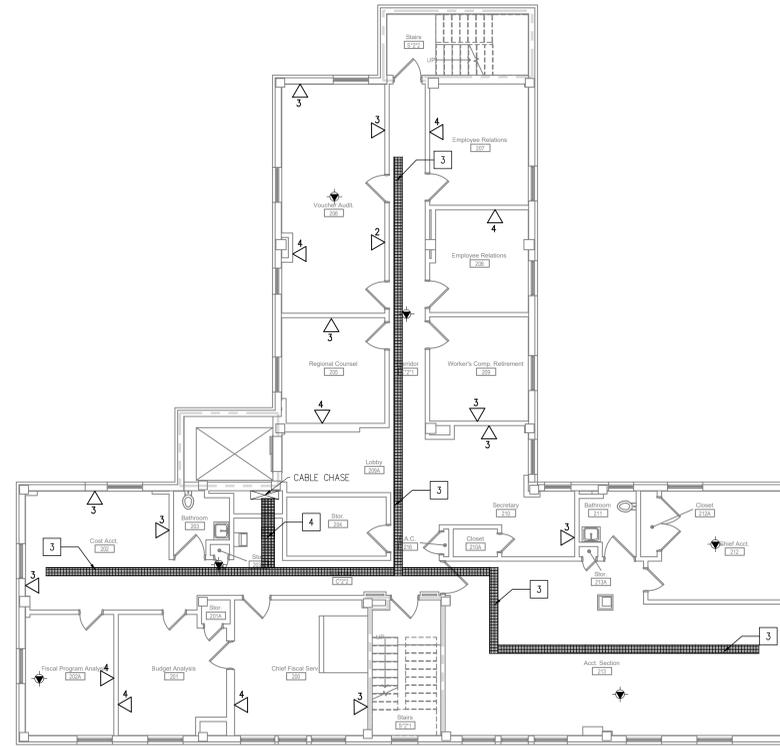


KEYED NOTES

1. BACKBONE RISER CEILING PENETRATION
2. FIREWALL PENETRATION
3. 12 INCH X 4 INCH WIRE MESH CABLE TRAY
4. 18 INCH X 4 INCH WIRE MESH CABLE TRAY
5. 24 INCH X 4 INCH WIRE MESH CABLE TRAY
6. SLEEVES IN FLOOR ABOVE.
7. (2) 4" DIAMETER SLEEVES
8. (2) 2" DIAMETER SLEEVES
9. (2) 1-1/2" DIAMETER SLEEVES

KEY PLAN

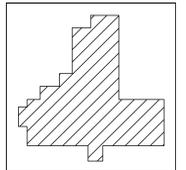

 1 FLOOR PLAN - BLDG. 3 - SECOND FLOOR
SCALE: 1/8" = 1'-0"



Revisions:	Date:

CONSULTANT

8718 Botts Lane
San Antonio, Texas 78217
www.hfscompany.com

Phone: (210) 816-4784
Fax: (210) 881-6808
jbianco@hfscompany.com

PROJECT MANAGEMENT

8718 Botts Lane
San Antonio, Texas 78217
www.hfscompany.com

Phone: (210) 816-4784
Fax: (210) 881-6808
jbianco@hfscompany.com

REGISTERED COMMUNICATIONS DISTRIBUTION DESIGNER

Raymond Martinez Jr.
BICSI ID # 143493
Expires 12-31-24
RCDD
04-MAY-22

Construction and Facilities Management

U.S. Department of Veterans Affairs

Drawing Title
BLDG. 3 - SECOND FLOOR
TECHNOLOGY DATA OUTLET PLAN

Approved: Project Director

Phase
100% CONSTRUCTION DOCUMENTS

FULLY SPRINKLERED

Project Title
CINCINNATI VAMC EHRM INFRASTRUCTURE UPGRADES

Location
3200 VINE ST., CINCINNATI, OH

Issue Date
04-MAY-2022

Checked
NA

Drawn
RMjr


Project Number
539-21-701

Building Number
3

Drawing Number
TN-222-C.3.2

GENERAL NOTES



1. CONTRACTOR SHALL INSTALL BACKBONE RISER SLEEVES OF THE SIZE AS INDICATED ON THE PLANS. REFER TO SECTION 27 15 00 COMMUNICATIONS STRUCTURED CABLING AND SECTION 27 05 33 RACEWAYS AND BOXES FOR COMMUNICATIONS SYSTEMS.
2. CONTRACTOR SHALL X-RAY CONCRETE FLOOR BEFORE CORE DRILLING. CONTRACTOR SHALL COORDINATE WITH THE COR BEFORE BEGINNING DRILLING.
3. CONTRACTOR SHALL FIRESTOP RISER SLEEVES AND EMPTY SPARE RISER SLEEVES. REFER TO SECTION 07 84 00 FIRESTOPPING.
4. CONTRACTOR SHALL INSTALL AN VERTICAL LADDER TYPE CABLE TRAY ON THE WALL ABOVE THE VERTICAL RISER SLEEVES FOR BACKBONE CABLE SUPPORT AS INDICATED ON THE PLANS. THE CABLE TRAY SHALL BE SECURELY ANCHORED TO THE WALL SUFFICIENT TO SUPPORT THE TOTAL WEIGHT OF CABLES AND CABLE TRAY PLUS 50%.
5. CONTRACTOR SHALL INSTALL CABLE SUPPORTS SUFFICIENT TO SUPPORT COMMUNICATIONS CABLES ON THE VERTICAL CABLE TRAY WITHOUT DAMAGING OR DEFORMING THE CABLE.
6. CONTRACTOR SHALL LABEL EACH CABLE AT 42 INCHES A.F.F. ON EACH FLOOR. REFER TO SECTION 27 15 00 COMMUNICATIONS STRUCTURED CABLING.
7. CONTRACTOR SHALL INSTALL NEW J-HOOKS WHERE THERE IS NO CABLE TRAY OR COMMUNICATIONS CONDUIT UNLESS OTHERWISE NOTED.
8. CONTRACTOR SHALL INSTALL NEW CATEGORY 6A PATCH PANELS IN THE TELECOMMUNICATION ROOM AS INDICATED ON RACK ELEVATIONS.
9. CONTRACTOR SHALL RE-TERMINATE AND TEST CABLING REMOVED FROM ANY WALL MOUNT EQUIPMENT UNLESS OTHERWISE NOTED. TESTING SHALL BE PERFORMED BY THE CONTRACTOR DURING COMMISSIONING.
10. CONTRACTOR SHALL INSTALL NEW CATEGORY 6A TELECOMMUNICATIONS/DATA OUTLET AS INDICATED. EXISTING COMMUNICATION OUTLET BOXES AND CONDUITS TO BE REUSED.
11. CONTRACTOR SHALL REPLACE ALL DATA CABLE WITH NEW CATEGORY 6A CABLE UNLESS OTHERWISE NOTED.
12. CONTRACTOR SHALL TERMINATE COMMUNICATIONS CABLES WITH NEW CATEGORY MODULAR JACKS TO MATCH THE COMMUNICATION CABLE PERFORMANCE SPECIFICATIONS. NEW MODULAR JACKS SHALL BE OF THE SAME MANUFACTURER AS THE FACE PLATES, PATCH PANELS, AND PATCH CABLES.
13. CONTRACTOR SHALL INSTALL NEW CATEGORY 6A CABLES AND CONNECTIVITY COMPONENTS THAT ARE OF THE SAME MANUFACTURER, INCLUDING CABLE, MODULAR JACKS, PATCH PANELS, FACEPLATES, AND PATCH CABLES.
14. CONTRACTOR SHALL TEST ALL NEW AND EXISTING RE-TERMINATED CABLES IN ACCORDANCE WITH THE SPECIFICATION 27 08 00.

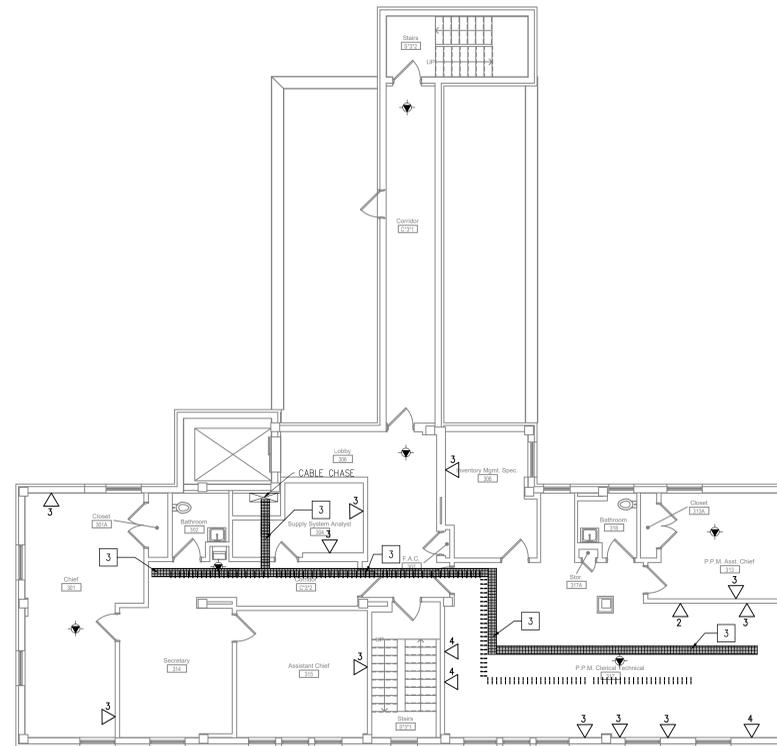

KEYED NOTES

1. BACKBONE RISER CEILING PENETRATION
2. FIREWALL PENETRATION
3. 12 INCH X 4 INCH WIRE MESH CABLE TRAY
4. 18 INCH X 4 INCH WIRE MESH CABLE TRAY
5. 24 INCH X 4 INCH WIRE MESH CABLE TRAY
6. SLEEVES IN FLOOR ABOVE.
7. (2) 4" DIAMETER SLEEVES
8. (2) 2" DIAMETER SLEEVES
9. (2) 1-1/2" DIAMETER SLEEVES

 KEY PLAN

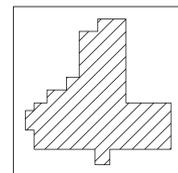

1 FLOOR PLAN - BLDG. 3 - THIRD FLOOR
SCALE: 1/8" = 1'-0"

Revisions:	Date:

CONSULTANT

8718 Botts Lane Phone: (210) 816-4784
San Antonio, Texas 78217 Fax: (210) 881-6808
www.hfscompany.com jbianco@hfscompany.com

PROJECT MANAGEMENT

8718 Botts Lane Phone: (210) 816-4784
San Antonio, Texas 78217 Fax: (210) 881-6808
www.hfscompany.com jbianco@hfscompany.com

REGISTERED COMMUNICATIONS DISTRIBUTION DESIGNER

Raymond Martinez Jr.
BICSI ID # 143493
EXPIRES 12-31-24
RCDD
04-MAY-22

Construction and Facilities Management

U.S. Department of Veterans Affairs

Drawing Title
**BLDG. 3 - THIRD FLOOR
TECHNOLOGY DATA OUTLET PLAN**

Approved: Project Director

Phase
100% CONSTRUCTION DOCUMENTS

FULLY SPRINKLERED

Project Title
**CINCINNATI VAMC EHRM
INFRASTRUCTURE UPGRADES**

Location
3200 VINE ST., CINCINNATI, OH

Issue Date
04-MAY-2022


Checked
NA

Drawn
RMjr

Project Number
539-21-701

Building Number
3

Drawing Number
TN-223-C.3.3

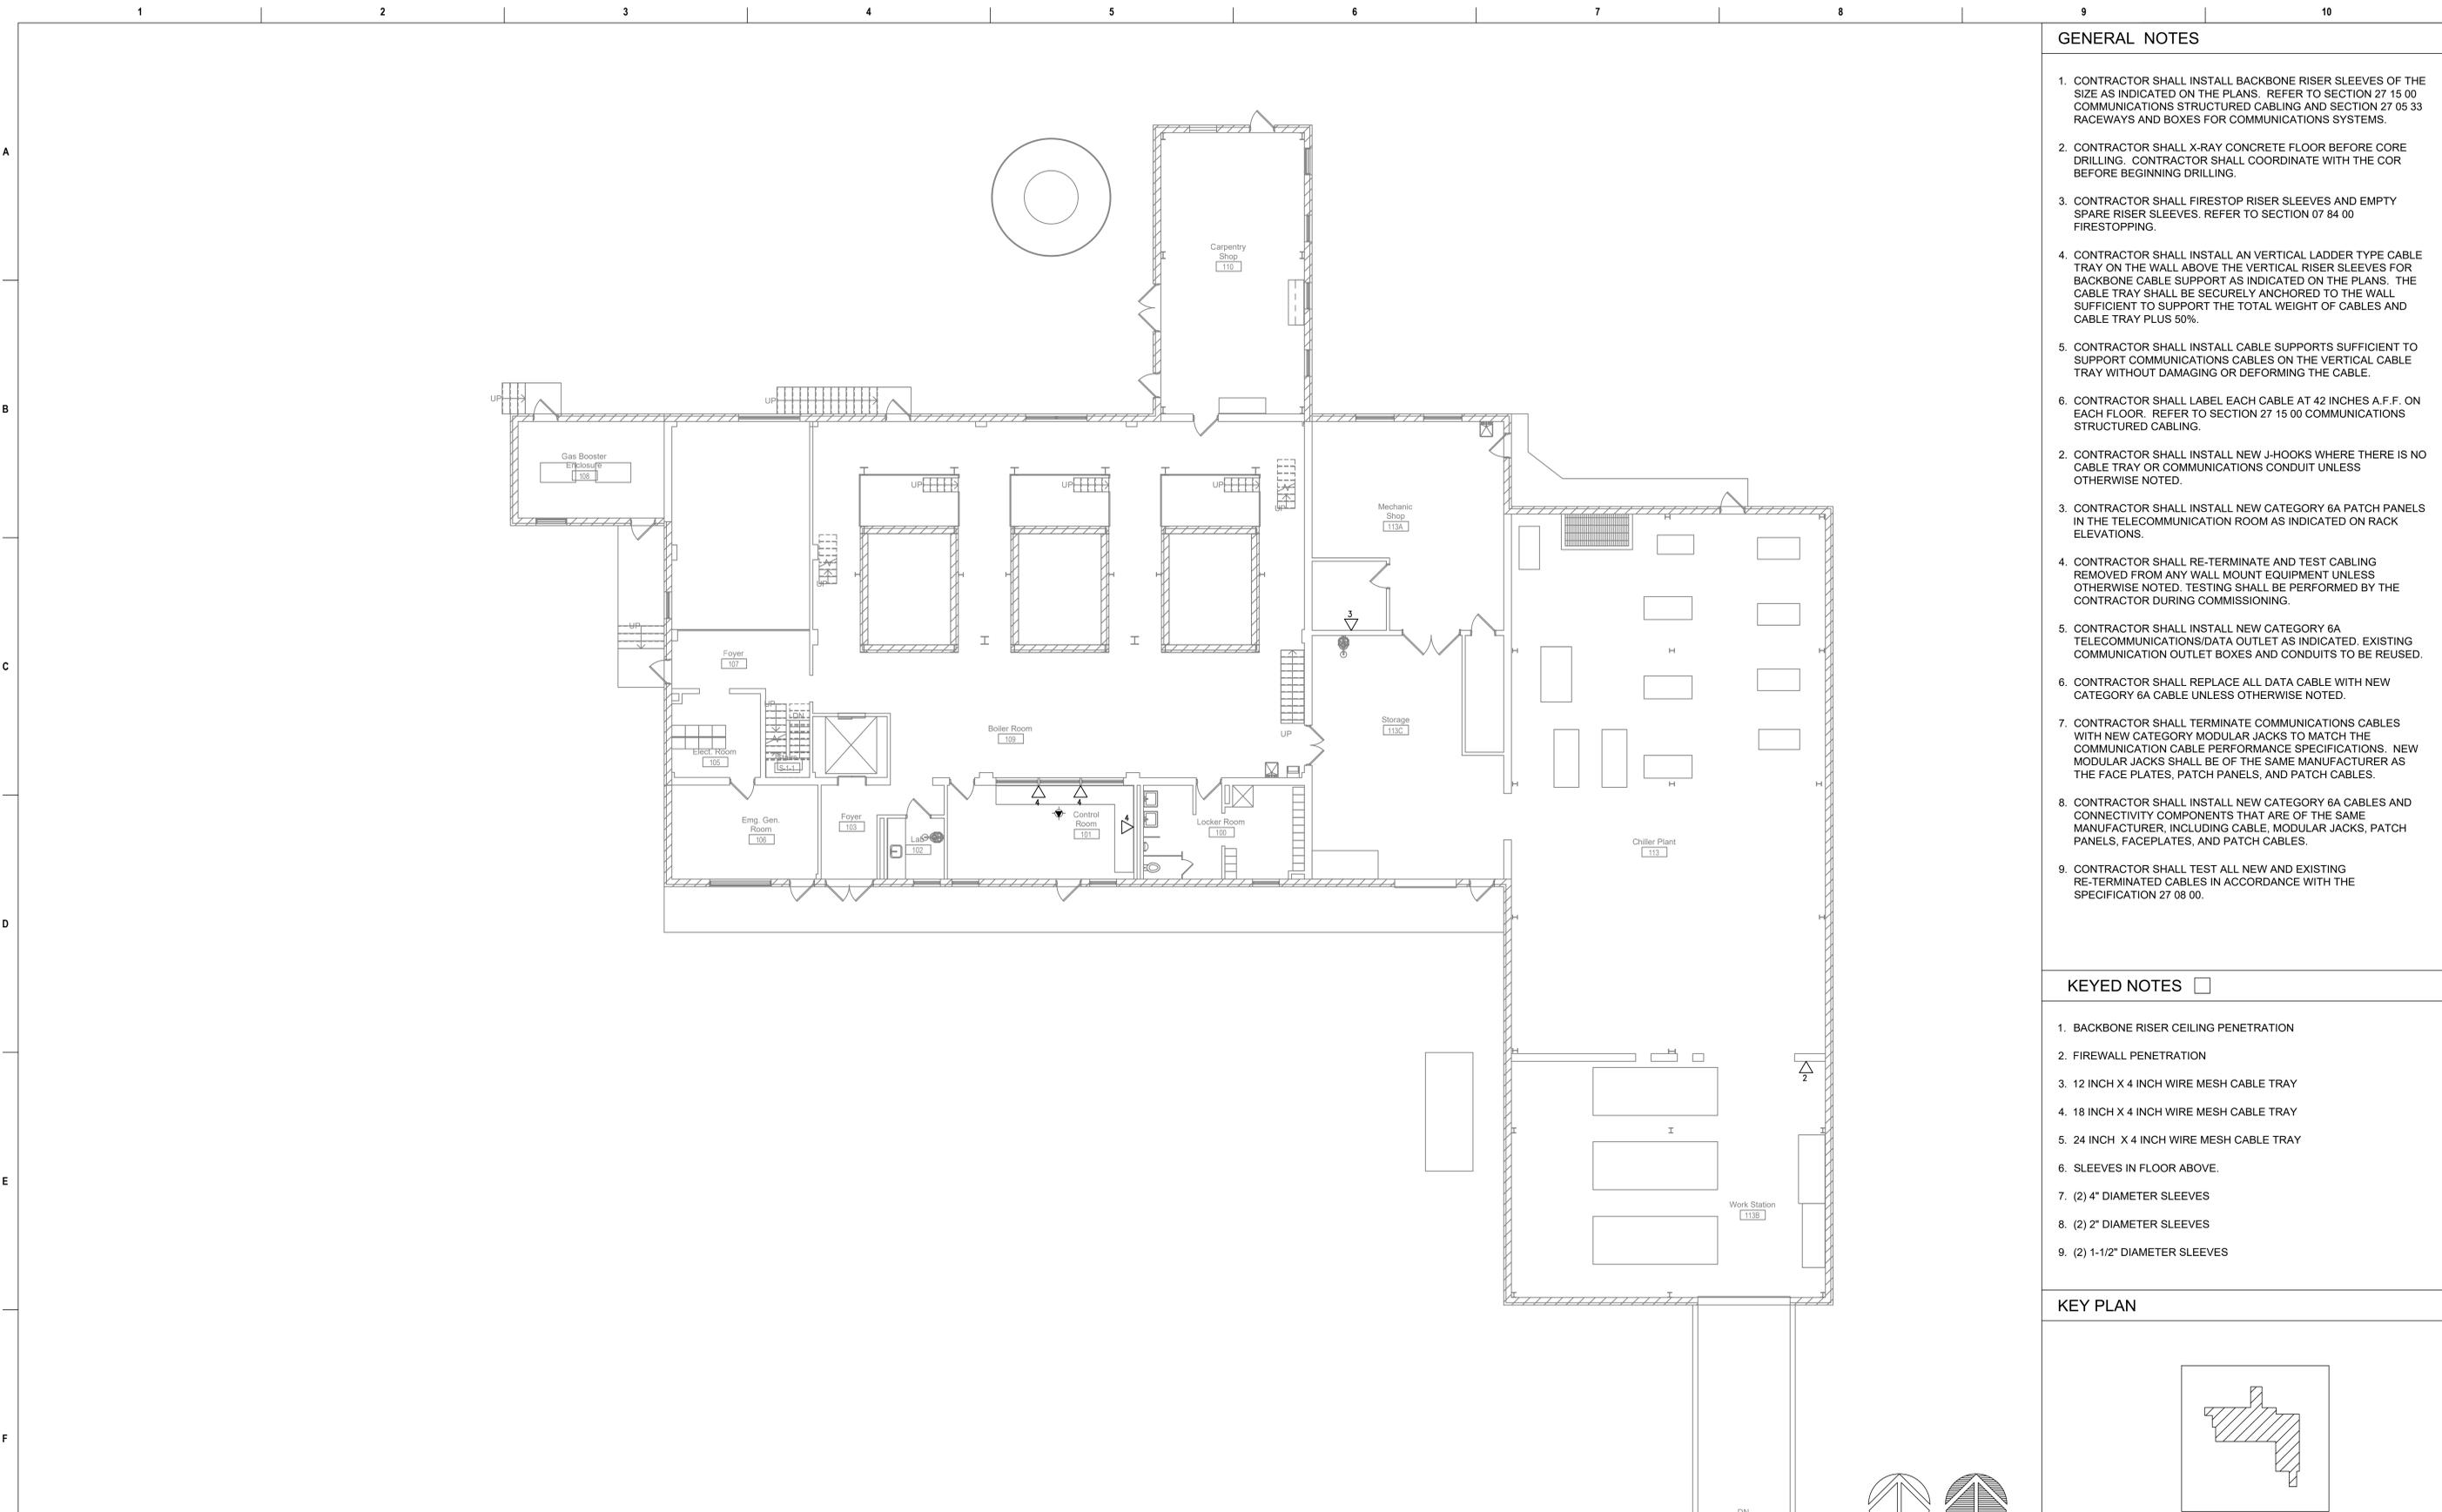


GENERAL NOTES

- CONTRACTOR SHALL INSTALL BACKBONE RISER SLEEVES OF THE SIZE AS INDICATED ON THE PLANS. REFER TO SECTION 27 15 00 COMMUNICATIONS STRUCTURED CABLING AND SECTION 27 05 33 RACEWAYS AND BOXES FOR COMMUNICATIONS SYSTEMS.
- CONTRACTOR SHALL X-RAY CONCRETE FLOOR BEFORE CORE DRILLING. CONTRACTOR SHALL COORDINATE WITH THE COR BEFORE BEGINNING DRILLING.
- CONTRACTOR SHALL FIRESTOP RISER SLEEVES AND EMPTY SPARE RISER SLEEVES. REFER TO SECTION 07 84 00 FIRESTOPPING.
- CONTRACTOR SHALL INSTALL AN VERTICAL LADDER TYPE CABLE TRAY ON THE WALL ABOVE THE VERTICAL RISER SLEEVES FOR BACKBONE CABLE SUPPORT AS INDICATED ON THE PLANS. THE CABLE TRAY SHALL BE SECURELY ANCHORED TO THE WALL SUFFICIENT TO SUPPORT THE TOTAL WEIGHT OF CABLES AND CABLE TRAY PLUS 50%.
- CONTRACTOR SHALL INSTALL CABLE SUPPORTS SUFFICIENT TO SUPPORT COMMUNICATIONS CABLES ON THE VERTICAL CABLE TRAY WITHOUT DAMAGING OR DEFORMING THE CABLE.
- CONTRACTOR SHALL LABEL EACH CABLE AT 42 INCHES A.F.F. ON EACH FLOOR. REFER TO SECTION 27 15 00 COMMUNICATIONS STRUCTURED CABLING.
- CONTRACTOR SHALL INSTALL NEW J-HOOKS WHERE THERE IS NO CABLE TRAY OR COMMUNICATIONS CONDUIT UNLESS OTHERWISE NOTED.
- CONTRACTOR SHALL INSTALL NEW CATEGORY 6A PATCH PANELS IN THE TELECOMMUNICATION ROOM AS INDICATED ON RACK ELEVATIONS.
- CONTRACTOR SHALL RE-TERMINATE AND TEST CABLING REMOVED FROM ANY WALL MOUNT EQUIPMENT UNLESS OTHERWISE NOTED. TESTING SHALL BE PERFORMED BY THE CONTRACTOR DURING COMMISSIONING.
- CONTRACTOR SHALL INSTALL NEW CATEGORY 6A TELECOMMUNICATIONS/DATA OUTLET AS INDICATED. EXISTING COMMUNICATION OUTLET BOXES AND CONDUITS TO BE REUSED.
- CONTRACTOR SHALL REPLACE ALL DATA CABLE WITH NEW CATEGORY 6A CABLE UNLESS OTHERWISE NOTED.
- CONTRACTOR SHALL TERMINATE COMMUNICATIONS CABLES WITH NEW CATEGORY 6A MODULAR JACKS TO MATCH THE COMMUNICATION CABLE PERFORMANCE SPECIFICATIONS. NEW MODULAR JACKS SHALL BE OF THE SAME MANUFACTURER AS THE FACE PLATES, PATCH PANELS, AND PATCH CABLES.
- CONTRACTOR SHALL INSTALL NEW CATEGORY 6A CABLES AND CONNECTIVITY COMPONENTS THAT ARE OF THE SAME MANUFACTURER, INCLUDING CABLE, MODULAR JACKS, PATCH PANELS, FACEPLATES, AND PATCH CABLES.
- CONTRACTOR SHALL TEST ALL NEW AND EXISTING RE-TERMINATED CABLES IN ACCORDANCE WITH THE SPECIFICATION 27 08 00.

KEYED NOTES

- BACKBONE RISER CEILING PENETRATION
- FIREWALL PENETRATION
- 12 INCH X 4 INCH WIRE MESH CABLE TRAY
- 18 INCH X 4 INCH WIRE MESH CABLE TRAY
- 24 INCH X 4 INCH WIRE MESH CABLE TRAY
- SLEEVES IN FLOOR ABOVE.
- (2) 4" DIAMETER SLEEVES
- (2) 2" DIAMETER SLEEVES
- (2) 1-1/2" DIAMETER SLEEVES

KEY PLAN

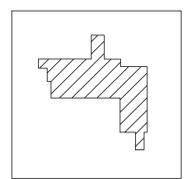

1 FLOOR PLAN - BLDG. 8 - FIRST FLOOR
SCALE: 1/8" = 1'-0"

Revisions:	Date:

CONSULTANT

8718 Botts Lane
San Antonio, Texas 78217
www.hfscompany.com

Phone: (210) 816-4784
Fax: (210) 881-6808
jbianco@hfscompany.com

PROJECT MANAGEMENT

8718 Botts Lane
San Antonio, Texas 78217
www.hfscompany.com

Phone: (210) 816-4784
Fax: (210) 881-6808
jbianco@hfscompany.com

Raymond Martinez Jr.
BICSI ID # 143493
Expires 12-31-24
RCDD
04-MAY-22

Construction and Facilities Management

Drawing Title
BLDG. 8 - FIRST FLOOR TECHNOLOGY DATA OUTLET PLAN

Approved: Project Director

Phase
100% CONSTRUCTION DOCUMENTS

FULLY SPRINKLERED

Project Title
CINCINNATI VAMC EHRM INFRASTRUCTURE UPGRADES

Location
3200 VINE ST., CINCINNATI, OH

Issue Date
04-MAY-2022


Checked
NA

Drawn
RMjr

Project Number
539-21-701

Building Number
8

Drawing Number
TN-231-C.8.1

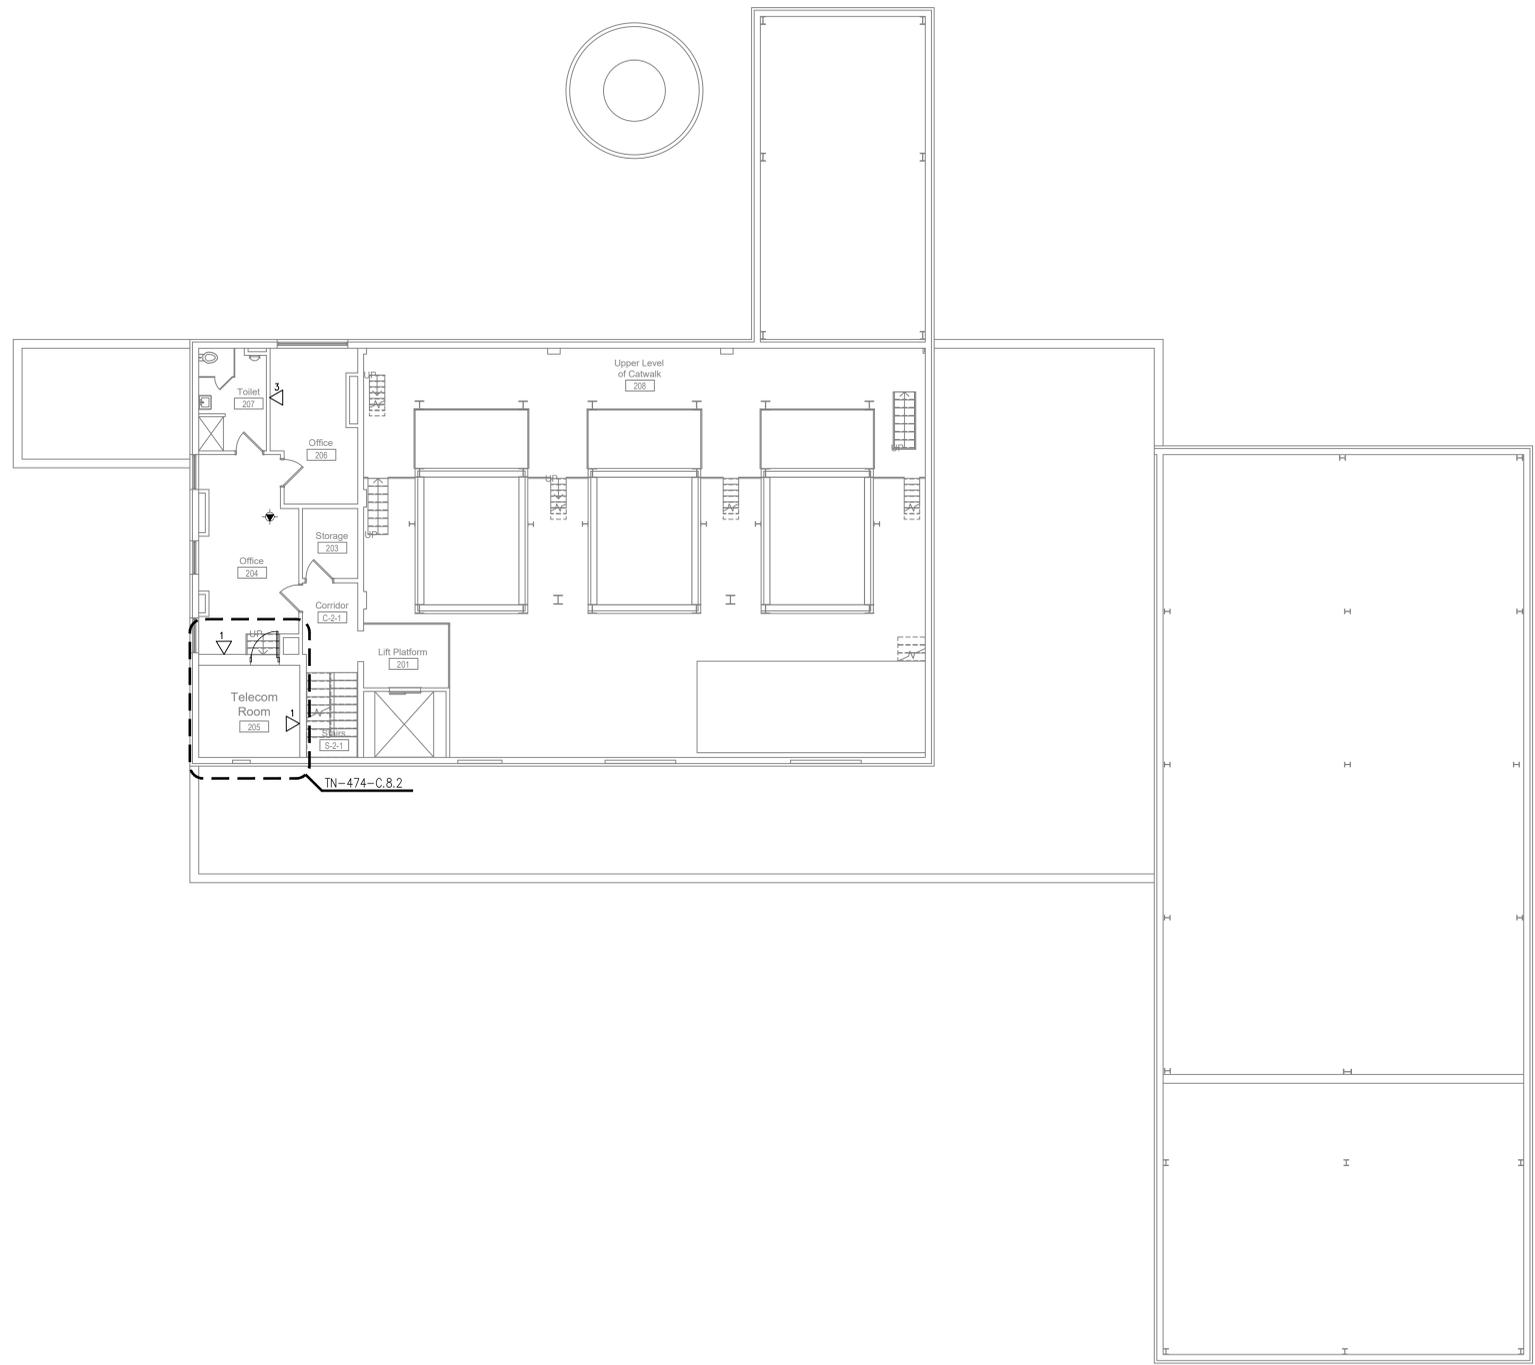



GENERAL NOTES

1. CONTRACTOR SHALL INSTALL BACKBONE RISER SLEEVES OF THE SIZE AS INDICATED ON THE PLANS. REFER TO SECTION 27 15 00 COMMUNICATIONS STRUCTURED CABLING AND SECTION 27 05 33 RACEWAYS AND BOXES FOR COMMUNICATIONS SYSTEMS.
2. CONTRACTOR SHALL X-RAY CONCRETE FLOOR BEFORE CORE DRILLING. CONTRACTOR SHALL COORDINATE WITH THE COR BEFORE BEGINNING DRILLING.
3. CONTRACTOR SHALL FIRESTOP RISER SLEEVES AND EMPTY SPARE RISER SLEEVES. REFER TO SECTION 07 84 00 FIRESTOPPING.
4. CONTRACTOR SHALL INSTALL AN VERTICAL LADDER TYPE CABLE TRAY ON THE WALL ABOVE THE VERTICAL RISER SLEEVES FOR BACKBONE CABLE SUPPORT AS INDICATED ON THE PLANS. THE CABLE TRAY SHALL BE SECURELY ANCHORED TO THE WALL SUFFICIENT TO SUPPORT THE TOTAL WEIGHT OF CABLES AND CABLE TRAY PLUS 50%.
5. CONTRACTOR SHALL INSTALL CABLE SUPPORTS SUFFICIENT TO SUPPORT COMMUNICATIONS CABLES ON THE VERTICAL CABLE TRAY WITHOUT DAMAGING OR DEFORMING THE CABLE.
6. CONTRACTOR SHALL LABEL EACH CABLE AT 42 INCHES A.F.F. ON EACH FLOOR. REFER TO SECTION 27 15 00 COMMUNICATIONS STRUCTURED CABLING.
7. CONTRACTOR SHALL INSTALL NEW J-HOOKS WHERE THERE IS NO CABLE TRAY OR COMMUNICATIONS CONDUIT UNLESS OTHERWISE NOTED.
8. CONTRACTOR SHALL INSTALL NEW CATEGORY 6A PATCH PANELS IN THE TELECOMMUNICATION ROOM AS INDICATED ON RACK ELEVATIONS.
9. CONTRACTOR SHALL RE-TERMINATE AND TEST CABLING REMOVED FROM ANY WALL MOUNT EQUIPMENT UNLESS OTHERWISE NOTED. TESTING SHALL BE PERFORMED BY THE CONTRACTOR DURING COMMISSIONING.
10. CONTRACTOR SHALL INSTALL NEW CATEGORY 6A TELECOMMUNICATIONS/DATA OUTLET AS INDICATED. EXISTING COMMUNICATION OUTLET BOXES AND CONDUITS TO BE REUSED.
11. CONTRACTOR SHALL REPLACE ALL DATA CABLE WITH NEW CATEGORY 6A CABLE UNLESS OTHERWISE NOTED.
12. CONTRACTOR SHALL TERMINATE COMMUNICATIONS CABLES WITH NEW CATEGORY MODULAR JACKS TO MATCH THE COMMUNICATION CABLE PERFORMANCE SPECIFICATIONS. NEW MODULAR JACKS SHALL BE OF THE SAME MANUFACTURER AS THE FACE PLATES, PATCH PANELS, AND PATCH CABLES.
13. CONTRACTOR SHALL INSTALL NEW CATEGORY 6A CABLES AND CONNECTIVITY COMPONENTS THAT ARE OF THE SAME MANUFACTURER, INCLUDING CABLE, MODULAR JACKS, PATCH PANELS, FACEPLATES, AND PATCH CABLES.
14. CONTRACTOR SHALL TEST ALL NEW AND EXISTING RE-TERMINATED CABLES IN ACCORDANCE WITH THE SPECIFICATION 27 08 00.

KEYED NOTES

1. BACKBONE RISER CEILING PENETRATION
2. FIREWALL PENETRATION
3. 12 INCH X 4 INCH WIRE MESH CABLE TRAY
4. 18 INCH X 4 INCH WIRE MESH CABLE TRAY
5. 24 INCH X 4 INCH WIRE MESH CABLE TRAY
6. SLEEVES IN FLOOR ABOVE.
7. (2) 4" DIAMETER SLEEVES
8. (2) 2" DIAMETER SLEEVES
9. (2) 1-1/2" DIAMETER SLEEVES

 KEY PLAN

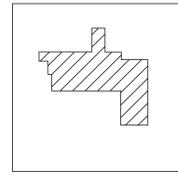

1 FLOOR PLAN - BLDG. 8 - SECOND FLOOR
SCALE: 1/8" = 1'-0"

Revisions:	Date:

CONSULTANT

8718 Botts Lane San Antonio, Texas 78217 www.hfscompany.com
Phone: (210) 816-4784 Fax: (210) 881-6808 jbianco@hfscompany.com

PROJECT MANAGEMENT

8718 Botts Lane San Antonio, Texas 78217 www.hfscompany.com
Phone: (210) 816-4784 Fax: (210) 881-6808 jbianco@hfscompany.com

Bicsi
Raymond Martinez Jr.
BICS1 ID # 143493
Expires 12-31-24
REGISTERED COMMUNICATIONS DISTRIBUTION DESIGNER
RCDD
04-MAY-22

Construction and Facilities Management

Drawing Title
BLDG. 8 - SECOND FLOOR TECHNOLOGY DATA OUTLET PLAN

Approved: Project Director

Phase
100% CONSTRUCTION DOCUMENTS

FULLY SPRINKLERED

Project Title
CINCINNATI VAMC EHRM INFRASTRUCTURE UPGRADES

Location
3200 VINE ST., CINCINNATI, OH

Issue Date
04-MAY-2022



Checked
NA

Drawn
RMjr

Project Number
539-21-701

Building Number
8

Drawing Number
TN-232-C.8.2

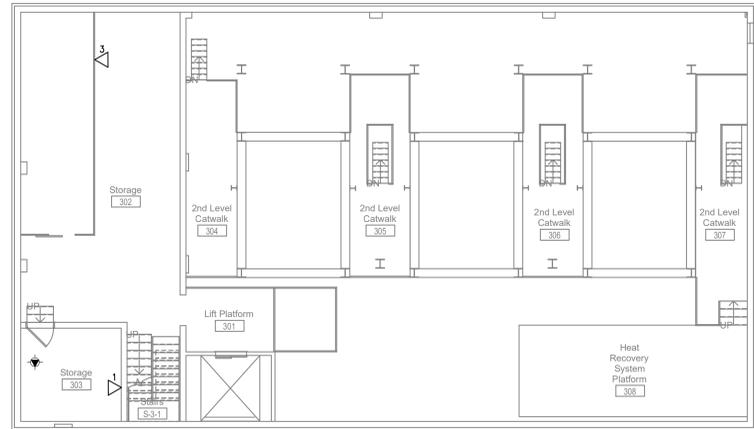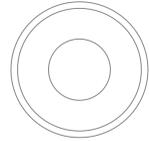



GENERAL NOTES

1. CONTRACTOR SHALL INSTALL BACKBONE RISER SLEEVES OF THE SIZE AS INDICATED ON THE PLANS. REFER TO SECTION 27 15 00 COMMUNICATIONS STRUCTURED CABLING AND SECTION 27 05 33 RACEWAYS AND BOXES FOR COMMUNICATIONS SYSTEMS.
2. CONTRACTOR SHALL X-RAY CONCRETE FLOOR BEFORE CORE DRILLING. CONTRACTOR SHALL COORDINATE WITH THE COR BEFORE BEGINNING DRILLING.
3. CONTRACTOR SHALL FIRESTOP RISER SLEEVES AND EMPTY SPARE RISER SLEEVES. REFER TO SECTION 07 84 00 FIRESTOPPING.
4. CONTRACTOR SHALL INSTALL AN VERTICAL LADDER TYPE CABLE TRAY ON THE WALL ABOVE THE VERTICAL RISER SLEEVES FOR BACKBONE CABLE SUPPORT AS INDICATED ON THE PLANS. THE CABLE TRAY SHALL BE SECURELY ANCHORED TO THE WALL SUFFICIENT TO SUPPORT THE TOTAL WEIGHT OF CABLES AND CABLE TRAY PLUS 50%.
5. CONTRACTOR SHALL INSTALL CABLE SUPPORTS SUFFICIENT TO SUPPORT COMMUNICATIONS CABLES ON THE VERTICAL CABLE TRAY WITHOUT DAMAGING OR DEFORMING THE CABLE.
6. CONTRACTOR SHALL LABEL EACH CABLE AT 42 INCHES A.F.F. ON EACH FLOOR. REFER TO SECTION 27 15 00 COMMUNICATIONS STRUCTURED CABLING.
7. CONTRACTOR SHALL INSTALL NEW J-HOOKS WHERE THERE IS NO CABLE TRAY OR COMMUNICATIONS CONDUIT UNLESS OTHERWISE NOTED.
8. CONTRACTOR SHALL INSTALL NEW CATEGORY 6A PATCH PANELS IN THE TELECOMMUNICATION ROOM AS INDICATED ON RACK ELEVATIONS.
9. CONTRACTOR SHALL RE-TERMINATE AND TEST CABLING REMOVED FROM ANY WALL MOUNT EQUIPMENT UNLESS OTHERWISE NOTED. TESTING SHALL BE PERFORMED BY THE CONTRACTOR DURING COMMISSIONING.
10. CONTRACTOR SHALL INSTALL NEW CATEGORY 6A TELECOMMUNICATIONS/DATA OUTLET AS INDICATED. EXISTING COMMUNICATION OUTLET BOXES AND CONDUITS TO BE REUSED.
11. CONTRACTOR SHALL REPLACE ALL DATA CABLE WITH NEW CATEGORY 6A CABLE UNLESS OTHERWISE NOTED.
12. CONTRACTOR SHALL TERMINATE COMMUNICATIONS CABLES WITH NEW CATEGORY MODULAR JACKS TO MATCH THE COMMUNICATION CABLE PERFORMANCE SPECIFICATIONS. NEW MODULAR JACKS SHALL BE OF THE SAME MANUFACTURER AS THE FACE PLATES, PATCH PANELS, AND PATCH CABLES.
13. CONTRACTOR SHALL INSTALL NEW CATEGORY 6A CABLES AND CONNECTIVITY COMPONENTS THAT ARE OF THE SAME MANUFACTURER, INCLUDING CABLE, MODULAR JACKS, PATCH PANELS, FACEPLATES, AND PATCH CABLES.
14. CONTRACTOR SHALL TEST ALL NEW AND EXISTING RE-TERMINATED CABLES IN ACCORDANCE WITH THE SPECIFICATION 27 08 00.

KEYED NOTES

1. BACKBONE RISER CEILING PENETRATION
2. FIREWALL PENETRATION
3. 12 INCH X 4 INCH WIRE MESH CABLE TRAY
4. 18 INCH X 4 INCH WIRE MESH CABLE TRAY
5. 24 INCH X 4 INCH WIRE MESH CABLE TRAY
6. SLEEVES IN FLOOR ABOVE.
7. (2) 4" DIAMETER SLEEVES
8. (2) 2" DIAMETER SLEEVES
9. (2) 1-1/2" DIAMETER SLEEVES

 KEY PLAN

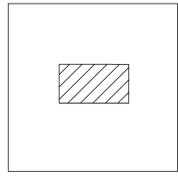

1 FLOOR PLAN - BLDG. 8 - THIRD FLOOR
SCALE: 1/8" = 1'-0"

Revisions:	Date:

CONSULTANT

C O M P A N Y

8718 Botts Lane Phone: (210) 816-4784
San Antonio, Texas 78217 Fax: (210) 881-6808
www.hfscompany.com jbianco@hfscompany.com

PROJECT MANAGEMENT

C O M P A N Y

8718 Botts Lane Phone: (210) 816-4784
San Antonio, Texas 78217 Fax: (210) 881-6808
www.hfscompany.com jbianco@hfscompany.com

Raymond Martinez Jr.
BICSI ID # 143493
Expires 12-31-24
RCDD
04-MAY-22

Construction and Facilities Management

Drawing Title
BLDG. 8 - THIRD FLOOR TECHNOLOGY DATA OUTLET PLAN

Approved: Project Director

Phase
100% CONSTRUCTION DOCUMENTS

FULLY SPRINKLERED

Project Title
CINCINNATI VAMC EHRM INFRASTRUCTURE UPGRADES

Location
3200 VINE ST., CINCINNATI, OH

Issue Date
04-MAY-2022



Checked
NA

Drawn
RMjr

Project Number
539-21-701

Building Number
8

Drawing Number
TN-233-C.8.3

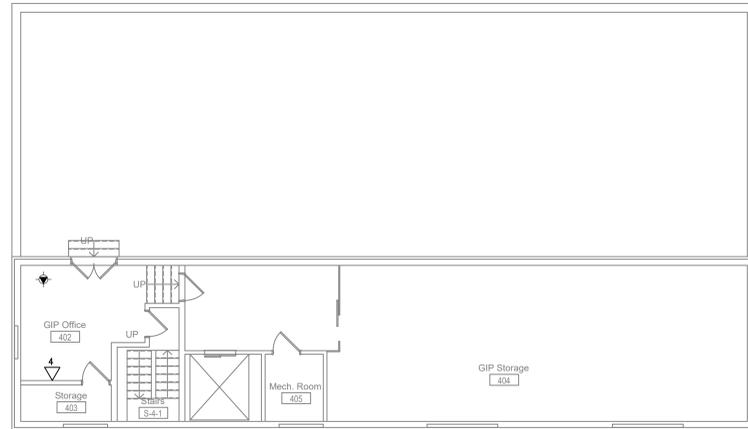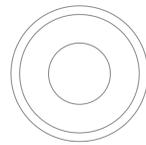



GENERAL NOTES

1. CONTRACTOR SHALL INSTALL BACKBONE RISER SLEEVES OF THE SIZE AS INDICATED ON THE PLANS. REFER TO SECTION 27 15 00 COMMUNICATIONS STRUCTURED CABLING AND SECTION 27 05 33 RACEWAYS AND BOXES FOR COMMUNICATIONS SYSTEMS.
2. CONTRACTOR SHALL X-RAY CONCRETE FLOOR BEFORE CORE DRILLING. CONTRACTOR SHALL COORDINATE WITH THE COR BEFORE BEGINNING DRILLING.
3. CONTRACTOR SHALL FIRESTOP RISER SLEEVES AND EMPTY SPARE RISER SLEEVES. REFER TO SECTION 07 84 00 FIRESTOPPING.
4. CONTRACTOR SHALL INSTALL AN VERTICAL LADDER TYPE CABLE TRAY ON THE WALL ABOVE THE VERTICAL RISER SLEEVES FOR BACKBONE CABLE SUPPORT AS INDICATED ON THE PLANS. THE CABLE TRAY SHALL BE SECURELY ANCHORED TO THE WALL SUFFICIENT TO SUPPORT THE TOTAL WEIGHT OF CABLES AND CABLE TRAY PLUS 50%.
5. CONTRACTOR SHALL INSTALL CABLE SUPPORTS SUFFICIENT TO SUPPORT COMMUNICATIONS CABLES ON THE VERTICAL CABLE TRAY WITHOUT DAMAGING OR DEFORMING THE CABLE.
6. CONTRACTOR SHALL LABEL EACH CABLE AT 42 INCHES A.F.F. ON EACH FLOOR. REFER TO SECTION 27 15 00 COMMUNICATIONS STRUCTURED CABLING.
2. CONTRACTOR SHALL INSTALL NEW J-HOOKS WHERE THERE IS NO CABLE TRAY OR COMMUNICATIONS CONDUIT UNLESS OTHERWISE NOTED.
3. CONTRACTOR SHALL INSTALL NEW CATEGORY 6A PATCH PANELS IN THE TELECOMMUNICATION ROOM AS INDICATED ON RACK ELEVATIONS.
4. CONTRACTOR SHALL RE-TERMINATE AND TEST CABLING REMOVED FROM ANY WALL MOUNT EQUIPMENT UNLESS OTHERWISE NOTED. TESTING SHALL BE PERFORMED BY THE CONTRACTOR DURING COMMISSIONING.
5. CONTRACTOR SHALL INSTALL NEW CATEGORY 6A TELECOMMUNICATIONS/DATA OUTLET AS INDICATED. EXISTING COMMUNICATION OUTLET BOXES AND CONDUITS TO BE REUSED.
6. CONTRACTOR SHALL REPLACE ALL DATA CABLE WITH NEW CATEGORY 6A CABLE UNLESS OTHERWISE NOTED.
7. CONTRACTOR SHALL TERMINATE COMMUNICATIONS CABLES WITH NEW CATEGORY MODULAR JACKS TO MATCH THE COMMUNICATION CABLE PERFORMANCE SPECIFICATIONS. NEW MODULAR JACKS SHALL BE OF THE SAME MANUFACTURER AS THE FACE PLATES, PATCH PANELS, AND PATCH CABLES.
8. CONTRACTOR SHALL INSTALL NEW CATEGORY 6A CABLES AND CONNECTIVITY COMPONENTS THAT ARE OF THE SAME MANUFACTURER, INCLUDING CABLE, MODULAR JACKS, PATCH PANELS, FACEPLATES, AND PATCH CABLES.
9. CONTRACTOR SHALL TEST ALL NEW AND EXISTING RE-TERMINATED CABLES IN ACCORDANCE WITH THE SPECIFICATION 27 08 00.

KEYED NOTES

1. BACKBONE RISER CEILING PENETRATION
2. FIREWALL PENETRATION
3. 12 INCH X 4 INCH WIRE MESH CABLE TRAY
4. 18 INCH X 4 INCH WIRE MESH CABLE TRAY
5. 24 INCH X 4 INCH WIRE MESH CABLE TRAY
6. SLEEVES IN FLOOR ABOVE.
7. (2) 4" DIAMETER SLEEVES
8. (2) 2" DIAMETER SLEEVES
9. (2) 1-1/2" DIAMETER SLEEVES

 KEY PLAN

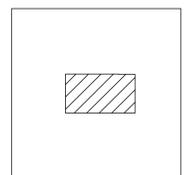

1 FLOOR PLAN - BLDG. 8 - FOURTH FLOOR
SCALE: 1/8" = 1'-0"

Revisions:	Date:

CONSULTANT



C O M P A N Y


8718 Botts Lane Phone: (210) 816-4784
San Antonio, Texas 78217 Fax: (210) 881-6808
www.hfscompany.com jbianco@hfscompany.com

PROJECT MANAGEMENT



C O M P A N Y

8718 Botts Lane Phone: (210) 816-4784
San Antonio, Texas 78217 Fax: (210) 881-6808
www.hfscompany.com jbianco@hfscompany.com

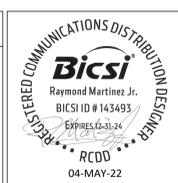

Construction and Facilities Management



Drawing Title
BLDG. 8 - FOURTH FLOOR TECHNOLOGY DATA OUTLET PLAN

Approved: Project Director

Phase
100% CONSTRUCTION DOCUMENTS

FULLY SPRINKLERED

Project Title
CINCINNATI VAMC EHRM INFRASTRUCTURE UPGRADES

Location
3200 VINE ST., CINCINNATI, OH

Issue Date
04-MAY-2022

Checked
NA

Drawn
RMjr


Project Number
539-21-701

Building Number
8

Drawing Number
TN-234-C.8.4

GENERAL NOTES



1. CONTRACTOR SHALL INSTALL BACKBONE RISER SLEEVES OF THE SIZE AS INDICATED ON THE PLANS. REFER TO SECTION 27 15 00 COMMUNICATIONS STRUCTURED CABLING AND SECTION 27 05 33 RACEWAYS AND BOXES FOR COMMUNICATIONS SYSTEMS.
2. CONTRACTOR SHALL X-RAY CONCRETE FLOOR BEFORE CORE DRILLING. CONTRACTOR SHALL COORDINATE WITH THE COR BEFORE BEGINNING DRILLING.
3. CONTRACTOR SHALL FIRESTOP RISER SLEEVES AND EMPTY SPARE RISER SLEEVES. REFER TO SECTION 07 84 00 FIRESTOPPING.
4. CONTRACTOR SHALL INSTALL AN VERTICAL LADDER TYPE CABLE TRAY ON THE WALL ABOVE THE VERTICAL RISER SLEEVES FOR BACKBONE CABLE SUPPORT AS INDICATED ON THE PLANS. THE CABLE TRAY SHALL BE SECURELY ANCHORED TO THE WALL SUFFICIENT TO SUPPORT THE TOTAL WEIGHT OF CABLES AND CABLE TRAY PLUS 50%.
5. CONTRACTOR SHALL INSTALL CABLE SUPPORTS SUFFICIENT TO SUPPORT COMMUNICATIONS CABLES ON THE VERTICAL CABLE TRAY WITHOUT DAMAGING OR DEFORMING THE CABLE.
6. CONTRACTOR SHALL LABEL EACH CABLE AT 42 INCHES A.F.F. ON EACH FLOOR. REFER TO SECTION 27 15 00 COMMUNICATIONS STRUCTURED CABLING.
7. CONTRACTOR SHALL INSTALL NEW J-HOOKS WHERE THERE IS NO CABLE TRAY OR COMMUNICATIONS CONDUIT UNLESS OTHERWISE NOTED.
8. CONTRACTOR SHALL INSTALL NEW CATEGORY 6A PATCH PANELS IN THE TELECOMMUNICATION ROOM AS INDICATED ON RACK ELEVATIONS.
9. CONTRACTOR SHALL RE-TERMINATE AND TEST CABLING REMOVED FROM ANY WALL MOUNT EQUIPMENT UNLESS OTHERWISE NOTED. TESTING SHALL BE PERFORMED BY THE CONTRACTOR DURING COMMISSIONING.
10. CONTRACTOR SHALL INSTALL NEW CATEGORY 6A TELECOMMUNICATIONS/DATA OUTLET AS INDICATED. EXISTING COMMUNICATION OUTLET BOXES AND CONDUITS TO BE REUSED.
11. CONTRACTOR SHALL REPLACE ALL DATA CABLE WITH NEW CATEGORY 6A CABLE UNLESS OTHERWISE NOTED.
12. CONTRACTOR SHALL TERMINATE COMMUNICATIONS CABLES WITH NEW CATEGORY 6A CABLE UNLESS OTHERWISE NOTED.
13. CONTRACTOR SHALL INSTALL NEW CATEGORY 6A CABLES AND CONNECTIVITY COMPONENTS THAT ARE OF THE SAME MANUFACTURER, INCLUDING CABLE, MODULAR JACKS, PATCH PANELS, FACEPLATES, AND PATCH CABLES.
14. CONTRACTOR SHALL TEST ALL NEW AND EXISTING RE-TERMINATED CABLES IN ACCORDANCE WITH THE SPECIFICATION 27 08 00.

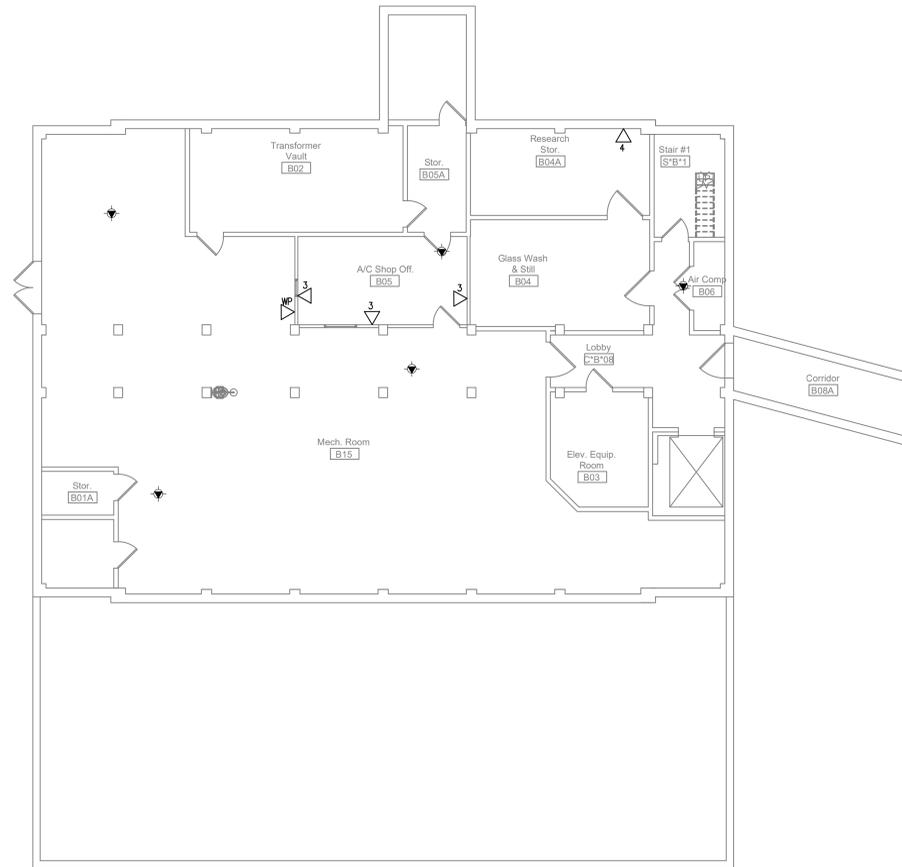

KEYED NOTES

1. BACKBONE RISER CEILING PENETRATION
2. FIREWALL PENETRATION
3. 12 INCH X 4 INCH WIRE MESH CABLE TRAY
4. 18 INCH X 4 INCH WIRE MESH CABLE TRAY
5. 24 INCH X 4 INCH WIRE MESH CABLE TRAY
6. SLEEVES IN FLOOR ABOVE.
7. (2) 4" DIAMETER SLEEVES
8. (2) 2" DIAMETER SLEEVES
9. (2) 1-1/2" DIAMETER SLEEVES

 KEY PLAN

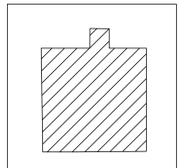

1 FLOOR PLAN - BLDG. 15 - BASEMENT
SCALE: 1/8" = 1'-0"

Revisions:	Date:

CONSULTANT

8718 Botts Lane
San Antonio, Texas 78217
www.hfscompany.com

Phone: (210) 816-4784
Fax: (210) 881-6808
jbianco@hfscompany.com

PROJECT MANAGEMENT

8718 Botts Lane
San Antonio, Texas 78217
www.hfscompany.com

Phone: (210) 816-4784
Fax: (210) 881-6808
jbianco@hfscompany.com

Raymond Martinez Jr.
BICSI ID # 143493
Expires 12-31-24
RCDD
04-MAY-22

Construction and Facilities Management

Drawing Title
BLDG. 15 - BASEMENT TECHNOLOGY DATA OUTLET PLAN

Approved: Project Director

Phase
100% CONSTRUCTION DOCUMENTS

FULLY SPRINKLERED

Project Title
CINCINNATI VAMC EHRM INFRASTRUCTURE UPGRADES

Location
3200 VINE ST., CINCINNATI, OH

Issue Date
04-MAY-2022

Checked
NA

Drawn
RMjr


Project Number
539-21-701

Building Number
15

Drawing Number
TN-250-C.15.B

GENERAL NOTES



- CONTRACTOR SHALL INSTALL BACKBONE RISER SLEEVES OF THE SIZE AS INDICATED ON THE PLANS. REFER TO SECTION 27 15 00 COMMUNICATIONS STRUCTURED CABLING AND SECTION 27 05 33 RACEWAYS AND BOXES FOR COMMUNICATIONS SYSTEMS.
- CONTRACTOR SHALL X-RAY CONCRETE FLOOR BEFORE CORE DRILLING. CONTRACTOR SHALL COORDINATE WITH THE COR BEFORE BEGINNING DRILLING.
- CONTRACTOR SHALL FIRESTOP RISER SLEEVES AND EMPTY SPARE RISER SLEEVES. REFER TO SECTION 07 84 00 FIRESTOPPING.
- CONTRACTOR SHALL INSTALL AN VERTICAL LADDER TYPE CABLE TRAY ON THE WALL ABOVE THE VERTICAL RISER SLEEVES FOR BACKBONE CABLE SUPPORT AS INDICATED ON THE PLANS. THE CABLE TRAY SHALL BE SECURELY ANCHORED TO THE WALL SUFFICIENT TO SUPPORT THE TOTAL WEIGHT OF CABLES AND CABLE TRAY PLUS 50%.
- CONTRACTOR SHALL INSTALL CABLE SUPPORTS SUFFICIENT TO SUPPORT COMMUNICATIONS CABLES ON THE VERTICAL CABLE TRAY WITHOUT DAMAGING OR DEFORMING THE CABLE.
- CONTRACTOR SHALL LABEL EACH CABLE AT 42 INCHES A.F.F. ON EACH FLOOR. REFER TO SECTION 27 15 00 COMMUNICATIONS STRUCTURED CABLING.
- CONTRACTOR SHALL INSTALL NEW J-HOOKS WHERE THERE IS NO CABLE TRAY OR COMMUNICATIONS CONDUIT UNLESS OTHERWISE NOTED.
- CONTRACTOR SHALL INSTALL NEW CATEGORY 6A PATCH PANELS IN THE TELECOMMUNICATION ROOM AS INDICATED ON RACK ELEVATIONS.
- CONTRACTOR SHALL RE-TERMINATE AND TEST CABLING REMOVED FROM ANY WALL MOUNT EQUIPMENT UNLESS OTHERWISE NOTED. TESTING SHALL BE PERFORMED BY THE CONTRACTOR DURING COMMISSIONING.
- CONTRACTOR SHALL INSTALL NEW CATEGORY 6A TELECOMMUNICATIONS/DATA OUTLET AS INDICATED. EXISTING COMMUNICATION OUTLET BOXES AND CONDUITS TO BE REUSED.
- CONTRACTOR SHALL REPLACE ALL DATA CABLE WITH NEW CATEGORY 6A CABLE UNLESS OTHERWISE NOTED.
- CONTRACTOR SHALL TERMINATE COMMUNICATIONS CABLES WITH NEW CATEGORY MODULAR JACKS TO MATCH THE COMMUNICATION CABLE PERFORMANCE SPECIFICATIONS. NEW MODULAR JACKS SHALL BE OF THE SAME MANUFACTURER AS THE FACE PLATES, PATCH PANELS, AND PATCH CABLES.
- CONTRACTOR SHALL INSTALL NEW CATEGORY 6A CABLES AND CONNECTIVITY COMPONENTS THAT ARE OF THE SAME MANUFACTURER, INCLUDING CABLE, MODULAR JACKS, PATCH PANELS, FACEPLATES, AND PATCH CABLES.
- CONTRACTOR SHALL TEST ALL NEW AND EXISTING RE-TERMINATED CABLES IN ACCORDANCE WITH THE SPECIFICATION 27 08 00.

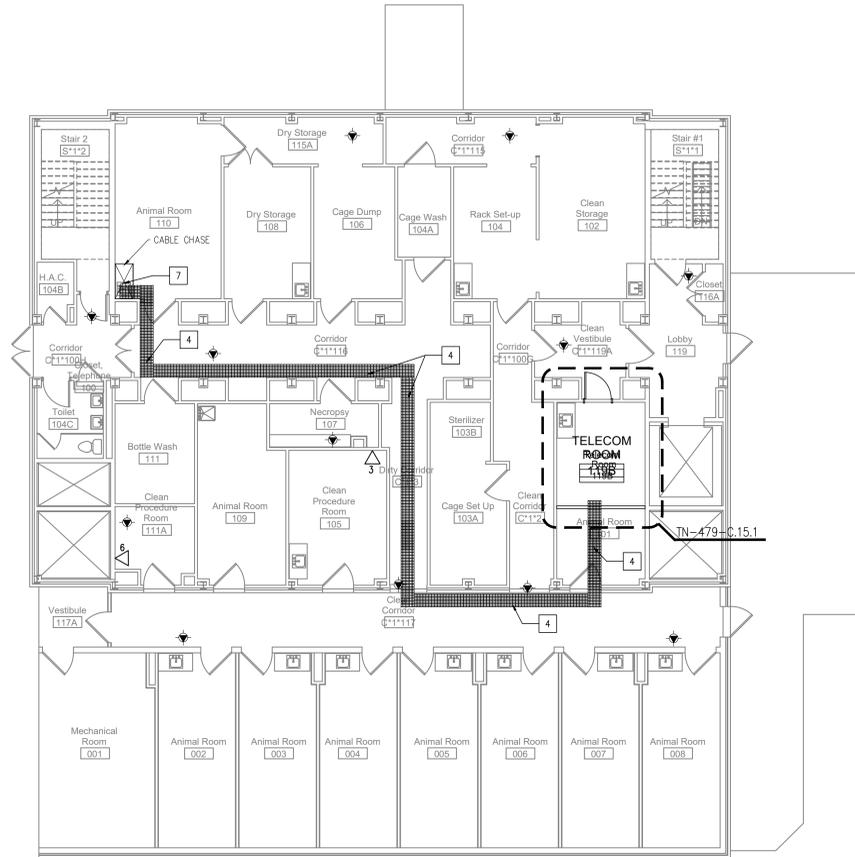

KEYED NOTES

- BACKBONE RISER CEILING PENETRATION
- FIREWALL PENETRATION
- 12 INCH X 4 INCH WIRE MESH CABLE TRAY
- 18 INCH X 4 INCH WIRE MESH CABLE TRAY
- 24 INCH X 4 INCH WIRE MESH CABLE TRAY
- SLEEVES IN FLOOR ABOVE.
- (2) 4" DIAMETER SLEEVES
- (2) 2" DIAMETER SLEEVES
- (2) 1-1/2" DIAMETER SLEEVES

 KEY PLAN

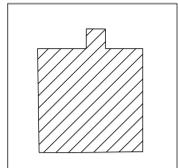

1 FLOOR PLAN - BLDG. 15 - FIRST FLOOR
SCALE: 1/8" = 1'-0"

Revisions:	Date:

CONSULTANT

8718 Botts Lane
San Antonio, Texas 78217
www.hfscompany.com

Phone: (210) 816-4784
Fax: (210) 881-6808
jbianco@hfscompany.com

PROJECT MANAGEMENT

8718 Botts Lane
San Antonio, Texas 78217
www.hfscompany.com

Phone: (210) 816-4784
Fax: (210) 881-6808
jbianco@hfscompany.com

Construction and Facilities Management

Drawing Title
BLDG. 15 - FIRST FLOOR TECHNOLOGY DATA OUTLET PLAN

Approved: Project Director

Phase
100% CONSTRUCTION DOCUMENTS

FULLY SPRINKLERED

Project Title
CINCINNATI VAMC EHRM INFRASTRUCTURE UPGRADES

Location
3200 VINE ST., CINCINNATI, OH

Issue Date
04-MAY-2022

Checked
NA

Drawn
RMjr


Project Number
539-21-701

Building Number
15

Drawing Number
TN-251-C.15.1

GENERAL NOTES



- CONTRACTOR SHALL INSTALL BACKBONE RISER SLEEVES OF THE SIZE AS INDICATED ON THE PLANS. REFER TO SECTION 27 15 00 COMMUNICATIONS STRUCTURED CABLING AND SECTION 27 05 33 RACEWAYS AND BOXES FOR COMMUNICATIONS SYSTEMS.
- CONTRACTOR SHALL X-RAY CONCRETE FLOOR BEFORE CORE DRILLING. CONTRACTOR SHALL COORDINATE WITH THE COR BEFORE BEGINNING DRILLING.
- CONTRACTOR SHALL FIRESTOP RISER SLEEVES AND EMPTY SPARE RISER SLEEVES. REFER TO SECTION 07 84 00 FIRESTOPPING.
- CONTRACTOR SHALL INSTALL AN VERTICAL LADDER TYPE CABLE TRAY ON THE WALL ABOVE THE VERTICAL RISER SLEEVES FOR BACKBONE CABLE SUPPORT AS INDICATED ON THE PLANS. THE CABLE TRAY SHALL BE SECURELY ANCHORED TO THE WALL SUFFICIENT TO SUPPORT THE TOTAL WEIGHT OF CABLES AND CABLE TRAY PLUS 50%.
- CONTRACTOR SHALL INSTALL CABLE SUPPORTS SUFFICIENT TO SUPPORT COMMUNICATIONS CABLES ON THE VERTICAL CABLE TRAY WITHOUT DAMAGING OR DEFORMING THE CABLE.
- CONTRACTOR SHALL LABEL EACH CABLE AT 42 INCHES A.F.F. ON EACH FLOOR. REFER TO SECTION 27 15 00 COMMUNICATIONS STRUCTURED CABLING.
- CONTRACTOR SHALL INSTALL NEW J-HOOKS WHERE THERE IS NO CABLE TRAY OR COMMUNICATIONS CONDUIT UNLESS OTHERWISE NOTED.
- CONTRACTOR SHALL INSTALL NEW CATEGORY 6A PATCH PANELS IN THE TELECOMMUNICATION ROOM AS INDICATED ON RACK ELEVATIONS.
- CONTRACTOR SHALL RE-TERMINATE AND TEST CABLING REMOVED FROM ANY WALL MOUNT EQUIPMENT UNLESS OTHERWISE NOTED. TESTING SHALL BE PERFORMED BY THE CONTRACTOR DURING COMMISSIONING.
- CONTRACTOR SHALL INSTALL NEW CATEGORY 6A TELECOMMUNICATIONS/DATA OUTLET AS INDICATED. EXISTING COMMUNICATION OUTLET BOXES AND CONDUITS TO BE REUSED.
- CONTRACTOR SHALL REPLACE ALL DATA CABLE WITH NEW CATEGORY 6A CABLE UNLESS OTHERWISE NOTED.
- CONTRACTOR SHALL TERMINATE COMMUNICATIONS CABLES WITH NEW CATEGORY MODULAR JACKS TO MATCH THE COMMUNICATION CABLE PERFORMANCE SPECIFICATIONS. NEW MODULAR JACKS SHALL BE OF THE SAME MANUFACTURER AS THE FACE PLATES, PATCH PANELS, AND PATCH CABLES.
- CONTRACTOR SHALL INSTALL NEW CATEGORY 6A CABLES AND CONNECTIVITY COMPONENTS THAT ARE OF THE SAME MANUFACTURER, INCLUDING CABLE, MODULAR JACKS, PATCH PANELS, FACEPLATES, AND PATCH CABLES.
- CONTRACTOR SHALL TEST ALL NEW AND EXISTING RE-TERMINATED CABLES IN ACCORDANCE WITH THE SPECIFICATION 27 08 00.

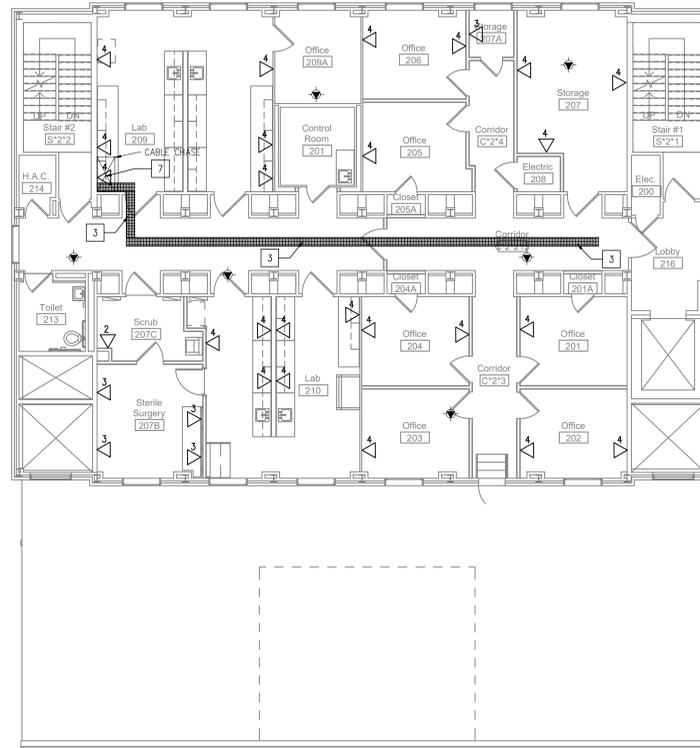

KEYED NOTES

- BACKBONE RISER CEILING PENETRATION
- FIREWALL PENETRATION
- 12 INCH X 4 INCH WIRE MESH CABLE TRAY
- 18 INCH X 4 INCH WIRE MESH CABLE TRAY
- 24 INCH X 4 INCH WIRE MESH CABLE TRAY
- SLEEVES IN FLOOR ABOVE.
- (2) 4" DIAMETER SLEEVES
- (2) 2" DIAMETER SLEEVES
- (2) 1-1/2" DIAMETER SLEEVES

 KEY PLAN

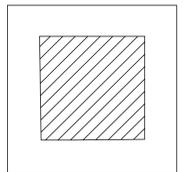

1 FLOOR PLAN - BLDG. 15 - SECOND FLOOR
SCALE: 1/8" = 1'-0"

Revisions:	Date:

CONSULTANT

8718 Botts Lane Phone: (210) 816-4784
San Antonio, Texas 78217 Fax: (210) 881-6808
www.hfscompany.com jbianco@hfscompany.com

PROJECT MANAGEMENT

8718 Botts Lane Phone: (210) 816-4784
San Antonio, Texas 78217 Fax: (210) 881-6808
www.hfscompany.com jbianco@hfscompany.com

REGISTERED COMMUNICATIONS DISTRIBUTION DESIGNER

Raymond Martinez Jr.
BICSI ID # 143493
Expires 12-31-24
RCDD
04-MAY-22

Construction and Facilities Management

U.S. Department of Veterans Affairs

Drawing Title
BLDG. 15 - SECOND FLOOR TECHNOLOGY DATA OUTLET PLAN

Approved: Project Director

Phase
100% CONSTRUCTION DOCUMENTS

FULLY SPRINKLERED

Project Title
CINCINNATI VAMC EHRM INFRASTRUCTURE UPGRADES

Location
3200 VINE ST., CINCINNATI, OH

Issue Date
04-MAY-2022

Checked
NA

Drawn
RMjr


Project Number
539-21-701

Building Number
15

Drawing Number
TN-252-C.15.2

GENERAL NOTES



1. CONTRACTOR SHALL INSTALL BACKBONE RISER SLEEVES OF THE SIZE AS INDICATED ON THE PLANS. REFER TO SECTION 27 15 00 COMMUNICATIONS STRUCTURED CABLING AND SECTION 27 05 33 RACEWAYS AND BOXES FOR COMMUNICATIONS SYSTEMS.
2. CONTRACTOR SHALL X-RAY CONCRETE FLOOR BEFORE CORE DRILLING. CONTRACTOR SHALL COORDINATE WITH THE COR BEFORE BEGINNING DRILLING.
3. CONTRACTOR SHALL FIRESTOP RISER SLEEVES AND EMPTY SPARE RISER SLEEVES. REFER TO SECTION 07 84 00 FIRESTOPPING.
4. CONTRACTOR SHALL INSTALL AN VERTICAL LADDER TYPE CABLE TRAY ON THE WALL ABOVE THE VERTICAL RISER SLEEVES FOR BACKBONE CABLE SUPPORT AS INDICATED ON THE PLANS. THE CABLE TRAY SHALL BE SECURELY ANCHORED TO THE WALL SUFFICIENT TO SUPPORT THE TOTAL WEIGHT OF CABLES AND CABLE TRAY PLUS 50%.
5. CONTRACTOR SHALL INSTALL CABLE SUPPORTS SUFFICIENT TO SUPPORT COMMUNICATIONS CABLES ON THE VERTICAL CABLE TRAY WITHOUT DAMAGING OR DEFORMING THE CABLE.
6. CONTRACTOR SHALL LABEL EACH CABLE AT 42 INCHES A.F.F. ON EACH FLOOR. REFER TO SECTION 27 15 00 COMMUNICATIONS STRUCTURED CABLING.
7. CONTRACTOR SHALL INSTALL NEW J-HOOKS WHERE THERE IS NO CABLE TRAY OR COMMUNICATIONS CONDUIT UNLESS OTHERWISE NOTED.
8. CONTRACTOR SHALL INSTALL NEW CATEGORY 6A PATCH PANELS IN THE TELECOMMUNICATION ROOM AS INDICATED ON RACK ELEVATIONS.
9. CONTRACTOR SHALL RE-TERMINATE AND TEST CABLING REMOVED FROM ANY WALL MOUNT EQUIPMENT UNLESS OTHERWISE NOTED. TESTING SHALL BE PERFORMED BY THE CONTRACTOR DURING COMMISSIONING.
10. CONTRACTOR SHALL INSTALL NEW CATEGORY 6A TELECOMMUNICATIONS/DATA OUTLET AS INDICATED. EXISTING COMMUNICATION OUTLET BOXES AND CONDUITS TO BE REUSED.
11. CONTRACTOR SHALL REPLACE ALL DATA CABLE WITH NEW CATEGORY 6A CABLE UNLESS OTHERWISE NOTED.
12. CONTRACTOR SHALL TERMINATE COMMUNICATIONS CABLES WITH NEW CATEGORY 6A MODULAR JACKS TO MATCH THE COMMUNICATION CABLE PERFORMANCE SPECIFICATIONS. NEW MODULAR JACKS SHALL BE OF THE SAME MANUFACTURER AS THE FACE PLATES, PATCH PANELS, AND PATCH CABLES.
13. CONTRACTOR SHALL INSTALL NEW CATEGORY 6A CABLES AND CONNECTIVITY COMPONENTS THAT ARE OF THE SAME MANUFACTURER, INCLUDING CABLE, MODULAR JACKS, PATCH PANELS, FACEPLATES, AND PATCH CABLES.
14. CONTRACTOR SHALL TEST ALL NEW AND EXISTING RE-TERMINATED CABLES IN ACCORDANCE WITH THE SPECIFICATION 27 08 00.

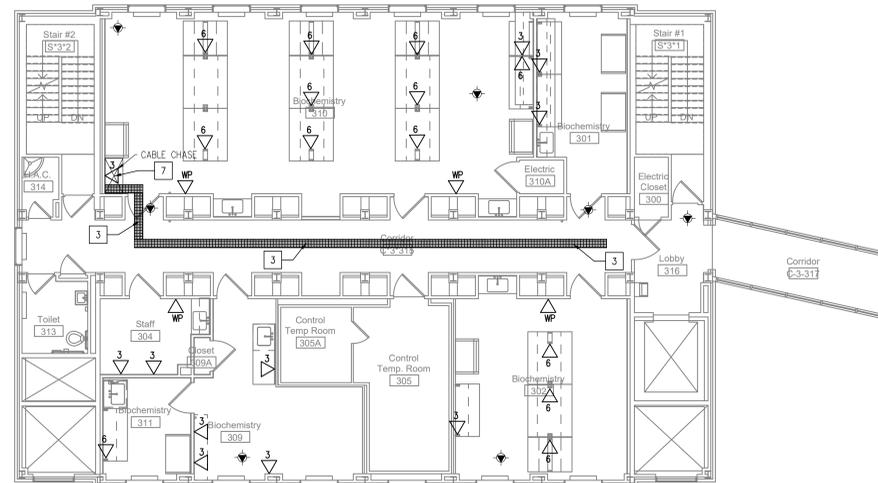

KEYED NOTES

1. BACKBONE RISER CEILING PENETRATION
2. FIREWALL PENETRATION
3. 12 INCH X 4 INCH WIRE MESH CABLE TRAY
4. 18 INCH X 4 INCH WIRE MESH CABLE TRAY
5. 24 INCH X 4 INCH WIRE MESH CABLE TRAY
6. SLEEVES IN FLOOR ABOVE.
7. (2) 4" DIAMETER SLEEVES
8. (2) 2" DIAMETER SLEEVES
9. (2) 1-1/2" DIAMETER SLEEVES

 KEY PLAN

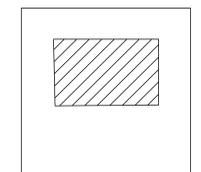

1 FLOOR PLAN - BLDG. 15 - THIRD FLOOR
SCALE: 1/8" = 1'-0"

Revisions:	Date:

CONSULTANT

8718 Botts Lane Phone: (210) 816-4784
San Antonio, Texas 78217 Fax: (210) 881-6808
www.hfscompany.com jbianco@hfscompany.com

PROJECT MANAGEMENT

8718 Botts Lane Phone: (210) 816-4784
San Antonio, Texas 78217 Fax: (210) 881-6808
www.hfscompany.com jbianco@hfscompany.com

Raymond Martinez Jr.
BICSI ID # 143493
Expires 02-31-24
RCDD
04-MAY-22

Construction and Facilities Management

Drawing Title
BLDG. 15 - THIRD FLOOR TECHNOLOGY DATA OUTLET PLAN

Approved: Project Director

Phase
100% CONSTRUCTION DOCUMENTS

FULLY SPRINKLERED

Project Title
CINCINNATI VAMC EHRM INFRASTRUCTURE UPGRADES

Location
3200 VINE ST., CINCINNATI, OH

Issue Date
04-MAY-2022

Checked
NA

Drawn
RMjr


Project Number
539-21-701

Building Number
15

Drawing Number
TN-253-C.15.3

GENERAL NOTES



1. CONTRACTOR SHALL INSTALL BACKBONE RISER SLEEVES OF THE SIZE AS INDICATED ON THE PLANS. REFER TO SECTION 27 15 00 COMMUNICATIONS STRUCTURED CABLING AND SECTION 27 05 33 RACEWAYS AND BOXES FOR COMMUNICATIONS SYSTEMS.
2. CONTRACTOR SHALL X-RAY CONCRETE FLOOR BEFORE CORE DRILLING. CONTRACTOR SHALL COORDINATE WITH THE COR BEFORE BEGINNING DRILLING.
3. CONTRACTOR SHALL FIRESTOP RISER SLEEVES AND EMPTY SPARE RISER SLEEVES. REFER TO SECTION 07 84 00 FIRESTOPPING.
4. CONTRACTOR SHALL INSTALL AN VERTICAL LADDER TYPE CABLE TRAY ON THE WALL ABOVE THE VERTICAL RISER SLEEVES FOR BACKBONE CABLE SUPPORT AS INDICATED ON THE PLANS. THE CABLE TRAY SHALL BE SECURELY ANCHORED TO THE WALL SUFFICIENT TO SUPPORT THE TOTAL WEIGHT OF CABLES AND CABLE TRAY PLUS 50%.
5. CONTRACTOR SHALL INSTALL CABLE SUPPORTS SUFFICIENT TO SUPPORT COMMUNICATIONS CABLES ON THE VERTICAL CABLE TRAY WITHOUT DAMAGING OR DEFORMING THE CABLE.
6. CONTRACTOR SHALL LABEL EACH CABLE AT 42 INCHES A.F.F. ON EACH FLOOR. REFER TO SECTION 27 15 00 COMMUNICATIONS STRUCTURED CABLING.
7. CONTRACTOR SHALL INSTALL NEW J-HOOKS WHERE THERE IS NO CABLE TRAY OR COMMUNICATIONS CONDUIT UNLESS OTHERWISE NOTED.
8. CONTRACTOR SHALL INSTALL NEW CATEGORY 6A PATCH PANELS IN THE TELECOMMUNICATION ROOM AS INDICATED ON RACK ELEVATIONS.
9. CONTRACTOR SHALL RE-TERMINATE AND TEST CABLING REMOVED FROM ANY WALL MOUNT EQUIPMENT UNLESS OTHERWISE NOTED. TESTING SHALL BE PERFORMED BY THE CONTRACTOR DURING COMMISSIONING.
10. CONTRACTOR SHALL INSTALL NEW CATEGORY 6A TELECOMMUNICATIONS/DATA OUTLET AS INDICATED. EXISTING COMMUNICATION OUTLET BOXES AND CONDUITS TO BE REUSED.
11. CONTRACTOR SHALL REPLACE ALL DATA CABLE WITH NEW CATEGORY 6A CABLE UNLESS OTHERWISE NOTED.
12. CONTRACTOR SHALL TERMINATE COMMUNICATIONS CABLES WITH NEW CATEGORY 6A MODULAR JACKS TO MATCH THE COMMUNICATION CABLE PERFORMANCE SPECIFICATIONS. NEW MODULAR JACKS SHALL BE OF THE SAME MANUFACTURER AS THE FACE PLATES, PATCH PANELS, AND PATCH CABLES.
13. CONTRACTOR SHALL INSTALL NEW CATEGORY 6A CABLES AND CONNECTIVITY COMPONENTS THAT ARE OF THE SAME MANUFACTURER, INCLUDING CABLE, MODULAR JACKS, PATCH PANELS, FACEPLATES, AND PATCH CABLES.
14. CONTRACTOR SHALL TEST ALL NEW AND EXISTING RE-TERMINATED CABLES IN ACCORDANCE WITH THE SPECIFICATION 27 08 00.

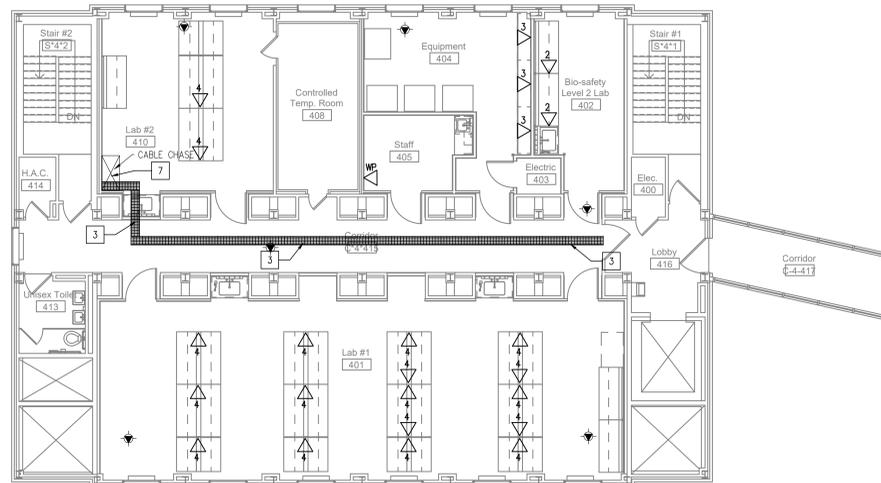

KEYED NOTES

1. BACKBONE RISER CEILING PENETRATION
2. FIREWALL PENETRATION
3. 12 INCH X 4 INCH WIRE MESH CABLE TRAY
4. 18 INCH X 4 INCH WIRE MESH CABLE TRAY
5. 24 INCH X 4 INCH WIRE MESH CABLE TRAY
6. SLEEVES IN FLOOR ABOVE.
7. (2) 4" DIAMETER SLEEVES
8. (2) 2" DIAMETER SLEEVES
9. (2) 1-1/2" DIAMETER SLEEVES

 KEY PLAN

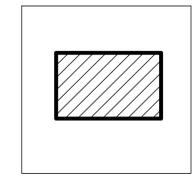

1 FLOOR PLAN - BLDG. 15 - FOURTH FLOOR
SCALE: 1/8" = 1'-0"

Revisions:	Date:

CONSULTANT

8718 Botts Lane Phone: (210) 816-4784
San Antonio, Texas 78217 Fax: (210) 881-6808
www.hfscountry.com jbianco@hfscountry.com

PROJECT MANAGEMENT

8718 Botts Lane Phone: (210) 816-4784
San Antonio, Texas 78217 Fax: (210) 881-6808
www.hfscountry.com jbianco@hfscountry.com

Construction and Facilities Management

Drawing Title
BLDG. 15 - FOURTH FLOOR TECHNOLOGY DATA OUTLET PLAN

Approved: Project Director

Phase
100% CONSTRUCTION DOCUMENTS

FULLY SPRINKLERED

Project Title
CINCINNATI VAMC EHRM INFRASTRUCTURE UPGRADES

Location
3200 VINE ST., CINCINNATI, OH

Issue Date
04-MAY-2022


Checked
NA

Drawn
RMjr

Project Number
539-21-701

Building Number
15

Drawing Number
TN-254-C.15.4

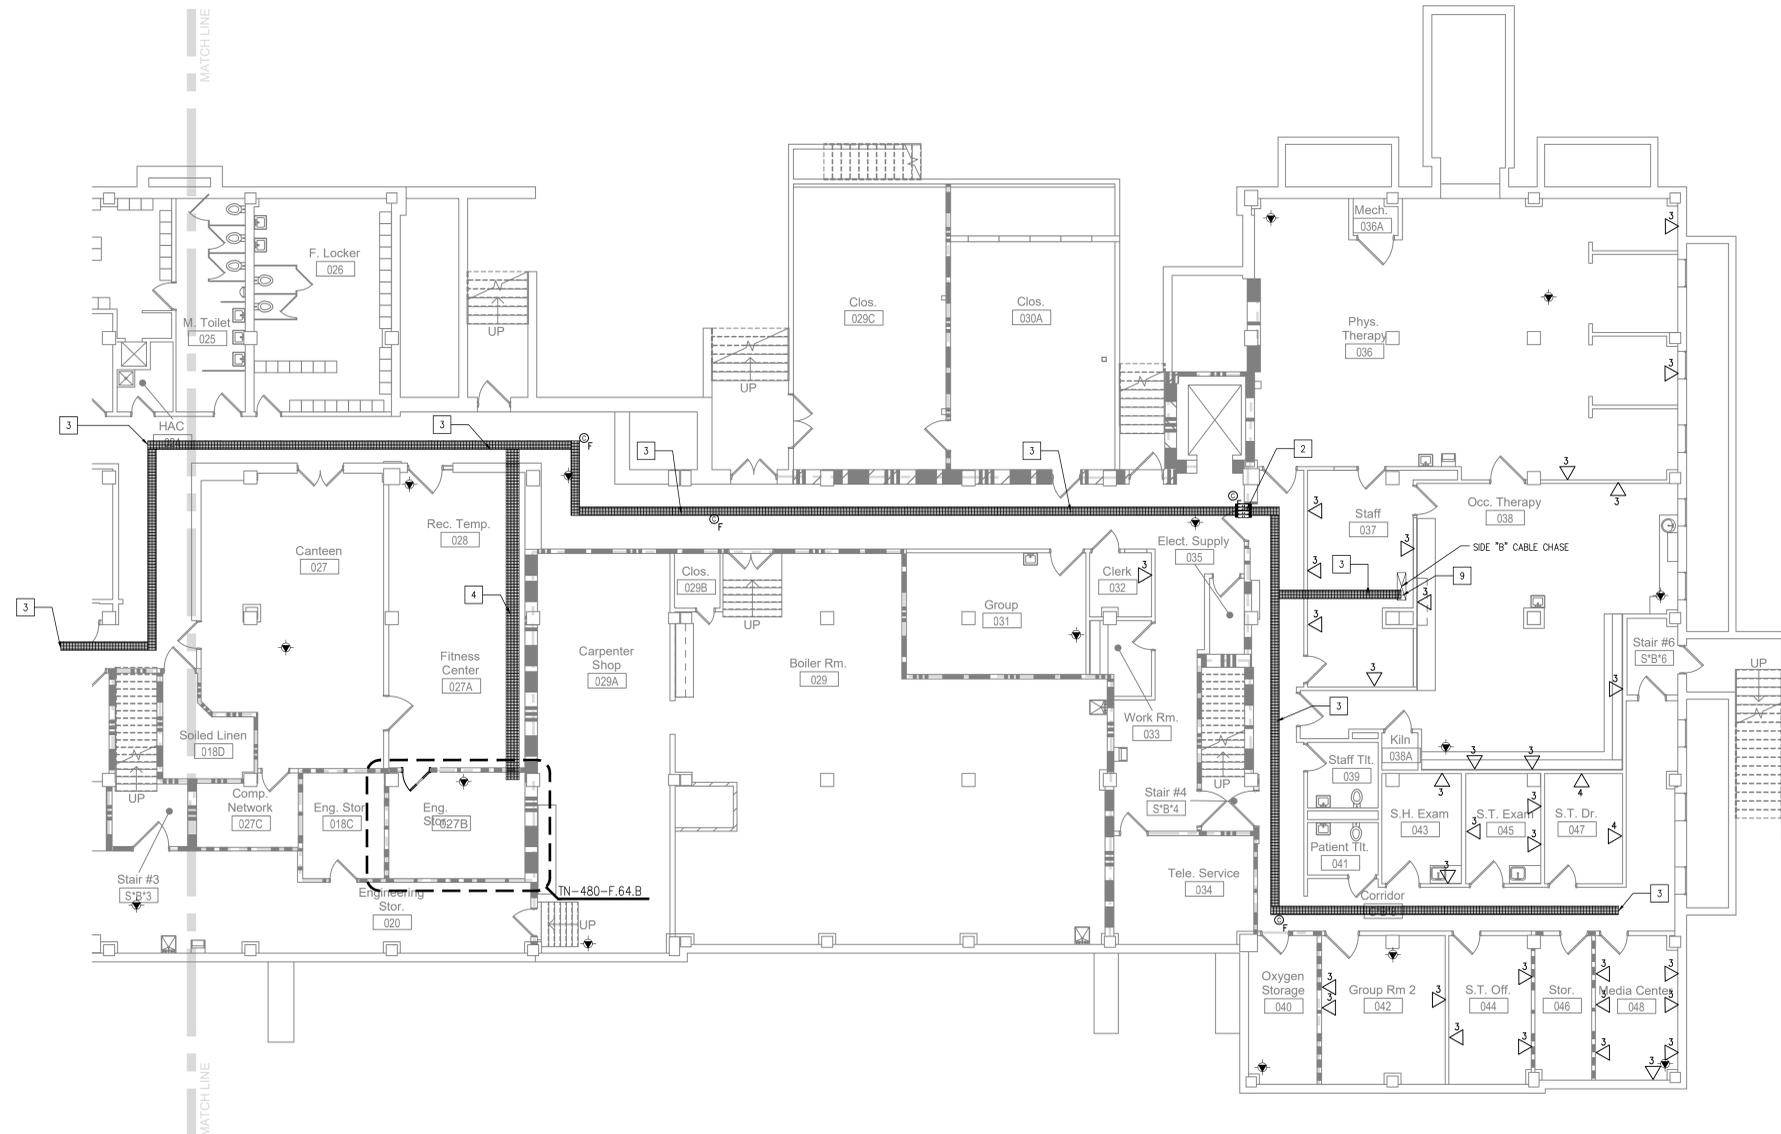



GENERAL NOTES

1. CONTRACTOR SHALL INSTALL BACKBONE RISER SLEEVES OF THE SIZE AS INDICATED ON THE PLANS. REFER TO SECTION 27 15 00 COMMUNICATIONS STRUCTURED CABLING AND SECTION 27 05 33 RACEWAYS AND BOXES FOR COMMUNICATIONS SYSTEMS.
2. CONTRACTOR SHALL X-RAY CONCRETE FLOOR BEFORE CORE DRILLING. CONTRACTOR SHALL COORDINATE WITH THE COR BEFORE BEGINNING DRILLING.
3. CONTRACTOR SHALL FIRESTOP RISER SLEEVES AND EMPTY SPARE RISER SLEEVES. REFER TO SECTION 07 84 00 FIRESTOPPING.
4. CONTRACTOR SHALL INSTALL AN VERTICAL LADDER TYPE CABLE TRAY ON THE WALL ABOVE THE VERTICAL RISER SLEEVES FOR BACKBONE CABLE SUPPORT AS INDICATED ON THE PLANS. THE CABLE TRAY SHALL BE SECURELY ANCHORED TO THE WALL SUFFICIENT TO SUPPORT THE TOTAL WEIGHT OF CABLES AND CABLE TRAY PLUS 50%.
5. CONTRACTOR SHALL INSTALL CABLE SUPPORTS SUFFICIENT TO SUPPORT COMMUNICATIONS CABLES ON THE VERTICAL CABLE TRAY WITHOUT DAMAGING OR DEFORMING THE CABLE.
6. CONTRACTOR SHALL LABEL EACH CABLE AT 42 INCHES A.F.F. ON EACH FLOOR. REFER TO SECTION 27 15 00 COMMUNICATIONS STRUCTURED CABLING.
7. CONTRACTOR SHALL INSTALL NEW J-HOOKS WHERE THERE IS NO CABLE TRAY OR COMMUNICATIONS CONDUIT UNLESS OTHERWISE NOTED.
8. CONTRACTOR SHALL INSTALL NEW CATEGORY 6A PATCH PANELS IN THE TELECOMMUNICATION ROOM AS INDICATED ON RACK ELEVATIONS.
9. CONTRACTOR SHALL RE-TERMINATE AND TEST CABLING REMOVED FROM ANY WALL MOUNT EQUIPMENT UNLESS OTHERWISE NOTED. TESTING SHALL BE PERFORMED BY THE CONTRACTOR DURING COMMISSIONING.
10. CONTRACTOR SHALL INSTALL NEW CATEGORY 6A TELECOMMUNICATIONS/DATA OUTLET AS INDICATED. EXISTING COMMUNICATION OUTLET BOXES AND CONDUITS TO BE REUSED.
11. CONTRACTOR SHALL REPLACE ALL DATA CABLE WITH NEW CATEGORY 6A CABLE UNLESS OTHERWISE NOTED.
12. CONTRACTOR SHALL TERMINATE COMMUNICATIONS CABLES WITH NEW CATEGORY 6A MODULAR JACKS TO MATCH THE COMMUNICATION CABLE PERFORMANCE SPECIFICATIONS. NEW MODULAR JACKS SHALL BE OF THE SAME MANUFACTURER AS THE FACE PLATES, PATCH PANELS, AND PATCH CABLES.
13. CONTRACTOR SHALL INSTALL NEW CATEGORY 6A CABLES AND CONNECTIVITY COMPONENTS THAT ARE OF THE SAME MANUFACTURER, INCLUDING CABLE, MODULAR JACKS, PATCH PANELS, FACEPLATES, AND PATCH CABLES.
14. CONTRACTOR SHALL TEST ALL NEW AND EXISTING RE-TERMINATED CABLES IN ACCORDANCE WITH THE SPECIFICATION 27 08 00.

KEYED NOTES

1. BACKBONE RISER CEILING PENETRATION
2. FIREWALL PENETRATION
3. 12 INCH X 4 INCH WIRE MESH CABLE TRAY
4. 18 INCH X 4 INCH WIRE MESH CABLE TRAY
5. 24 INCH X 4 INCH WIRE MESH CABLE TRAY
6. SLEEVES IN FLOOR ABOVE.
7. (2) 4" DIAMETER SLEEVES
8. (2) 2" DIAMETER SLEEVES
9. (2) 1-1/2" DIAMETER SLEEVES

 KEY PLAN

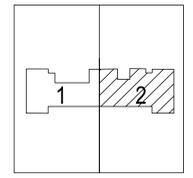

1 DATA OUTLET FLOOR PLAN - BLDG. 64 - BASEMENT NORTH
SCALE: 1/8" = 1'-0"

Revisions:	Date:

CONSULTANT

8718 Botts Lane
San Antonio, Texas 78217
www.hfscompany.com

Phone: (210) 816-4784
Fax: (210) 881-6808
jbianco@hfscompany.com

PROJECT MANAGEMENT

8718 Botts Lane
San Antonio, Texas 78217
www.hfscompany.com

Phone: (210) 816-4784
Fax: (210) 881-6808
jbianco@hfscompany.com

Construction and Facilities Management

Drawing Title
BLDG. 64 - BASEMENT TECHNOLOGY DATA OUTLET PLAN

Approved: Project Director

Phase
100% CONSTRUCTION DOCUMENTS

FULLY SPRINKLERED

Project Title
CINCINNATI VAMC EHRM INFRASTRUCTURE UPGRADES

Location
3200 VINE ST., CINCINNATI, OH

Issue Date
04-MAY-2022


Checked
NA

Drawn
RMjr

Project Number
539-21-701


Building Number
64

Drawing Number
TN-270-F.64.BN

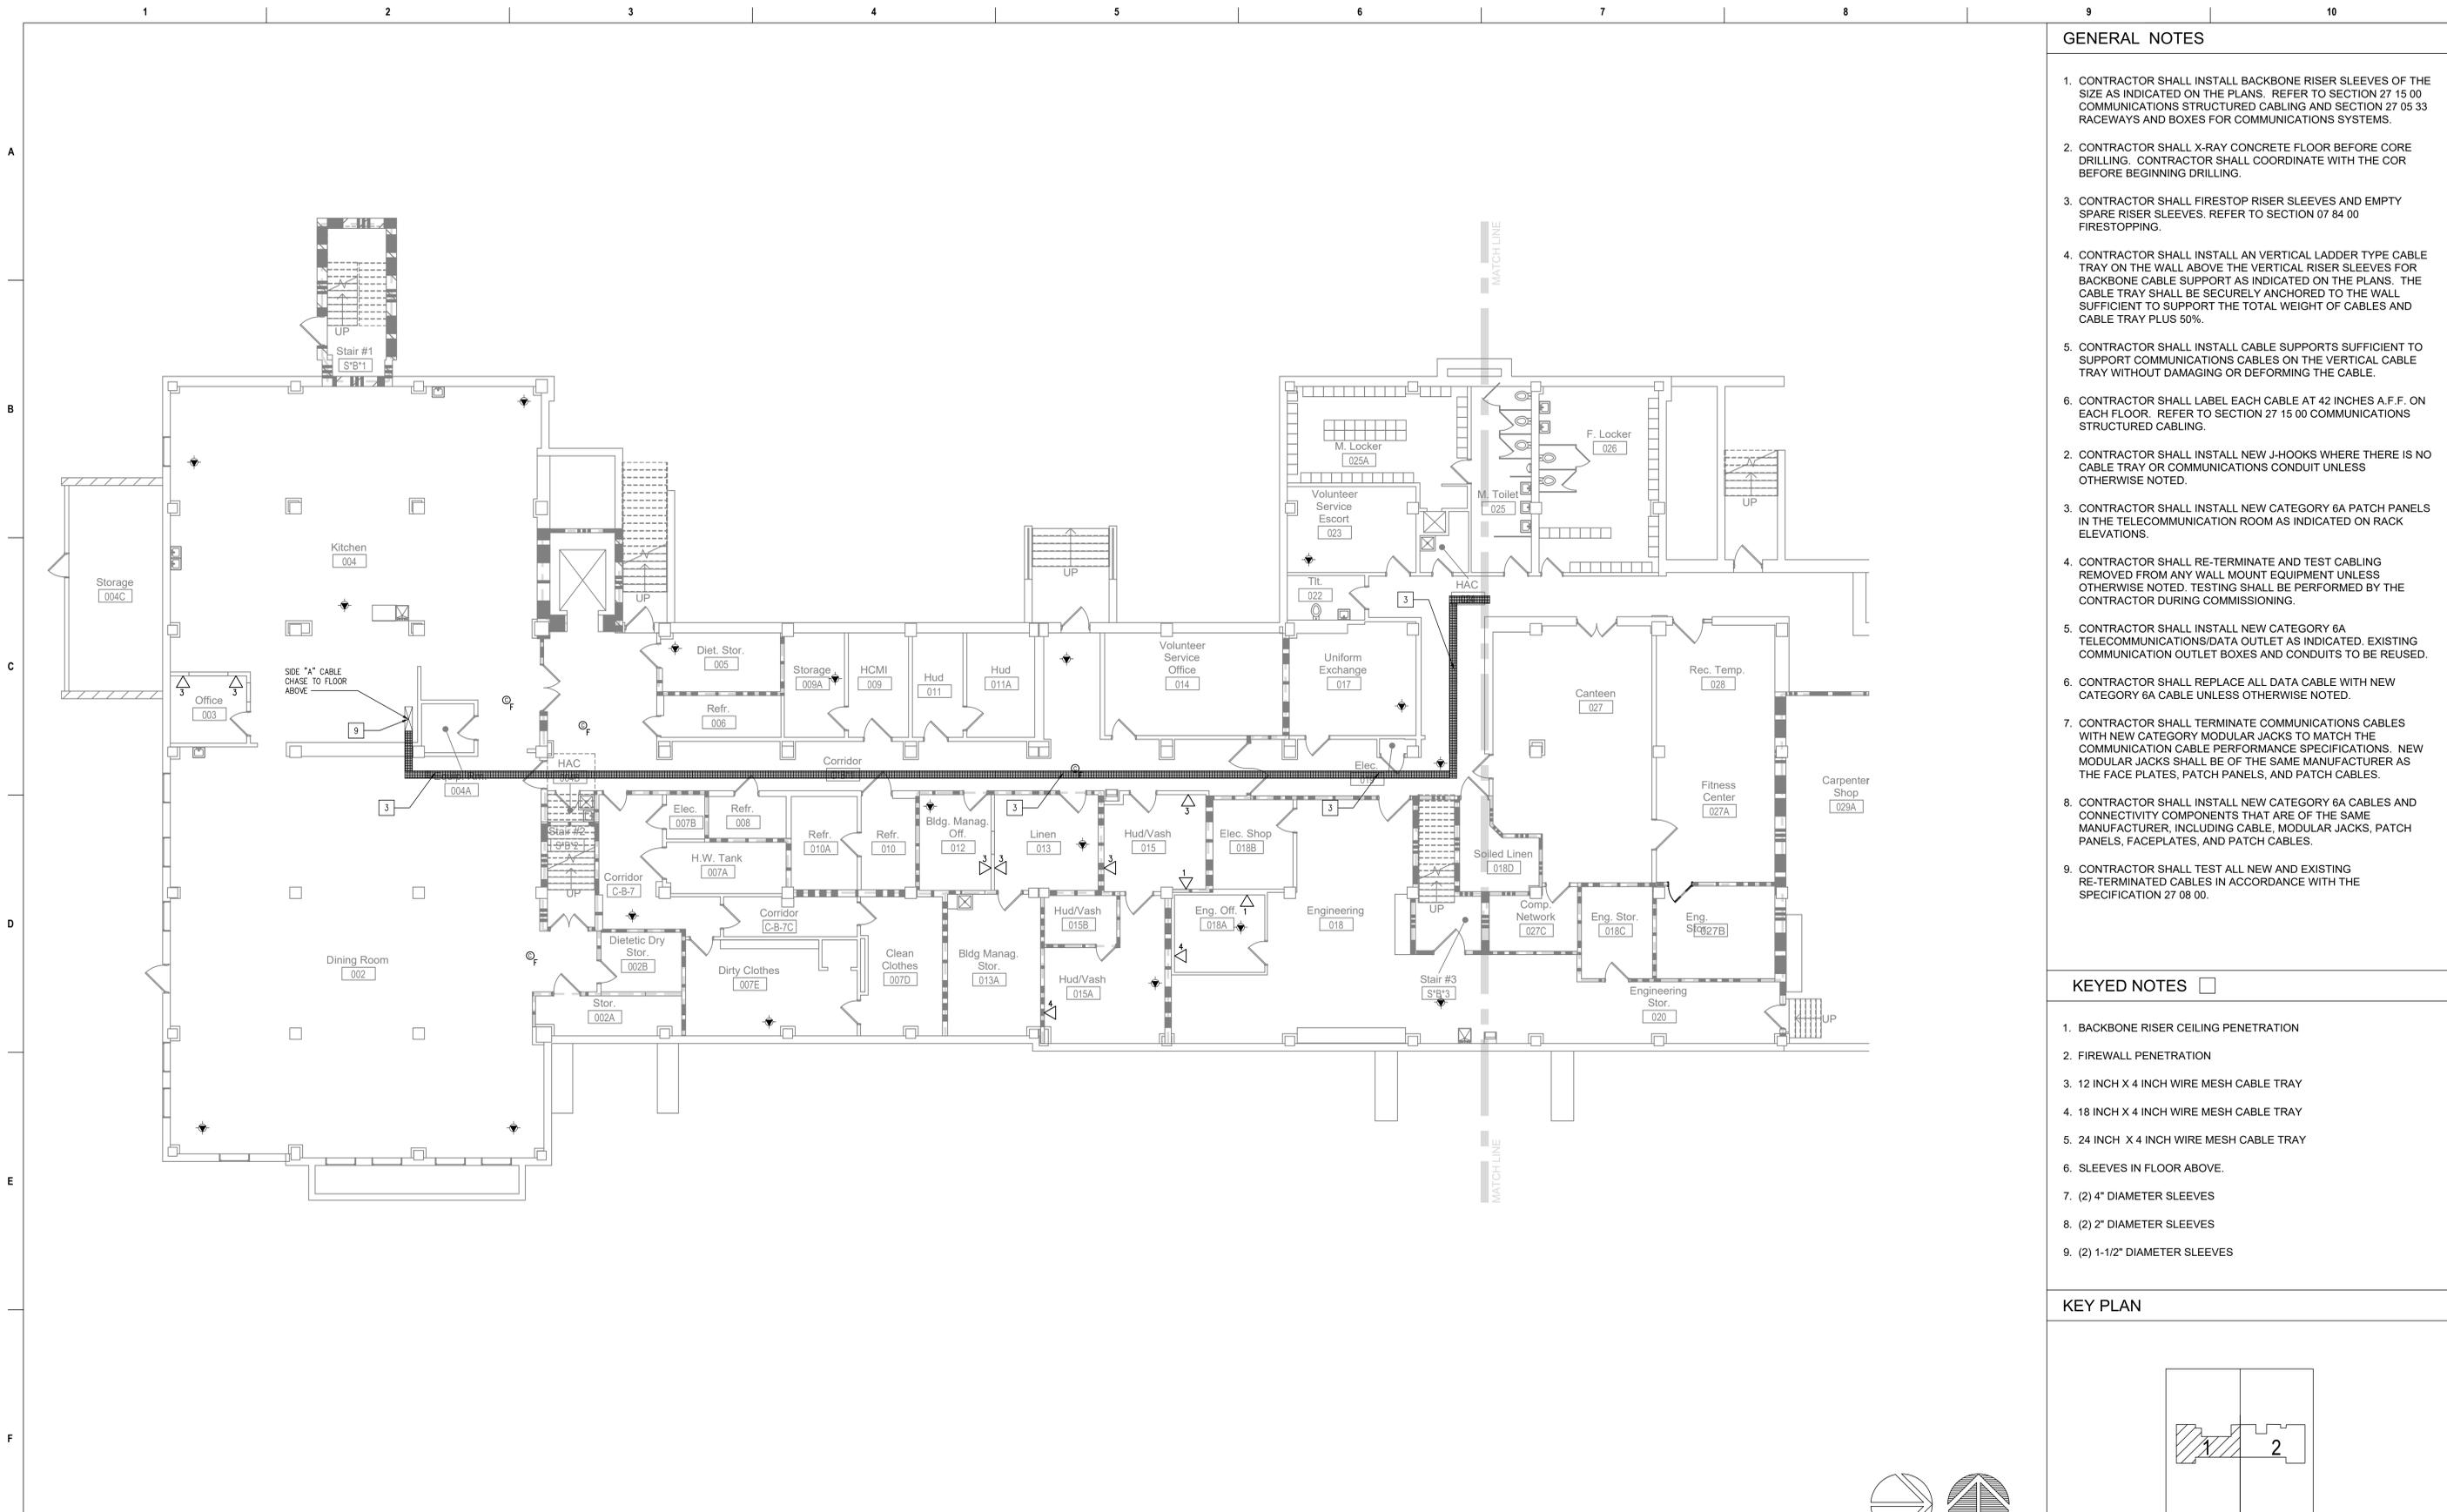

- ### GENERAL NOTES
- CONTRACTOR SHALL INSTALL BACKBONE RISER SLEEVES OF THE SIZE AS INDICATED ON THE PLANS. REFER TO SECTION 27 15 00 COMMUNICATIONS STRUCTURED CABLING AND SECTION 27 05 33 RACEWAYS AND BOXES FOR COMMUNICATIONS SYSTEMS.
 - CONTRACTOR SHALL X-RAY CONCRETE FLOOR BEFORE CORE DRILLING. CONTRACTOR SHALL COORDINATE WITH THE COR BEFORE BEGINNING DRILLING.
 - CONTRACTOR SHALL FIRESTOP RISER SLEEVES AND EMPTY SPARE RISER SLEEVES. REFER TO SECTION 07 84 00 FIRESTOPPING.
 - CONTRACTOR SHALL INSTALL AN VERTICAL LADDER TYPE CABLE TRAY ON THE WALL ABOVE THE VERTICAL RISER SLEEVES FOR BACKBONE CABLE SUPPORT AS INDICATED ON THE PLANS. THE CABLE TRAY SHALL BE SECURELY ANCHORED TO THE WALL SUFFICIENT TO SUPPORT THE TOTAL WEIGHT OF CABLES AND CABLE TRAY PLUS 50%.
 - CONTRACTOR SHALL INSTALL CABLE SUPPORTS SUFFICIENT TO SUPPORT COMMUNICATIONS CABLES ON THE VERTICAL CABLE TRAY WITHOUT DAMAGING OR DEFORMING THE CABLE.
 - CONTRACTOR SHALL LABEL EACH CABLE AT 42 INCHES A.F.F. ON EACH FLOOR. REFER TO SECTION 27 15 00 COMMUNICATIONS STRUCTURED CABLING.
 - CONTRACTOR SHALL INSTALL NEW J-HOOKS WHERE THERE IS NO CABLE TRAY OR COMMUNICATIONS CONDUIT UNLESS OTHERWISE NOTED.
 - CONTRACTOR SHALL INSTALL NEW CATEGORY 6A PATCH PANELS IN THE TELECOMMUNICATION ROOM AS INDICATED ON RACK ELEVATIONS.
 - CONTRACTOR SHALL RE-TERMINATE AND TEST CABLING REMOVED FROM ANY WALL MOUNT EQUIPMENT UNLESS OTHERWISE NOTED. TESTING SHALL BE PERFORMED BY THE CONTRACTOR DURING COMMISSIONING.
 - CONTRACTOR SHALL INSTALL NEW CATEGORY 6A TELECOMMUNICATIONS/DATA OUTLET AS INDICATED. EXISTING COMMUNICATION OUTLET BOXES AND CONDUITS TO BE REUSED.
 - CONTRACTOR SHALL REPLACE ALL DATA CABLE WITH NEW CATEGORY 6A CABLE UNLESS OTHERWISE NOTED.
 - CONTRACTOR SHALL TERMINATE COMMUNICATIONS CABLES WITH NEW CATEGORY MODULAR JACKS TO MATCH THE COMMUNICATION CABLE PERFORMANCE SPECIFICATIONS. NEW MODULAR JACKS SHALL BE OF THE SAME MANUFACTURER AS THE FACE PLATES, PATCH PANELS, AND PATCH CABLES.
 - CONTRACTOR SHALL INSTALL NEW CATEGORY 6A CABLES AND CONNECTIVITY COMPONENTS THAT ARE OF THE SAME MANUFACTURER, INCLUDING CABLE, MODULAR JACKS, PATCH PANELS, FACEPLATES, AND PATCH CABLES.
 - CONTRACTOR SHALL TEST ALL NEW AND EXISTING RE-TERMINATED CABLES IN ACCORDANCE WITH THE SPECIFICATION 27 08 00.

- ### KEYED NOTES
- BACKBONE RISER CEILING PENETRATION
 - FIREWALL PENETRATION
 - 12 INCH X 4 INCH WIRE MESH CABLE TRAY
 - 18 INCH X 4 INCH WIRE MESH CABLE TRAY
 - 24 INCH X 4 INCH WIRE MESH CABLE TRAY
 - SLEEVES IN FLOOR ABOVE.
 - (2) 4" DIAMETER SLEEVES
 - (2) 2" DIAMETER SLEEVES
 - (2) 1-1/2" DIAMETER SLEEVES

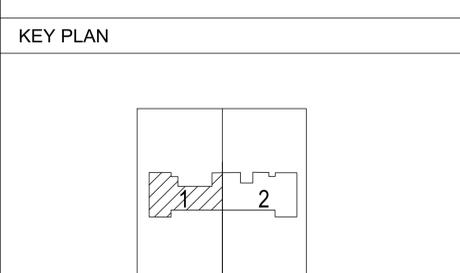

1 DATA OUTLET FLOOR PLAN - BLDG. 64 - BASEMENT SOUTH
SCALE: 1/8" = 1'-0"

Revisions:	Date:

CONSULTANT

8718 Botts Lane
San Antonio, Texas 78217
www.hfscompany.com

Phone: (210) 816-4784
Fax: (210) 881-6808
jbianco@hfscompany.com

PROJECT MANAGEMENT

8718 Botts Lane
San Antonio, Texas 78217
www.hfscompany.com

Phone: (210) 816-4784
Fax: (210) 881-6808
jbianco@hfscompany.com

Raymond Martinez Jr.
BICSI ID # 143493
EXPIRES 12-31-24
RCDD
04-MAY-22

Construction and Facilities Management

Drawing Title
BLDG. 64 - BASEMENT - SOUTH TECHNOLOGY DATA OUTLET PLAN

Approved: Project Director

Phase
100% CONSTRUCTION DOCUMENTS

FULLY SPRINKLERED

Project Title
CINCINNATI VAMC EHRM INFRASTRUCTURE UPGRADES

Location
3200 VINE ST., CINCINNATI, OH

Issue Date
04-MAY-2022


Checked
NA

Drawn
RMjr

Project Number
539-21-701

Building Number
64

Drawing Number
TN-270-F.64.BS

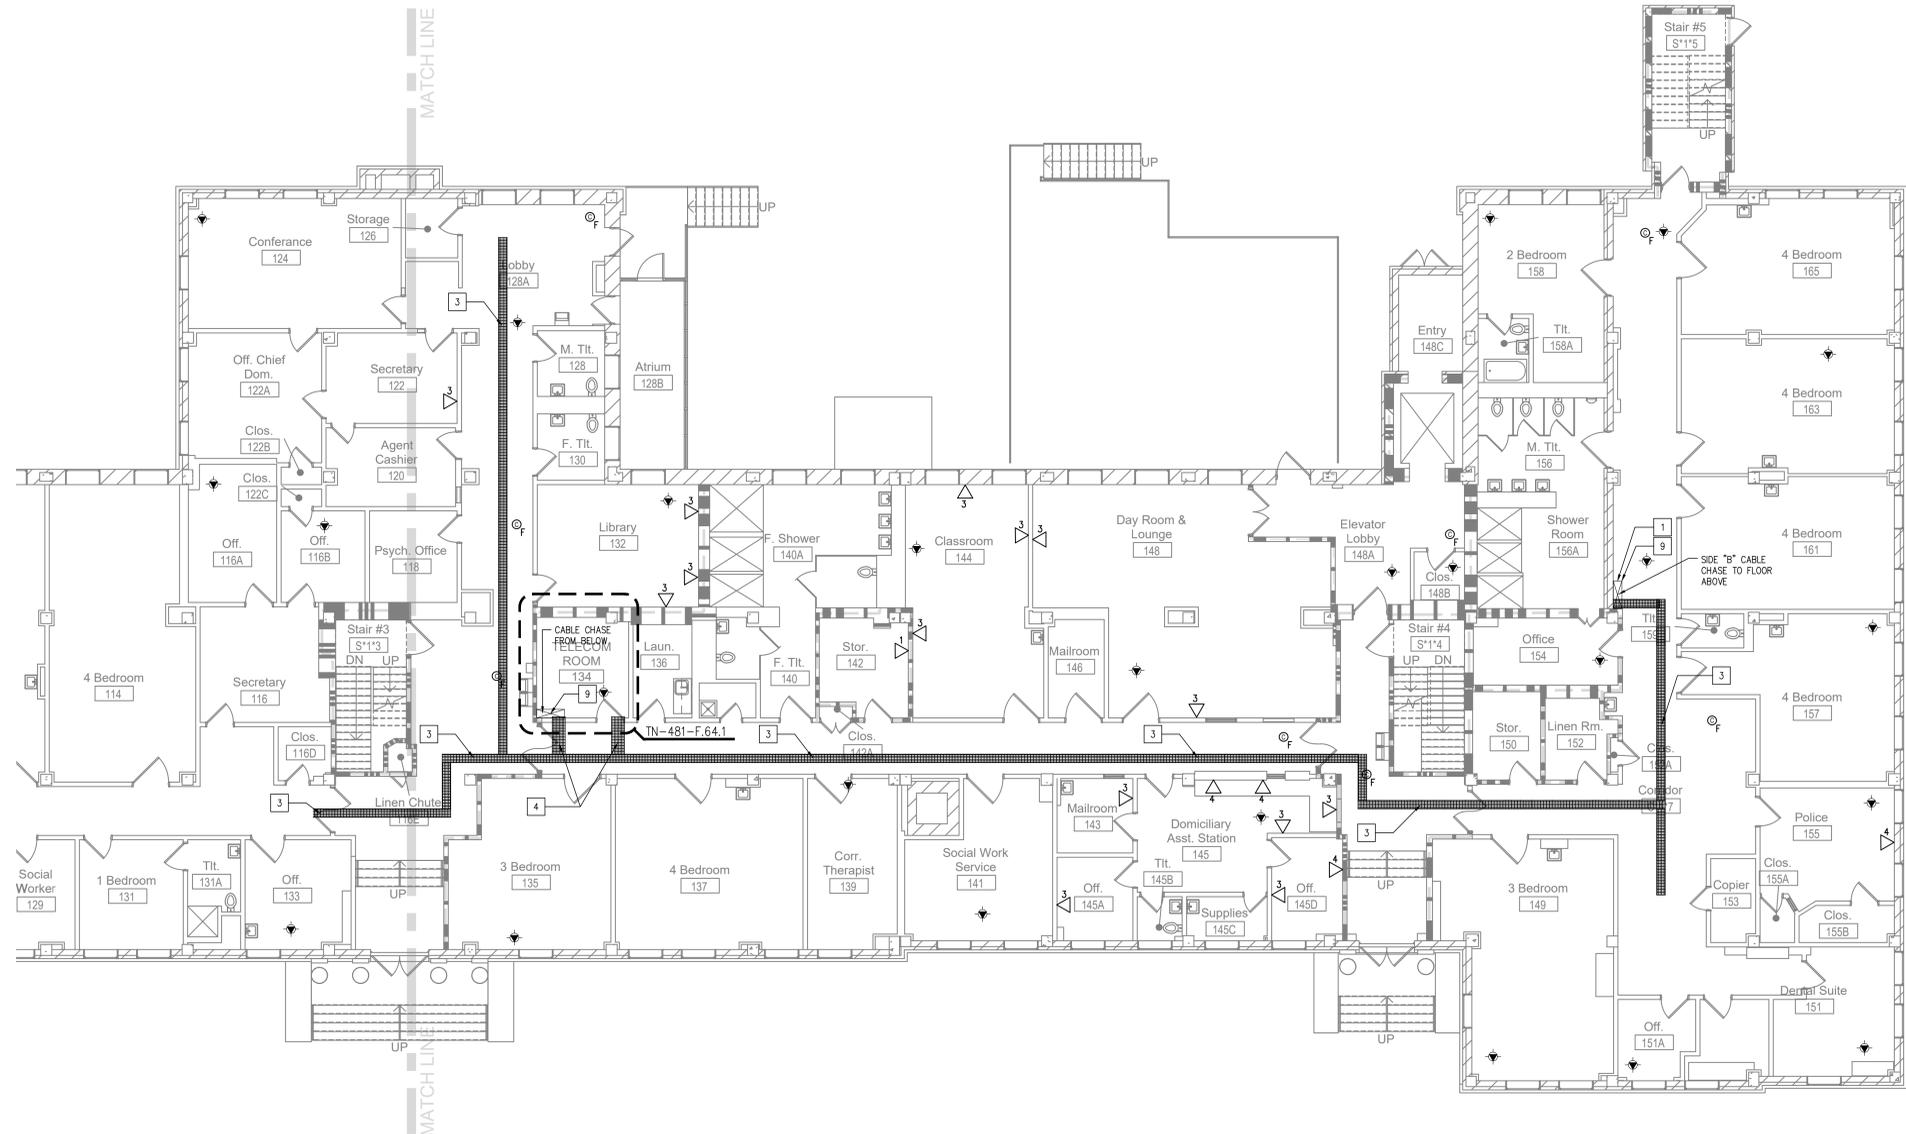


GENERAL NOTES

1. CONTRACTOR SHALL INSTALL BACKBONE RISER SLEEVES OF THE SIZE AS INDICATED ON THE PLANS. REFER TO SECTION 27 15 00 COMMUNICATIONS STRUCTURED CABLING AND SECTION 27 05 33 RACEWAYS AND BOXES FOR COMMUNICATIONS SYSTEMS.
2. CONTRACTOR SHALL X-RAY CONCRETE FLOOR BEFORE CORE DRILLING. CONTRACTOR SHALL COORDINATE WITH THE COR BEFORE BEGINNING DRILLING.
3. CONTRACTOR SHALL FIRESTOP RISER SLEEVES AND EMPTY SPARE RISER SLEEVES. REFER TO SECTION 07 84 00 FIRESTOPPING.
4. CONTRACTOR SHALL INSTALL AN VERTICAL LADDER TYPE CABLE TRAY ON THE WALL ABOVE THE VERTICAL RISER SLEEVES FOR BACKBONE CABLE SUPPORT AS INDICATED ON THE PLANS. THE CABLE TRAY SHALL BE SECURELY ANCHORED TO THE WALL SUFFICIENT TO SUPPORT THE TOTAL WEIGHT OF CABLES AND CABLE TRAY PLUS 50%.
5. CONTRACTOR SHALL INSTALL CABLE SUPPORTS SUFFICIENT TO SUPPORT COMMUNICATIONS CABLES ON THE VERTICAL CABLE TRAY WITHOUT DAMAGING OR DEFORMING THE CABLE.
6. CONTRACTOR SHALL LABEL EACH CABLE AT 42 INCHES A.F.F. ON EACH FLOOR. REFER TO SECTION 27 15 00 COMMUNICATIONS STRUCTURED CABLING.
7. CONTRACTOR SHALL INSTALL NEW J-HOOKS WHERE THERE IS NO CABLE TRAY OR COMMUNICATIONS CONDUIT UNLESS OTHERWISE NOTED.
8. CONTRACTOR SHALL INSTALL NEW CATEGORY 6A PATCH PANELS IN THE TELECOMMUNICATION ROOM AS INDICATED ON RACK ELEVATIONS.
9. CONTRACTOR SHALL RE-TERMINATE AND TEST CABLING REMOVED FROM ANY WALL MOUNT EQUIPMENT UNLESS OTHERWISE NOTED. TESTING SHALL BE PERFORMED BY THE CONTRACTOR DURING COMMISSIONING.
10. CONTRACTOR SHALL INSTALL NEW CATEGORY 6A TELECOMMUNICATIONS/DATA OUTLET AS INDICATED. EXISTING COMMUNICATION OUTLET BOXES AND CONDUITS TO BE REUSED.
11. CONTRACTOR SHALL REPLACE ALL DATA CABLE WITH NEW CATEGORY 6A CABLE UNLESS OTHERWISE NOTED.
12. CONTRACTOR SHALL TERMINATE COMMUNICATIONS CABLES WITH NEW CATEGORY 6A MODULAR JACKS TO MATCH THE COMMUNICATION CABLE PERFORMANCE SPECIFICATIONS. NEW MODULAR JACKS SHALL BE OF THE SAME MANUFACTURER AS THE FACE PLATES, PATCH PANELS, AND PATCH CABLES.
13. CONTRACTOR SHALL INSTALL NEW CATEGORY 6A CABLES AND CONNECTIVITY COMPONENTS THAT ARE OF THE SAME MANUFACTURER, INCLUDING CABLE, MODULAR JACKS, PATCH PANELS, FACEPLATES, AND PATCH CABLES.
14. CONTRACTOR SHALL TEST ALL NEW AND EXISTING RE-TERMINATED CABLES IN ACCORDANCE WITH THE SPECIFICATION 27 08 00.


KEYED NOTES

1. BACKBONE RISER CEILING PENETRATION
2. FIREWALL PENETRATION
3. 12 INCH X 4 INCH WIRE MESH CABLE TRAY
4. 18 INCH X 4 INCH WIRE MESH CABLE TRAY
5. 24 INCH X 4 INCH WIRE MESH CABLE TRAY
6. SLEEVES IN FLOOR ABOVE.
7. (2) 4" DIAMETER SLEEVES
8. (2) 2" DIAMETER SLEEVES
9. (2) 1-1/2" DIAMETER SLEEVES

KEY PLAN

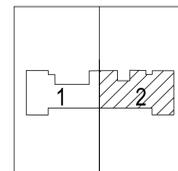

 1 FLOOR PLAN - BLDG. 64 FIRST FLOOR NORTH
SCALE: 1/8" = 1'-0"



Revisions:	Date:

CONSULTANT

8718 Botts Lane
San Antonio, Texas 78217
www.hfscpany.com

Phone: (210) 816-4784
Fax: (210) 881-6808
jbianco@hfscpany.com

PROJECT MANAGEMENT

8718 Botts Lane
San Antonio, Texas 78217
www.hfscpany.com

Phone: (210) 816-4784
Fax: (210) 881-6808
jbianco@hfscpany.com

REGISTERED COMMUNICATIONS DISTRIBUTION DESIGNER

Raymond Martinez Jr.
BICSI ID # 143493
Expires 12-31-24
RCDD
04-MAY-22

Construction and Facilities Management

U.S. Department of Veterans Affairs

Drawing Title
BLDG. 64 - FIRST FLOOR - NORTH TECHNOLOGY DATA OUTLET PLAN-

Approved: Project Director

Phase
100% CONSTRUCTION DOCUMENTS

FULLY SPRINKLERED

Project Title
CINCINNATI VAMC EHRM INFRASTRUCTURE UPGRADES

Location
3200 VINE ST., CINCINNATI, OH

Issue Date
04-MAY-2022


Checked
NA

Drawn
RMjr

Project Number
539-21-701

Building Number
64

Drawing Number
TN-271-F.64.1N

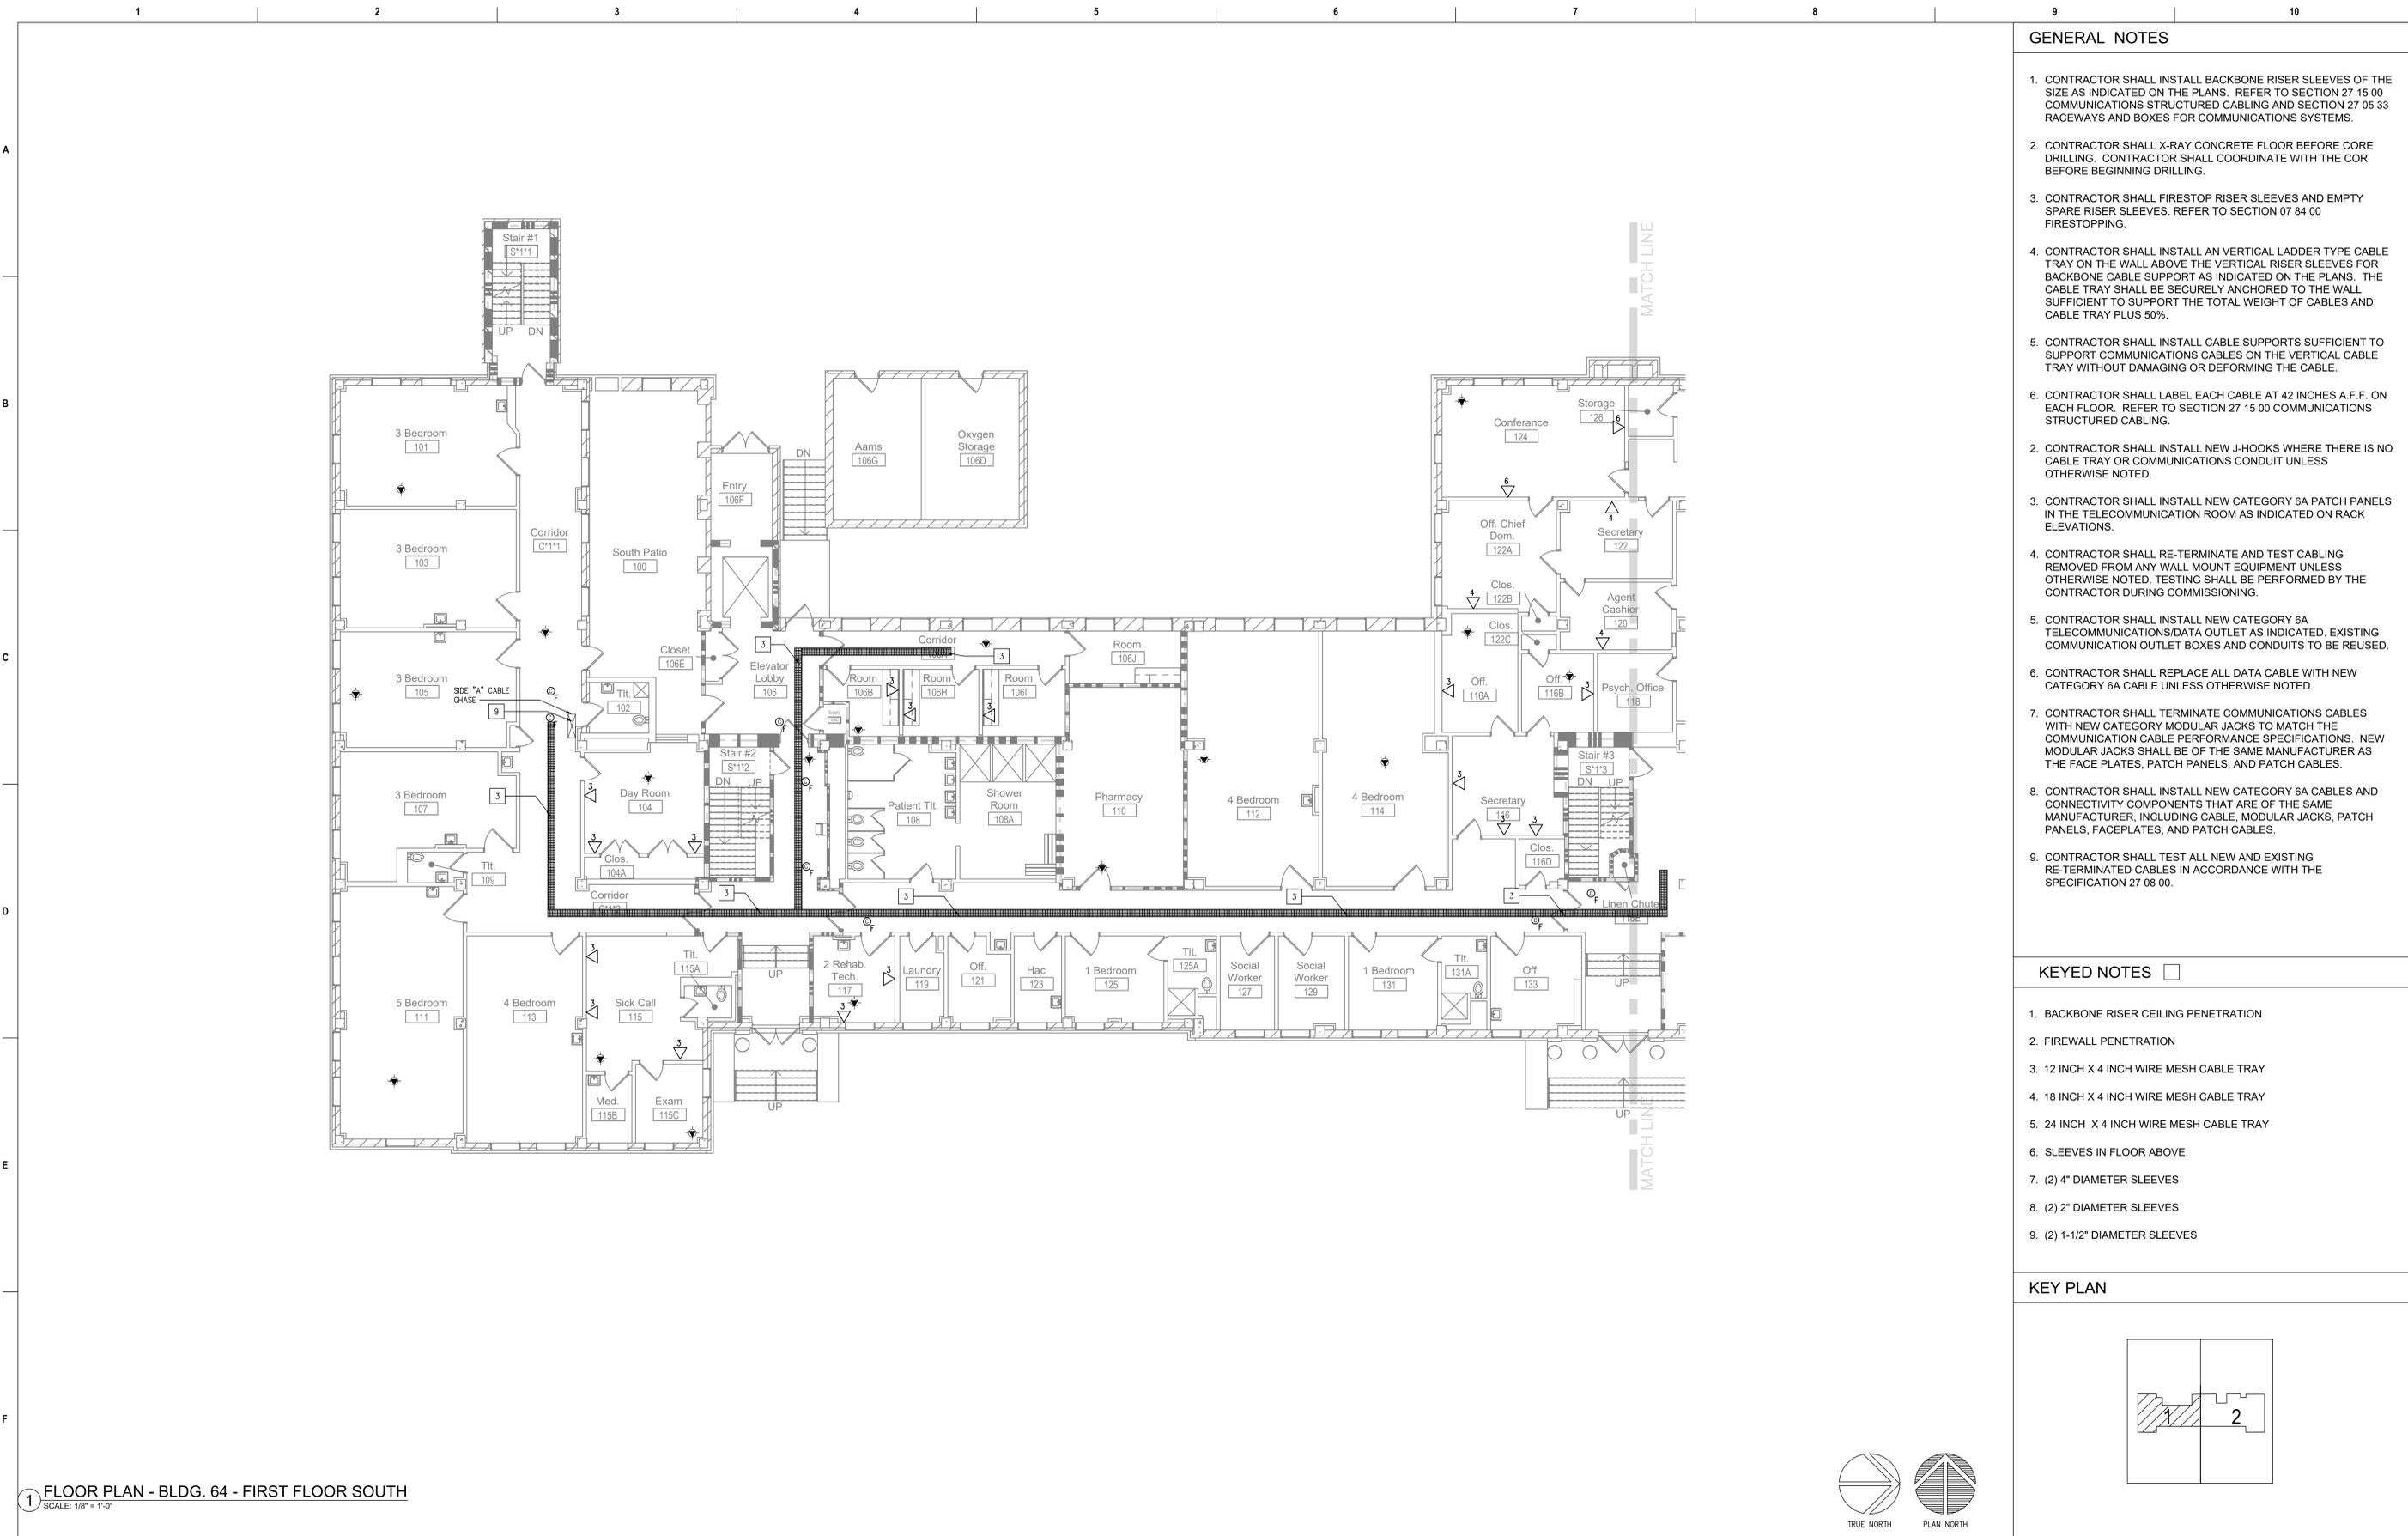


GENERAL NOTES

- CONTRACTOR SHALL INSTALL BACKBONE RISER SLEEVES OF THE SIZE AS INDICATED ON THE PLANS. REFER TO SECTION 27 15 00 COMMUNICATIONS STRUCTURED CABLING AND SECTION 27 05 33 RACEWAYS AND BOXES FOR COMMUNICATIONS SYSTEMS.
- CONTRACTOR SHALL X-RAY CONCRETE FLOOR BEFORE CORE DRILLING. CONTRACTOR SHALL COORDINATE WITH THE COR BEFORE BEGINNING DRILLING.
- CONTRACTOR SHALL FIRESTOP RISER SLEEVES AND EMPTY SPARE RISER SLEEVES. REFER TO SECTION 07 84 00 FIRESTOPPING.
- CONTRACTOR SHALL INSTALL AN VERTICAL LADDER TYPE CABLE TRAY ON THE WALL ABOVE THE VERTICAL RISER SLEEVES FOR BACKBONE CABLE SUPPORT AS INDICATED ON THE PLANS. THE CABLE TRAY SHALL BE SECURELY ANCHORED TO THE WALL SUFFICIENT TO SUPPORT THE TOTAL WEIGHT OF CABLES AND CABLE TRAY PLUS 50%.
- CONTRACTOR SHALL INSTALL CABLE SUPPORTS SUFFICIENT TO SUPPORT COMMUNICATIONS CABLES ON THE VERTICAL CABLE TRAY WITHOUT DAMAGING OR DEFORMING THE CABLE.
- CONTRACTOR SHALL LABEL EACH CABLE AT 42 INCHES A.F.F. ON EACH FLOOR. REFER TO SECTION 27 15 00 COMMUNICATIONS STRUCTURED CABLING.
- CONTRACTOR SHALL INSTALL NEW J-HOOKS WHERE THERE IS NO CABLE TRAY OR COMMUNICATIONS CONDUIT UNLESS OTHERWISE NOTED.
- CONTRACTOR SHALL INSTALL NEW CATEGORY 6A PATCH PANELS IN THE TELECOMMUNICATION ROOM AS INDICATED ON RACK ELEVATIONS.
- CONTRACTOR SHALL RE-TERMINATE AND TEST CABLING REMOVED FROM ANY WALL MOUNT EQUIPMENT UNLESS OTHERWISE NOTED. TESTING SHALL BE PERFORMED BY THE CONTRACTOR DURING COMMISSIONING.
- CONTRACTOR SHALL INSTALL NEW CATEGORY 6A TELECOMMUNICATIONS/DATA OUTLET AS INDICATED. EXISTING COMMUNICATION OUTLET BOXES AND CONDUITS TO BE REUSED.
- CONTRACTOR SHALL REPLACE ALL DATA CABLE WITH NEW CATEGORY 6A CABLE UNLESS OTHERWISE NOTED.
- CONTRACTOR SHALL TERMINATE COMMUNICATIONS CABLES WITH NEW CATEGORY MODULAR JACKS TO MATCH THE COMMUNICATION CABLE PERFORMANCE SPECIFICATIONS. NEW MODULAR JACKS SHALL BE OF THE SAME MANUFACTURER AS THE FACE PLATES, PATCH PANELS, AND PATCH CABLES.
- CONTRACTOR SHALL INSTALL NEW CATEGORY 6A CABLES AND CONNECTIVITY COMPONENTS THAT ARE OF THE SAME MANUFACTURER, INCLUDING CABLE, MODULAR JACKS, PATCH PANELS, FACEPLATES, AND PATCH CABLES.
- CONTRACTOR SHALL TEST ALL NEW AND EXISTING RE-TERMINATED CABLES IN ACCORDANCE WITH THE SPECIFICATION 27 08 00.


KEYED NOTES

- BACKBONE RISER CEILING PENETRATION
- FIREWALL PENETRATION
- 12 INCH X 4 INCH WIRE MESH CABLE TRAY
- 18 INCH X 4 INCH WIRE MESH CABLE TRAY
- 24 INCH X 4 INCH WIRE MESH CABLE TRAY
- SLEEVES IN FLOOR ABOVE.
- (2) 4" DIAMETER SLEEVES
- (2) 2" DIAMETER SLEEVES
- (2) 1-1/2" DIAMETER SLEEVES

KEY PLAN

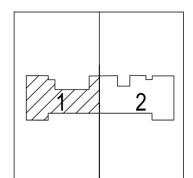

 1 FLOOR PLAN - BLDG. 64 - FIRST FLOOR SOUTH
SCALE: 1/8" = 1'-0"



Revisions:	Date:

CONSULTANT

8718 Botts Lane
San Antonio, Texas 78217
www.hfscorporation.com

Phone: (210) 816-4784
Fax: (210) 881-6808
jbianco@hfscorporation.com

PROJECT MANAGEMENT

8718 Botts Lane
San Antonio, Texas 78217
www.hfscorporation.com

Phone: (210) 816-4784
Fax: (210) 881-6808
jbianco@hfscorporation.com

Bicsi
REGISTERED COMMUNICATIONS DISTRIBUTION DESIGNER
Raymond Martinez Jr.
BICSI ID # 143493
Expires 12-31-24
RCDD
04-MAY-22

Construction and Facilities Management

Drawing Title
BLDG. 64 - FIRST FLOOR - SOUTH TECHNOLOGY DATA OUTLET PLAN

Approved: Project Director

Phase
100% CONSTRUCTION DOCUMENTS

FULLY SPRINKLERED

Project Title
CINCINNATI VAMC EHRM INFRASTRUCTURE UPGRADES

Location
3200 VINE ST., CINCINNATI, OH

Issue Date
04-MAY-2022


Checked
NA

Drawn
RMjr

Project Number
539-21-701

Building Number
64

Drawing Number
TN-271-F.64.1S

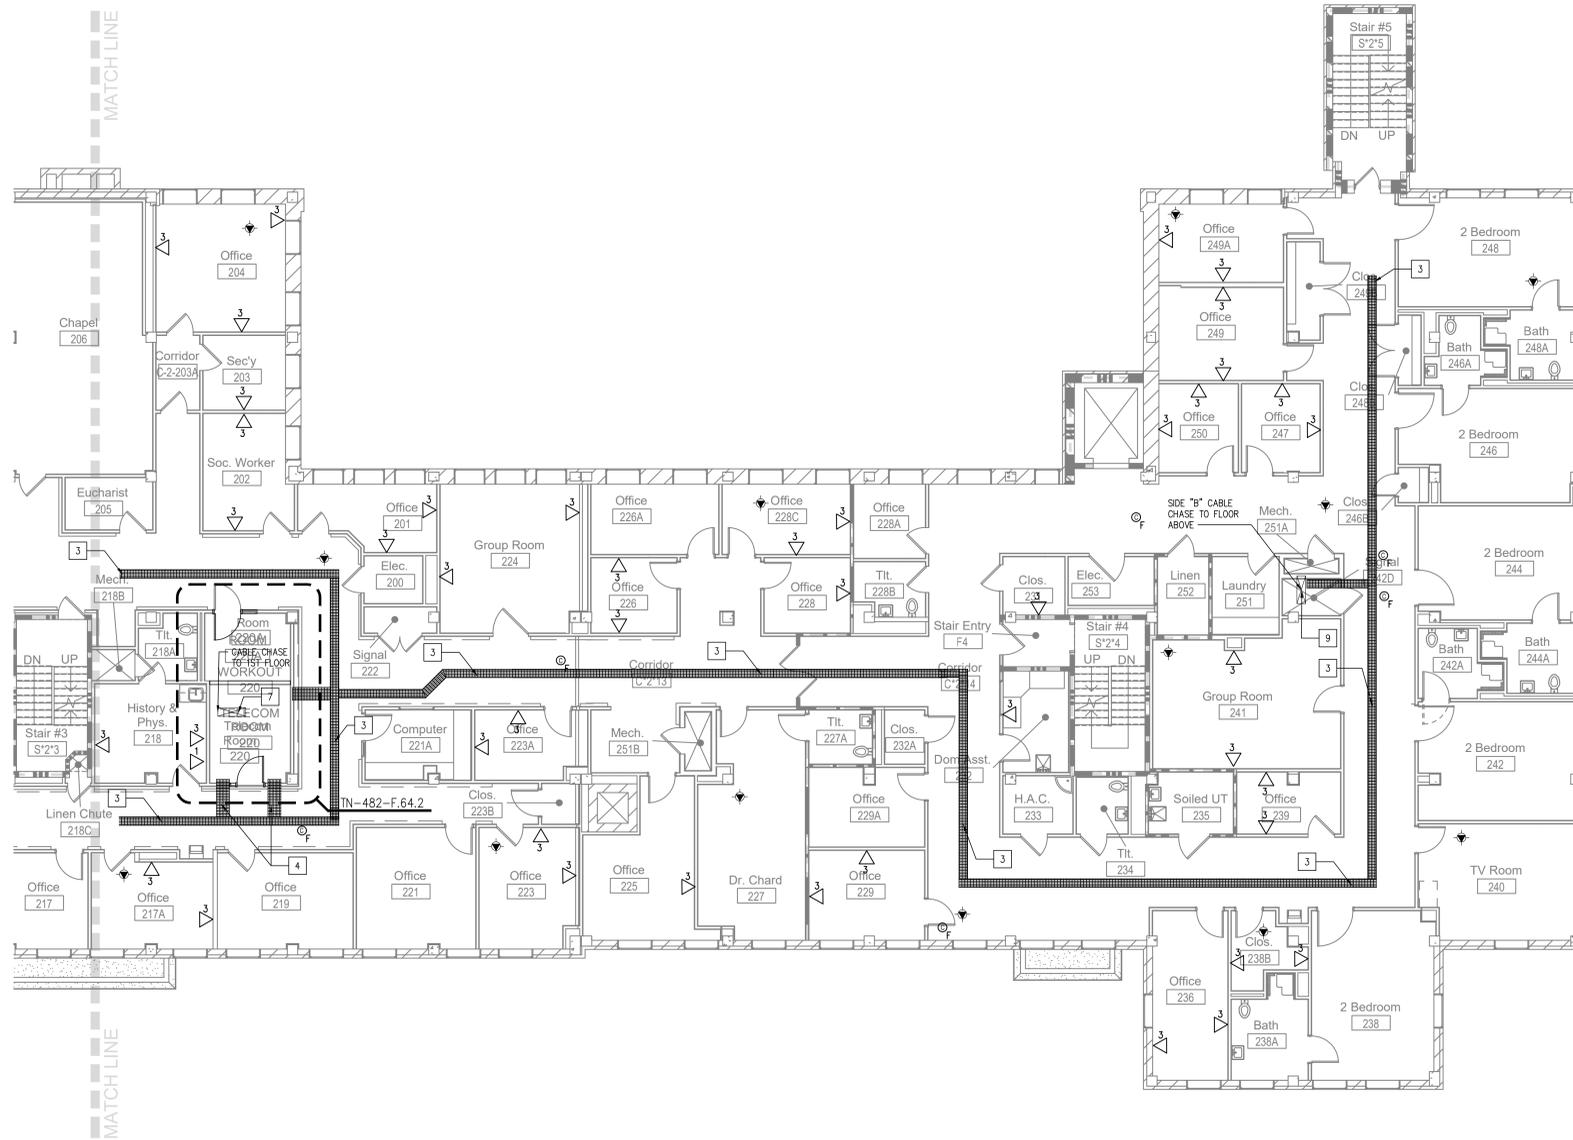



GENERAL NOTES

1. CONTRACTOR SHALL INSTALL BACKBONE RISER SLEEVES OF THE SIZE AS INDICATED ON THE PLANS. REFER TO SECTION 27 15 00 COMMUNICATIONS STRUCTURED CABLING AND SECTION 27 05 33 RACEWAYS AND BOXES FOR COMMUNICATIONS SYSTEMS.
2. CONTRACTOR SHALL X-RAY CONCRETE FLOOR BEFORE CORE DRILLING. CONTRACTOR SHALL COORDINATE WITH THE COR BEFORE BEGINNING DRILLING.
3. CONTRACTOR SHALL FIRESTOP RISER SLEEVES AND EMPTY SPARE RISER SLEEVES. REFER TO SECTION 07 84 00 FIRESTOPPING.
4. CONTRACTOR SHALL INSTALL AN VERTICAL LADDER TYPE CABLE TRAY ON THE WALL ABOVE THE VERTICAL RISER SLEEVES FOR BACKBONE CABLE SUPPORT AS INDICATED ON THE PLANS. THE CABLE TRAY SHALL BE SECURELY ANCHORED TO THE WALL SUFFICIENT TO SUPPORT THE TOTAL WEIGHT OF CABLES AND CABLE TRAY PLUS 50%.
5. CONTRACTOR SHALL INSTALL CABLE SUPPORTS SUFFICIENT TO SUPPORT COMMUNICATIONS CABLES ON THE VERTICAL CABLE TRAY WITHOUT DAMAGING OR DEFORMING THE CABLE.
6. CONTRACTOR SHALL LABEL EACH CABLE AT 42 INCHES A.F.F. ON EACH FLOOR. REFER TO SECTION 27 15 00 COMMUNICATIONS STRUCTURED CABLING.
7. CONTRACTOR SHALL INSTALL NEW J-HOOKS WHERE THERE IS NO CABLE TRAY OR COMMUNICATIONS CONDUIT UNLESS OTHERWISE NOTED.
8. CONTRACTOR SHALL INSTALL NEW CATEGORY 6A PATCH PANELS IN THE TELECOMMUNICATION ROOM AS INDICATED ON RACK ELEVATIONS.
9. CONTRACTOR SHALL RE-TERMINATE AND TEST CABLING REMOVED FROM ANY WALL MOUNT EQUIPMENT UNLESS OTHERWISE NOTED. TESTING SHALL BE PERFORMED BY THE CONTRACTOR DURING COMMISSIONING.
10. CONTRACTOR SHALL INSTALL NEW CATEGORY 6A TELECOMMUNICATIONS/DATA OUTLET AS INDICATED. EXISTING COMMUNICATION OUTLET BOXES AND CONDUITS TO BE REUSED.
11. CONTRACTOR SHALL REPLACE ALL DATA CABLE WITH NEW CATEGORY 6A CABLE UNLESS OTHERWISE NOTED.
12. CONTRACTOR SHALL TERMINATE COMMUNICATIONS CABLES WITH NEW CATEGORY MODULAR JACKS TO MATCH THE COMMUNICATION CABLE PERFORMANCE SPECIFICATIONS. NEW MODULAR JACKS SHALL BE OF THE SAME MANUFACTURER AS THE FACE PLATES, PATCH PANELS, AND PATCH CABLES.
13. CONTRACTOR SHALL INSTALL NEW CATEGORY 6A CABLES AND CONNECTIVITY COMPONENTS THAT ARE OF THE SAME MANUFACTURER, INCLUDING CABLE, MODULAR JACKS, PATCH PANELS, FACEPLATES, AND PATCH CABLES.
14. CONTRACTOR SHALL TEST ALL NEW AND EXISTING RE-TERMINATED CABLES IN ACCORDANCE WITH THE SPECIFICATION 27 08 00.

KEYED NOTES

1. BACKBONE RISER CEILING PENETRATION
2. FIREWALL PENETRATION
3. 12 INCH X 4 INCH WIRE MESH CABLE TRAY
4. 18 INCH X 4 INCH WIRE MESH CABLE TRAY
5. 24 INCH X 4 INCH WIRE MESH CABLE TRAY
6. SLEEVES IN FLOOR ABOVE.
7. (2) 4" DIAMETER SLEEVES
8. (2) 2" DIAMETER SLEEVES
9. (2) 1-1/2" DIAMETER SLEEVES

 KEY PLAN

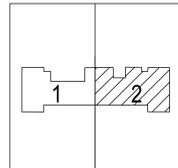

1 FLOOR PLAN - BLDG. 64 - SECOND FLOOR NORTH
SCALE: 1/8" = 1'-0"

Revisions:	Date:

CONSULTANT

HFS

C O M P A N Y

8718 Botts Lane Phone: (210) 816-4784
San Antonio, Texas 78217 Fax: (210) 881-6808
www.hfscompany.com jbianco@hfscompany.com

PROJECT MANAGEMENT

HFS

C O M P A N Y

8718 Botts Lane Phone: (210) 816-4784
San Antonio, Texas 78217 Fax: (210) 881-6808
www.hfscompany.com jbianco@hfscompany.com

Bicsi

Raymond Martinez Jr.
BICSI ID # 143493
Expires 03-31-24
RCDD

04-MAY-22

Construction and Facilities Management

VA U.S. Department of Veterans Affairs

Drawing Title
BLDG. 64 - SECOND FLOOR - NORTH TECHNOLOGY DATA OUTLET PLAN

Approved: Project Director

Phase
100% CONSTRUCTION DOCUMENTS

FULLY SPRINKLERED

Project Title
CINCINNATI VAMC EHRM INFRASTRUCTURE UPGRADES

Location
3200 VINE ST., CINCINNATI, OH

Issue Date
04-MAY-2022


Checked
NA

Drawn
RMjr

Project Number
539-21-701

Building Number
64

Drawing Number
TN-272-F.64.2N

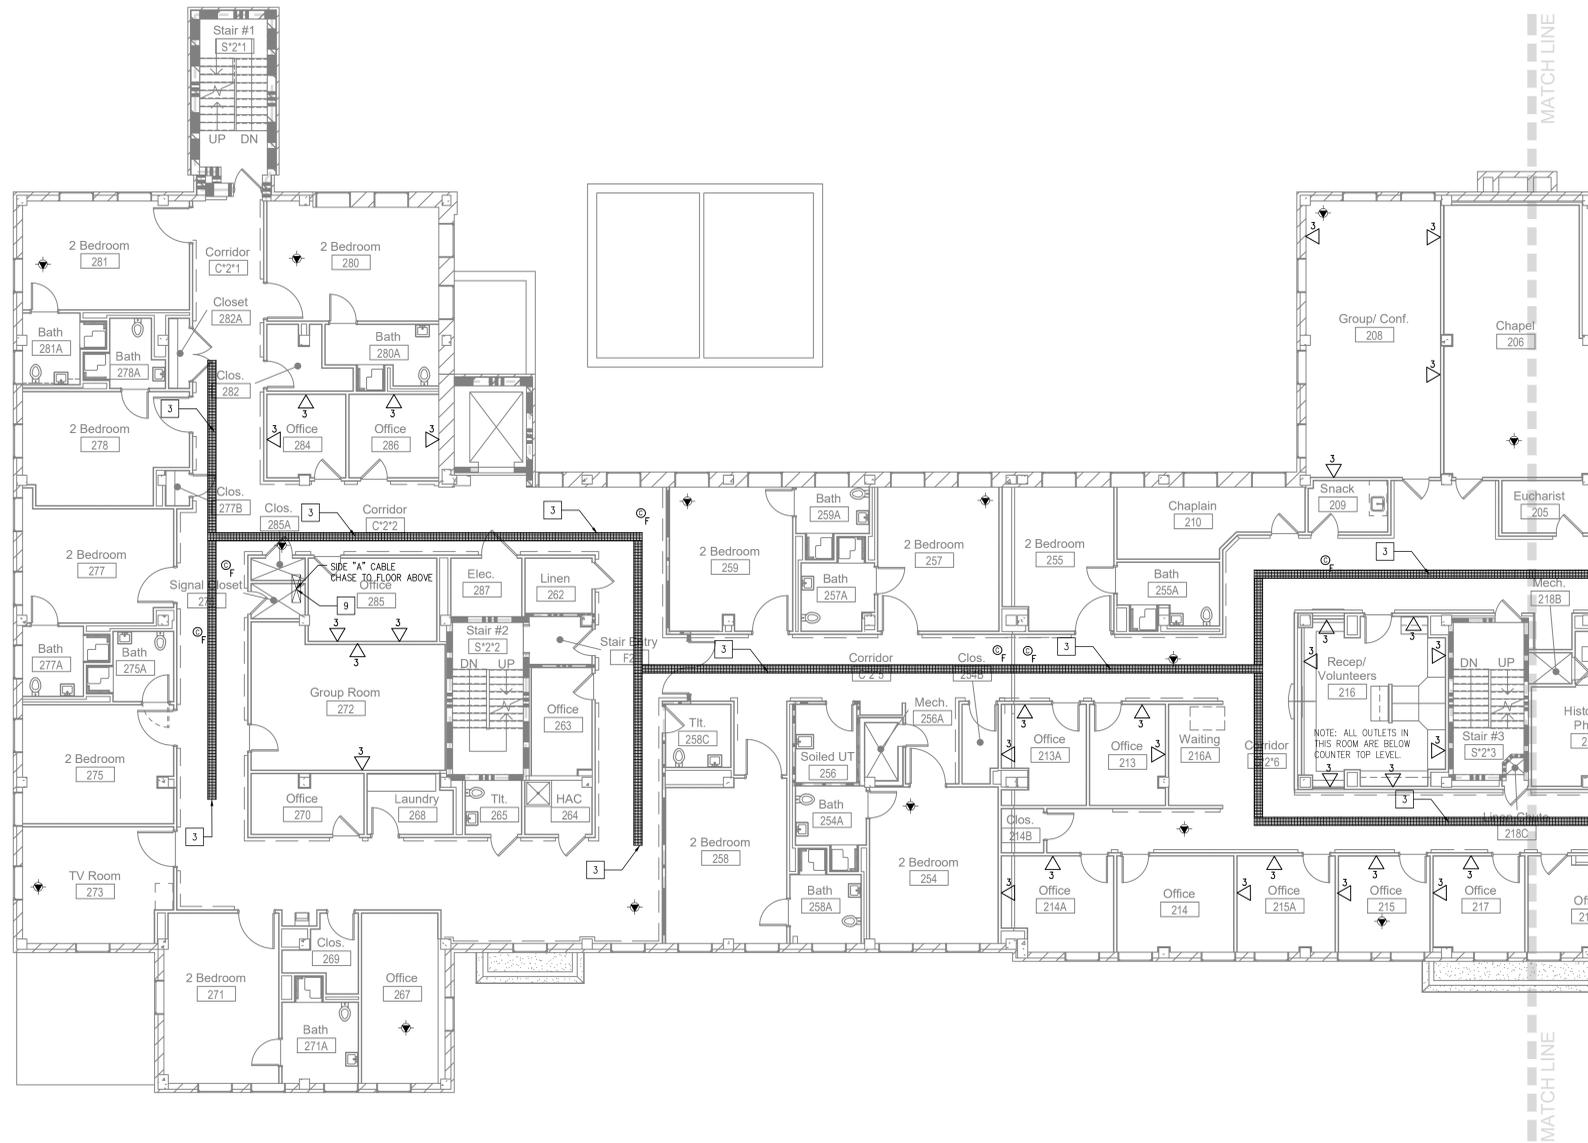



GENERAL NOTES

- CONTRACTOR SHALL INSTALL BACKBONE RISER SLEEVES OF THE SIZE AS INDICATED ON THE PLANS. REFER TO SECTION 27 15 00 COMMUNICATIONS STRUCTURED CABLING AND SECTION 27 05 33 RACEWAYS AND BOXES FOR COMMUNICATIONS SYSTEMS.
- CONTRACTOR SHALL X-RAY CONCRETE FLOOR BEFORE CORE DRILLING. CONTRACTOR SHALL COORDINATE WITH THE COR BEFORE BEGINNING DRILLING.
- CONTRACTOR SHALL FIRESTOP RISER SLEEVES AND EMPTY SPARE RISER SLEEVES. REFER TO SECTION 07 84 00 FIRESTOPPING.
- CONTRACTOR SHALL INSTALL AN VERTICAL LADDER TYPE CABLE TRAY ON THE WALL ABOVE THE VERTICAL RISER SLEEVES FOR BACKBONE CABLE SUPPORT AS INDICATED ON THE PLANS. THE CABLE TRAY SHALL BE SECURELY ANCHORED TO THE WALL SUFFICIENT TO SUPPORT THE TOTAL WEIGHT OF CABLES AND CABLE TRAY PLUS 50%.
- CONTRACTOR SHALL INSTALL CABLE SUPPORTS SUFFICIENT TO SUPPORT COMMUNICATIONS CABLES ON THE VERTICAL CABLE TRAY WITHOUT DAMAGING OR DEFORMING THE CABLE.
- CONTRACTOR SHALL LABEL EACH CABLE AT 42 INCHES A.F.F. ON EACH FLOOR. REFER TO SECTION 27 15 00 COMMUNICATIONS STRUCTURED CABLING.
- CONTRACTOR SHALL INSTALL NEW J-HOOKS WHERE THERE IS NO CABLE TRAY OR COMMUNICATIONS CONDUIT UNLESS OTHERWISE NOTED.
- CONTRACTOR SHALL INSTALL NEW CATEGORY 6A PATCH PANELS IN THE TELECOMMUNICATION ROOM AS INDICATED ON RACK ELEVATIONS.
- CONTRACTOR SHALL RE-TERMINATE AND TEST CABLING REMOVED FROM ANY WALL MOUNT EQUIPMENT UNLESS OTHERWISE NOTED. TESTING SHALL BE PERFORMED BY THE CONTRACTOR DURING COMMISSIONING.
- CONTRACTOR SHALL INSTALL NEW CATEGORY 6A TELECOMMUNICATIONS/DATA OUTLET AS INDICATED. EXISTING COMMUNICATION OUTLET BOXES AND CONDUITS TO BE REUSED.
- CONTRACTOR SHALL REPLACE ALL DATA CABLE WITH NEW CATEGORY 6A CABLE UNLESS OTHERWISE NOTED.
- CONTRACTOR SHALL TERMINATE COMMUNICATIONS CABLES WITH NEW CATEGORY MODULAR JACKS TO MATCH THE COMMUNICATION CABLE PERFORMANCE SPECIFICATIONS. NEW MODULAR JACKS SHALL BE OF THE SAME MANUFACTURER AS THE FACE PLATES, PATCH PANELS, AND PATCH CABLES.
- CONTRACTOR SHALL INSTALL NEW CATEGORY 6A CABLES AND CONNECTIVITY COMPONENTS THAT ARE OF THE SAME MANUFACTURER, INCLUDING CABLE, MODULAR JACKS, PATCH PANELS, FACEPLATES, AND PATCH CABLES.
- CONTRACTOR SHALL TEST ALL NEW AND EXISTING RE-TERMINATED CABLES IN ACCORDANCE WITH THE SPECIFICATION 27 08 00.

KEYED NOTES

- BACKBONE RISER CEILING PENETRATION
- FIREWALL PENETRATION
- 12 INCH X 4 INCH WIRE MESH CABLE TRAY
- 18 INCH X 4 INCH WIRE MESH CABLE TRAY
- 24 INCH X 4 INCH WIRE MESH CABLE TRAY
- SLEEVES IN FLOOR ABOVE.
- (2) 4" DIAMETER SLEEVES
- (2) 2" DIAMETER SLEEVES
- (2) 1-1/2" DIAMETER SLEEVES

 KEY PLAN

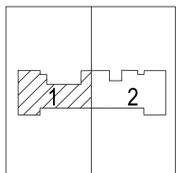

1 FLOOR PLAN - BLDG. 64 - SECOND FLOOR SOUTH
SCALE: 1/8" = 1'-0"

Revisions:	Date:

CONSULTANT

8718 Botts Lane
San Antonio, Texas 78217
www.hfscorporation.com

Phone: (210) 816-4784
Fax: (210) 881-6808
jbianco@hfscorporation.com

PROJECT MANAGEMENT

8718 Botts Lane
San Antonio, Texas 78217
www.hfscorporation.com

Phone: (210) 816-4784
Fax: (210) 881-6808
jbianco@hfscorporation.com

Raymond Martinez Jr.
BICSI ID # 143493
Expires 12-31-24
RCDD
04-MAY-22

Construction and Facilities Management

U.S. Department of Veterans Affairs

Drawing Title
BLDG. 64 - SECOND FLOOR - SOUTH TECHNOLOGY DATA OUTLET PLAN

Approved: Project Director

Phase
100% CONSTRUCTION DOCUMENTS

FULLY SPRINKLERED

Project Title
CINCINNATI VAMC EHRM INFRASTRUCTURE UPGRADES

Location
3200 VINE ST., CINCINNATI, OH

Issue Date
04-MAY-2022

Checked
NA

Drawn
RMjr

Project Number
539-21-701

Building Number
64

Drawing Number
TN-272-F.64.2S