




United States Department of Agriculture
Forest Service


SOUTHERN REGION OFFICE SPACE TOOLS & TEMPLATES

SOUTHERN REGION

ROOM TEMPLATES FOR SOUTHERN REGION

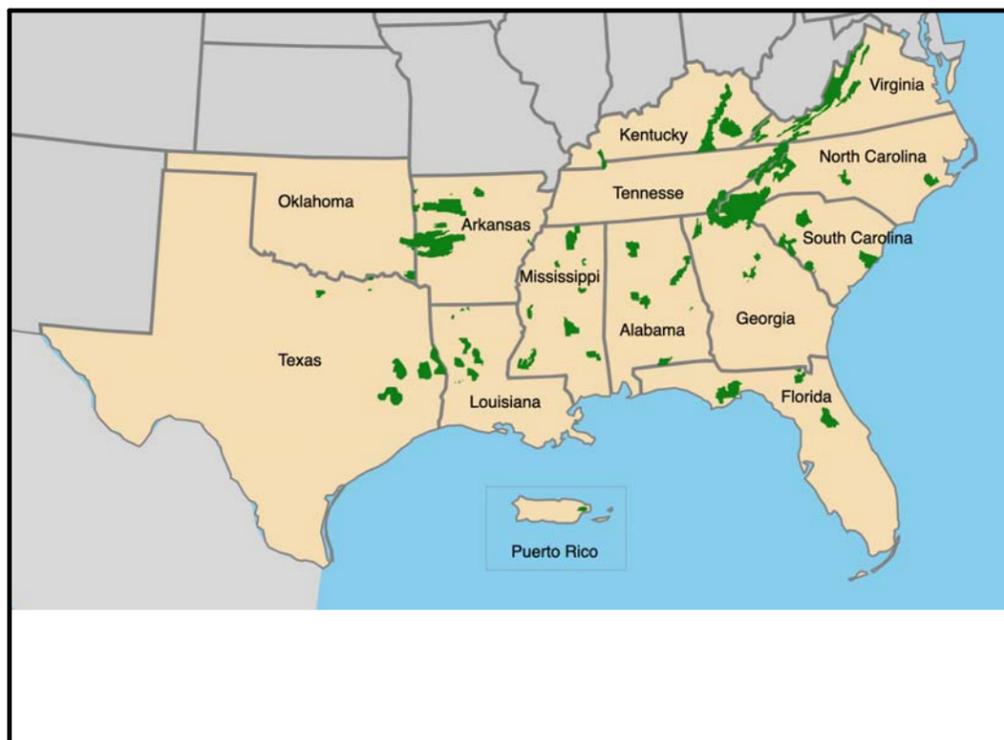

PROJECT LOCATION

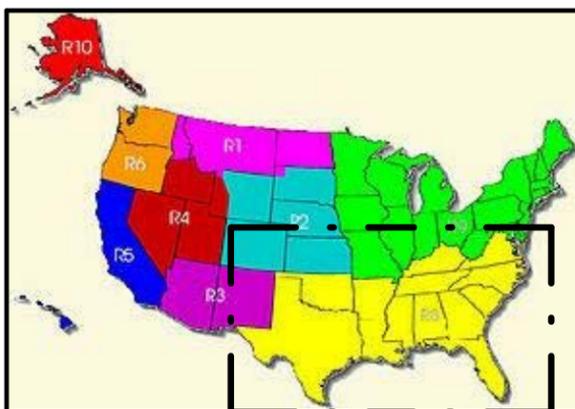

VICINITY MAP

TEMPLATE DIRECTIONS:

TEMPLATE TO BE USED IN THE SOUTHERN R-08 REGION OF THE US. TEMPLATE WAS CREATED TO SERVE AS A BASE FILE FOR ALL NEW LEASING OPERATIONS IN THIS REGION.

INDEX OF SHEETS		
#	SHEET TITLE	DATE
A000	COVER SHEET	05/24/2019
A001	GENERAL NOTES	05/24/2019
A002	SPACE SUMMARY	05/24/2019
A003	ADJACENCY DIAGRAM	05/24/2019
A101	GETAWAY C1	05/24/2019
A102	GETAWAY D1	05/24/2019
A103	SMALL MEETING A	05/24/2019
A104	SMALL MEETING B	05/24/2019
A105	MEDIUM MEETING A	05/24/2019
A106	MEDIUM MEETING B	05/24/2019
A107	MEDIUM MEETING B	05/24/2019
A108	MEDIUM MEETING B	05/24/2019
A109	LARGE MEETING A	05/24/2019
A110	LARGE MEETING A	05/24/2019
A111	LARGE MEETING B	05/24/2019
A112	LARGE MEETING B	05/24/2019
A113	X-LARGE MEETING	05/24/2019
A114	X-LARGE MEETING	05/24/2019
A115	X-LARGE MEETING	05/24/2019
A116	IT SHOP	05/24/2019
A117	CAFE	05/24/2019
A118	CAFE	05/24/2019
A119	BREAK	05/24/2019
A120	PANTRY	05/24/2019
A121	MUDROOM A	05/24/2019
A122	MUDROOM B	05/24/2019
A123	TELECOM	05/24/2019
A124	OFFICE SERVICES A	05/24/2019
A125	OFFICE SERVICES B	05/24/2019
A126	SHOWER	05/24/2019
A127	STANDARD LAB	05/24/2019
A128	LARGE LAB	05/24/2019
A129	WELLNESS	05/24/2019
A130	SMALL SECURE STORAGE	05/24/2019
A131	MEDIUM SECURE STORAGE	05/24/2019
A132	COMPACT STORAGE	05/24/2019
A133	VAULT STORAGE	05/24/2019
A134	RECEPTION	05/24/2019
A135	RECEPTION	05/24/2019
A136	MAIL ROOM	05/24/2019
A200	FURNITURE TYPES	05/24/2019
A201	FURNITURE TYPES	05/24/2019
A300	COLOR OPTION 1	05/24/2019
A301	COLOR OPTION 2	05/24/2019
A600	S. MEET. DETAILS	05/24/2019
A601	S. MEET. DETAILS	05/24/2019
A602	ONE-LINE DIAGRAM, DATA & VOICE	05/24/2019
A603	ONE-LINE DIAGRAM, CATV, CCTV	05/24/2019
A604	DETAILS	05/24/2019
A605	DETAILS	05/24/2019
A606	DETAILS	05/24/2019
A607	DETAILS	05/24/2019
A608	DETAILS	05/24/2019
LV201	OFFICE SPACES	05/24/2019
LV202	CAFE & SHARED WORK SPACES	05/24/2019
LV203	IT WORK SPACES & RECEPTION	05/24/2019
LV204	MEDIUM MEETING ROOMS	05/24/2019
LV205	LARGE MEETING ROOM 26	05/24/2019
LV206	LARGE MEETING ROOM 42	05/24/2019
LV207	LARGE MEETING ROOM 43	05/24/2019
LV208	LARGE MEETING ROOM B 25	05/24/2019
LV209	LARGE MEETING ROOM B2 31	05/24/2019
LV210	LARGE MEETING ROOM B3 30	05/24/2019
LV211	LARGE MEETING ROOM ELEVATION	05/24/2019
LV212	X-LARGE MEETING ROOM 52 PLAN	05/24/2019
LV213	X-LARGE MEETING ROOM 52 RCP	05/24/2019
LV214	X-LARGE MEETING ROOM ELEVATION	05/24/2019
LV215	X-LARGE MEETING ROOM 61 PLAN	05/24/2019
LV216	X-LARGE MEETING ROOM 61 RCP	05/24/2019
LV301	TELECOM ROOM	05/24/2019
LV401	ONE-LINE DIAGRAM M. CONF. ROOM	05/24/2019
LV402	ONE-LINE DIAGRAMS. CONF. ROOM	05/24/2019
LV403	ONE-LINE DIAGRAM L. A CONF. ROOM	05/24/2019
LV404	ONE-LINE DIAGRAM L. A CONF. ROOM	05/24/2019
LV405	ONE-LINE DIAGRAM L. B CONF. ROOM	05/24/2019
LV406	ONE-LINE DIAGRAM L. B CONF. ROOM	05/24/2019
LV407	ONE-LINE DIAGRAM XL 52 CONF. ROOM	05/24/2019
LV408	ONE-LINE DIAGRAMXL 52 CONF. ROOM	05/24/2019
LV409	ONE-LINE DIAGRAMXL 52 CONF. ROOM	05/24/2019
LV410	ONE-LINE DIAGRAM XL 61 CONF. ROOM	05/24/2019
LV411	ONE-LINE DIAGRAMXL 61 CONF. ROOM	05/24/2019
LV412	ONE-LINE DIAGRAM XL 61 CONF. ROOM	05/24/2019
LV501	DETAILS - AV CONTROL PANELS	05/24/2019
LV502	DETAILS - AV EQUIPMENT RACKS	05/24/2019



United States Department of Agriculture
Forest Service

R-08
Southern Region

PROJECT NAME:

*R-08 SOUTHERN
REGION OFFICE
SPACE TOOLS &
TEMPLATES*

*UNITED STATES
DEPARTMENT OF
AGRICULTURE
FOREST SERVICE*

SOUTHERN REGION (R8)
1720 PEACHTREE ROAD, NW
ATLANTA, GA. 30309

DRAWING TITLE

COVER SHEET

DATE

05/24/19

ARCHIVE NUMBER:

DESIGNER:

US
FOREST
SERVICE/TSW

DWG SHEET NO:

A000

DRAWN BY:

US
FOREST
SERVICE/TSW

CHECKED BY:

US
FOREST
SERVICE

SHEET XXX OF XXX

PROJECT NO:

12432P18D0002

SECURITY & TELECOM DEVICE LEGEND:

- ▽ Data outlet, mount at 18" AFF. Coordinate with power receptacle and architectural elevations for exact mounting height. Provide two (2) category 6/23 awg/utp cables from station outlet to closest telecom room and terminate on category 6 patch panel. Support cables in ceiling space with j-hooks on 4'-0" to 5'-0" centers.
 - Note: when outlet is provided with numerical subscript, provide noted quantity of data circuits.
 - Note: when outlet is provided with "c" subscript install outlet above counter at 42" AFF.
- ^w▽ Wall Phone. Single data with wall phone plate. Provide one(1) category 6/23 awg/utp cable from station outlet to closest telecom room and terminate on category 6 patch panel. Support cables in ceiling with j-hooks on 4'-0" to 5'-0" centers.
- ^{TV}▽ Data/television outlet, coordinate mounting height with architectural elevations floor plan drawings. Provide two(2) category 6/23 awg/utp cables from station outlet to closest telecom room and terminate on category 6 patch panel. Provide one RG-6 quad shield coaxial cable from station outlet to local telecom room and terminate on CATV wall field, for cabling distances beyond 200', provide quad shield RG-11U coaxial cable. Support cables in ceiling spaces with j-hooks on 4'-0" to 5'-0" centers.
- ⊙ Ceiling mount data outlet for wireless access point. Provide two (2) category 6A/23 awg/utp cables from ceiling outlet to closest telecom room and terminate on category 6a patch panel. Mount outlet in dual port surface mount box attached to structural ceiling. Cables to be designated for category 6a data. Provide 20' service loop in ceiling supported by j-hooks.
- CR Multi-technology card reader mounted at 48" AFF. See plan details for requirements.
- E Electric door hardware and door position switch.
- ☑ Wall/floor data outlet termination point. Provide two(2) category 6/23 awg/utp cables from station outlet to closest telecom room and terminate on category 6 patch panel. Support cables in ceiling space with j-hooks on 4'-0" to 5'-0" centers.
 - Note: when outlet is provided with numerical subscript provide noted quantity of data circuits.

ELECTRICAL CONDUIT ROUGH-IN LEGEND:

- ▽ Data outlet, reference architectural elevations for mounting heights, provide wall mount 4" square backbox with single gang tile ring. Provide one (1) - 1" EMT conduit from box to accessible ceiling.
- ^w▽ Wall Phone outlet. Provide wall mount 4" square backbox with single gang tile ring @ 48" AFF. Provide one(1) - 3/4" EMT conduit from box to ceiling space.
- ^{TV}▽ Television outlet, reference architectural elevations for mounting heights, provide wall mount 4" square backbox with single gang tile ring. Provide one (1) - 1" EMT conduit from box to accessible ceiling.
- ⊙ Ceiling mount data outlet. Provide two j-hooks supported from structure spaced 12" apart to support 20' service loop. Mount above finished ceiling. Coordinate exact location with accessible ceiling spaces.
- CR Multi-technology card reader. Provide wall mount 4" square backbox with single gang tile ring at 42" AFF. Provide (1) - 1"EMT conduit from box to security junction box. See installation detail.
- E Electric door hardware and door position switch. Provide two (2) - 1" EMT conduits routed from door frame security junction box. See installation detail.

AUDIO VISUAL DEVICE LEGEND:

- ▬ Flat panel display mounting system with integral speakers (if required, see floor plans). See mounted heights at xx" AFF to center of screen - size display as indicated on floor plans. Coordinate exact location as indicated on floor plans. Coordinate mounting with architectural and furniture locations. See floor plans for power, wall blocking, and interface requirements.
- ⊙ Audio visual ceiling speaker provided and installed by audio/visual contractor. Speaker to be white in color, confirm with local architect.
 - #Subscript indicates model type. Reference floor plan & details for model type.
- AV FBI Audio Visual interface connection floor box provided and installed by electrical contractor. Floor box to be mounted under conference room table/lectern as shown on plans. AV conduits to terminate into low voltage side of floor box.
 - Provide two(2) category 6/23 awg/utp cables from floor box location to closest telecom room and terminate on category 6 patch panel.
 - Provide interconnect plate for audio visual and network connections.
 - Provide with cover, coordinate cover selections with architect/owner.
- AV CUE# AV cable enclosure. Reference floor plans for location.
 - #Subscript indicates model type. Reference floor plan & details for model type.
 - Provide two data circuits to enclosure location.
- AV CTL# Wall or table mounted control panel. Reference floor plans for location.
 - #Subscript indicates model type. Reference floor plan & details for model type.
- AV INP# Wall mounted input interface connection plate. Reference floor plans for location.
 - #Subscript indicates model type. Reference floor plan & details for model type.
- AV ANT Wireless microphone antenna. Reference floor plan & ceiling plans for requirements. Install below ceiling tile using tile bridge in grid or similar mounting device.
- AV CAM# Pan/Tilt/Zoom or fixed conference room video conferencing camera. Reference floor plans for location.
- ⊙ Ceiling mounted microphone.

INSTRUCTIONS FOR USING THE TEMPLATE:

BACKGROUND:

1. The Forest Service, Southern Region has office leases requiring the start of a long-term renewal or a new lease acquisition. Several action will result in the significant space reductions in new space, while others will only need minor alterations in existing space.
2. To conform to Forest Service Space Policy and Competition Requirements, all new leases need a complete set of requirements to initiate the acquisition process and to substantiate any Exception Request should the cost to fully conform not be cost effective.
3. A lease can be considered a special type of design-build contract. If given a detailed Requirements Package, Forest Service Leasing Officers can handle the majority of the day-to-day work in acquiring a new lease.
4. Standardizing the requirements will reduce the burden on staff and ease adoption of the new standards.

TEMPLATES:

1. The templates are a set of Office Space Standards usable for planning and design work that incorporates lessons learned and the technical knowledge of the US Forest Service Staff.
2. The intent of the templates are to provide consistency across the Region, speed the acquisition process, and may be updated regularly to incorporate improvements.
3. The templates shall be incorporated by the local architect or engineer for each site specific Service, and District Office

GOVERNMENT SPACE REFERENCES:

POLICY DOCUMENTS

1. USDA SPACE POLICY- 08/02/2002 AND AMENDED 05/17/2004
2. FOREST SERVICE SPACE POLICY DATED 10/29/2018

LEASE ACQUISITION STANDARD DOCUMENTS AND REFERENCES

1. GSA LEASING DESK GUIDE LAST AMENDED - 05/05/2014
2. GAS LEASE REQUIREMENTS QUESTIONNAIRE
3. SF-81 REQUEST FOR SPACE- REVISION 2-89

TECHNICAL WORKING DOCUMENTS AND STANDARDS

1. FOREST SERVICE SPACE ENGAGEMENT DIAGNOSTIC REPORTS- DRAFT 07/27/2015
2. FOREST SERVICE SPACE DESIGN GUIDE- UPDATED 05/19/2015
3. USDA SPACE DESIGN GUIDE- UPDATED 05/19/2015

AV ELECTRICAL CONDUIT ROUGH-IN LEGEND:

- ▬ Flat panel display mounting system with speakers (if required) see floor plans for power and interface requirements. Provide a power receptable at each display location.
- ⊙ Audio visual ceiling speaker. Audio visual contractor to provide manufacturer's back box and mounting accessories for all locations as shown on plans. Coordinate mounting location with mechanical and lighting. Install in ceiling grid.
 - Electrical contractor to provide and install 3/4" conduit between speaker boxes in hard ceiling spaces and/or locations that are inaccessible. Route conduit to accessible ceiling spaces via pass-thru sleeves.
- AV FBI Audio visual interface connection floor box provided by electrical contractor. Floor box to be mounted under conference room table/lectern as shown on plans. AV conduits to terminate into low voltage side of floor box.
 - Provide two(2) data circuits to floor box location.
 - Provide interconnect plate for audio visual and network connections.
 - Provide with cover. Coordinate cover selection with architect/owner.
- AV CTL# Wall mounted control panel. Reference floor plans for location.
 - AV CTL 1: Provide and install 3-gang back box mounted at 48" AFF with conduits as shown on plans.
 - AV CTL 2: Provide and install 2-gang back box mounted at 48" AFF with conduits as shown on plans.
 - AV CTL 3: Provide and install 2-gang back box mounted at 48" AFF with conduits as shown on plans
- AV INP# Wall mounted interface connection plate. Reference floor plans for location.
 - Provide and install back box. See floor plans for mounting height, location, & size. Provide and install conduits as shown on plans.
 - INP1 - 4-gang back box
 - INP2 - 2-gang back box
- AV CAM1 Wall or ceiling mounted pan/tilt/zoom video camera. Reference floor plans for location.
 - Provide and install one(1) two-gang back box. See floor plans for mounting height location. Provide and install conduits as shown on plans.
- AV CAM2 Wall or ceiling mounted fixed video camera. Reference floor plans for location.
 - Provide and install one(1) two-gang back box and all conduits as shown on plans. See floor plans for mounting height location.



United States Department of Agriculture
Forest Service

R-08
Southern Region

PROJECT NAME:

R-08 SOUTHERN REGION OFFICE SPACE TOOLS & TEMPLATES

UNITED STATES DEPARTMENT OF AGRICULTURE FOREST SERVICE

SOUTHERN REGION (R8)
1720 PEACHTREE ROAD, NW
ATLANTA, GA. 30309

DRAWING TITLE

INSTRUCTIONS

DATE
05/24/19

ARCHIVE NUMBER:

DESIGNER:
Designer

DWG SHEET NO:


DRAWN BY:
Author

A001

CHECKED BY:
Checker

PROJECT NO:
12432P18D0002

SHEET XXX OF XXX

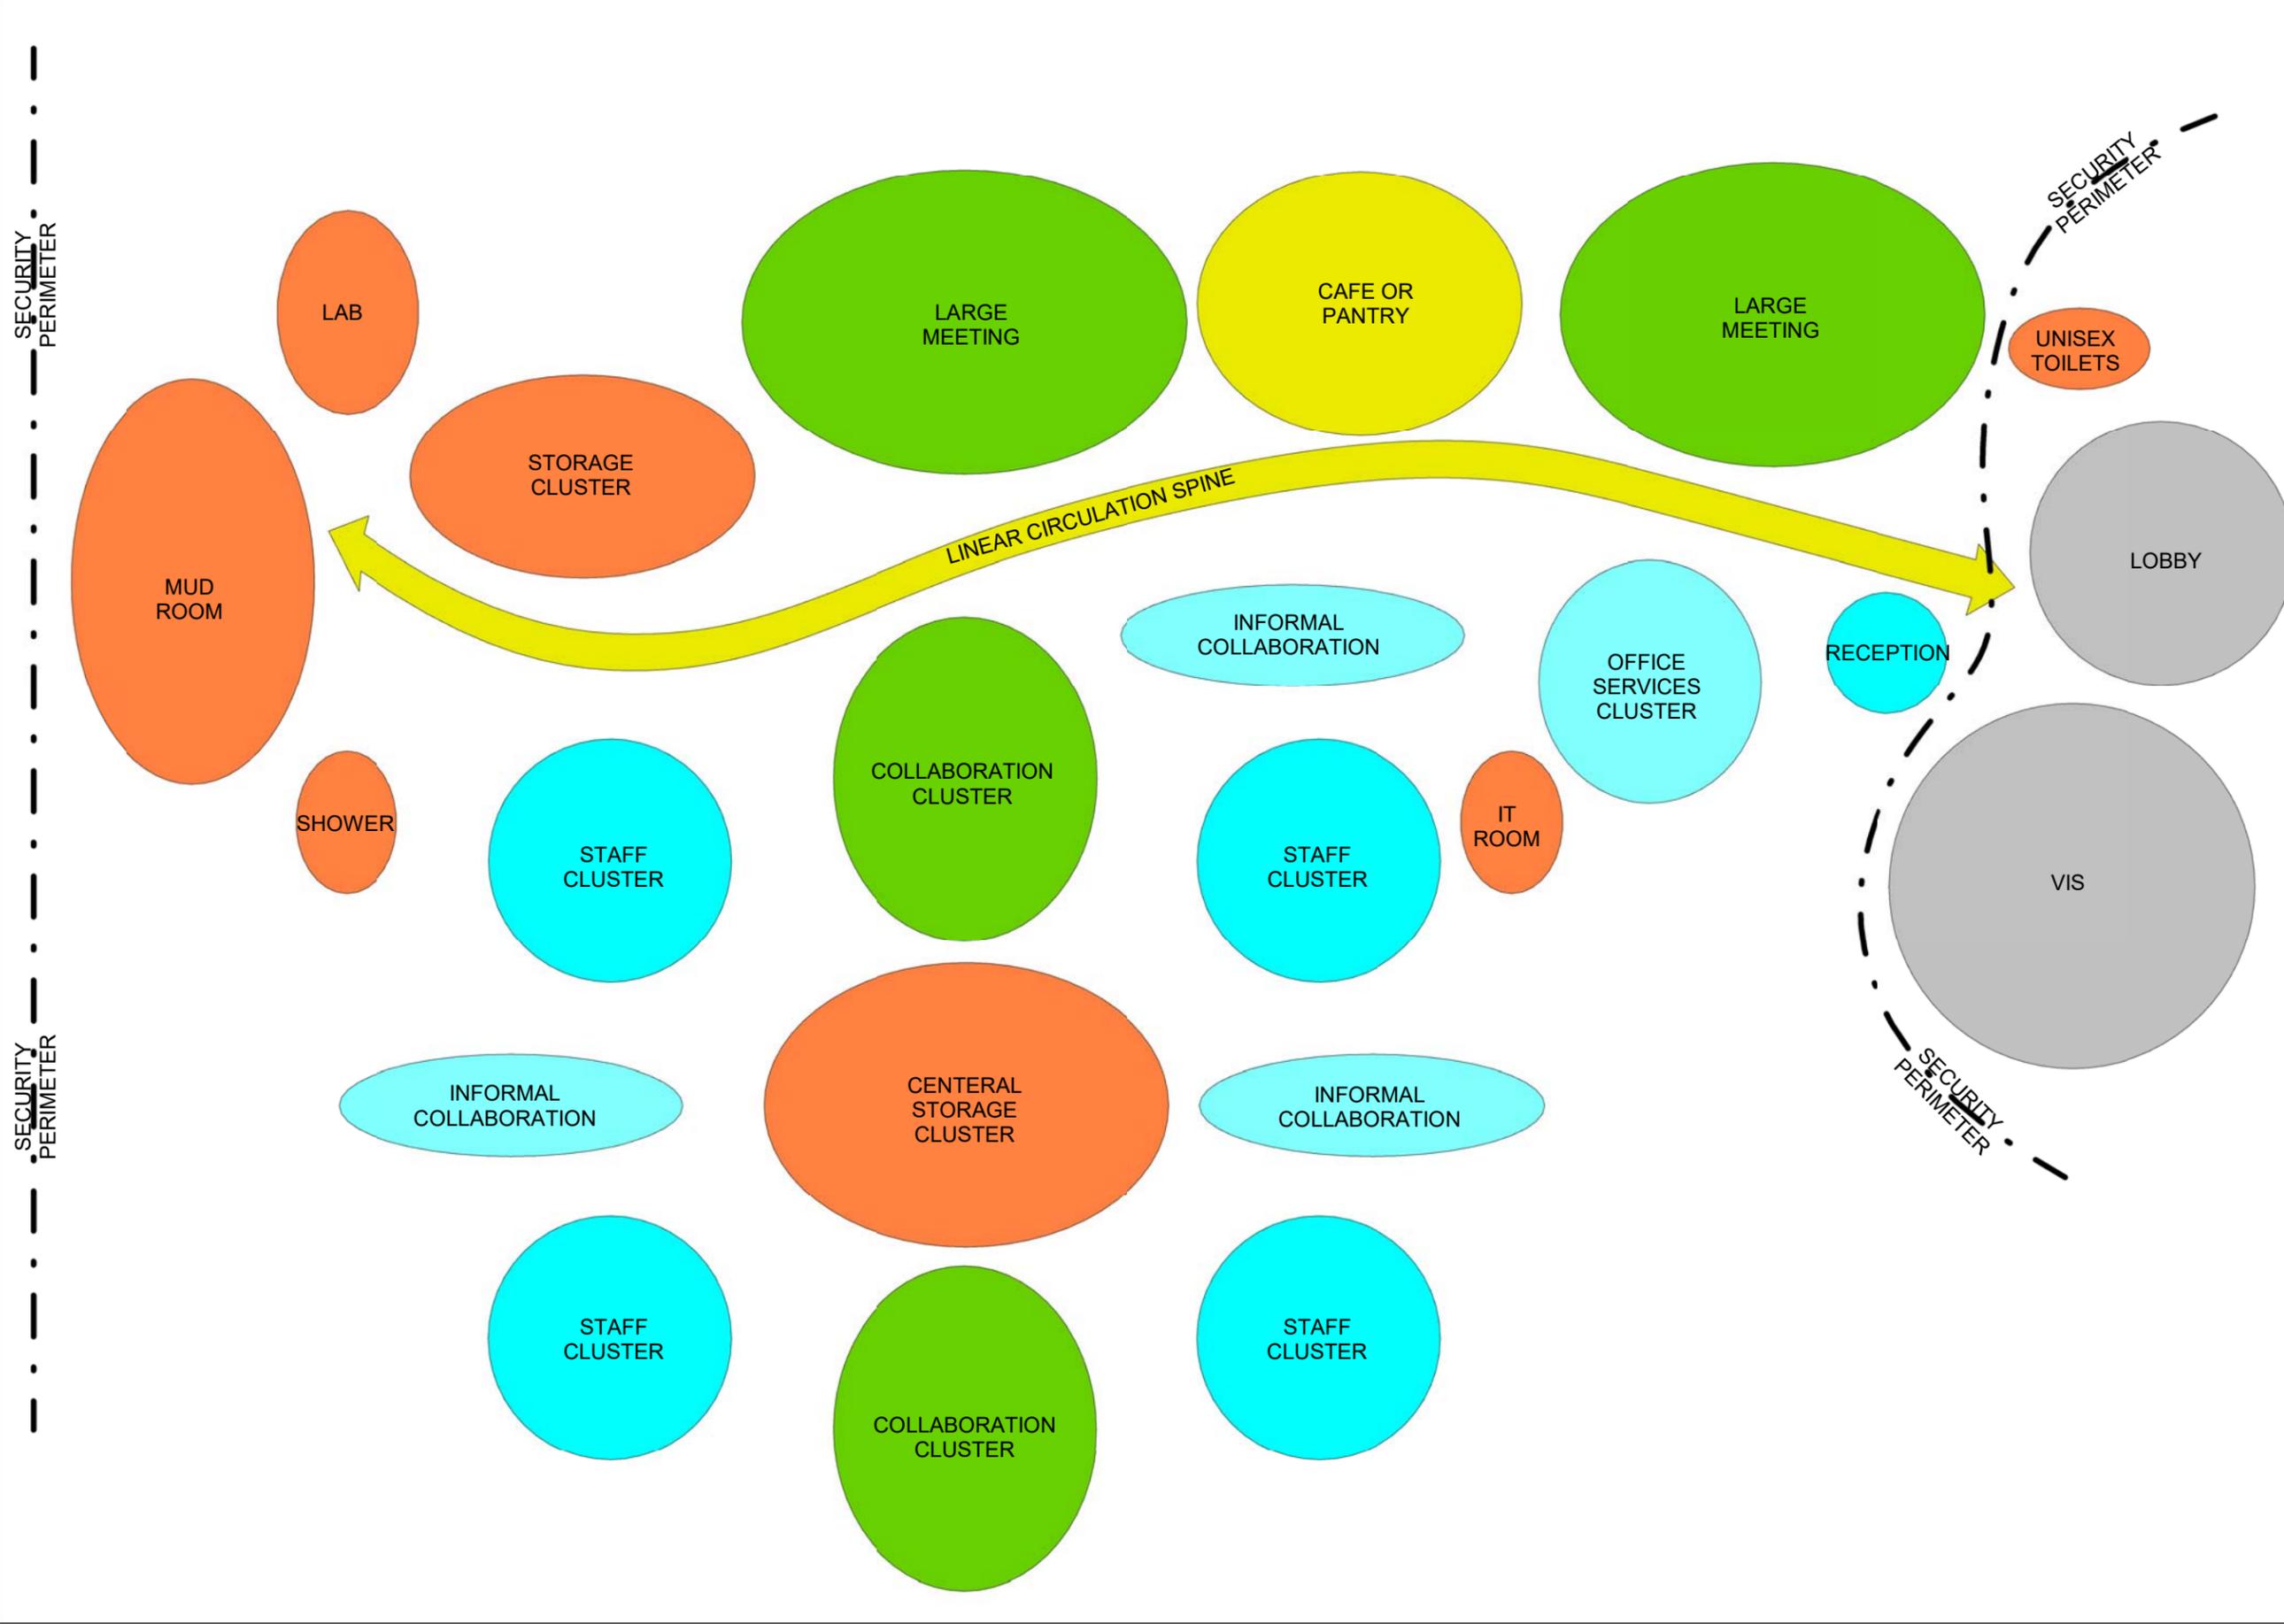

United States Department of Agriculture
Forest Service

R-08

Southern Region

PROJECT NAME:
R-08 SOUTHERN REGION OFFICE SPACE TOOLS & TEMPLATES

UNITED STATES DEPARTMENT OF AGRICULTURE
FOREST SERVICE

SOUTHERN REGION (R8)
1720 PEACHTREE ROAD, NW
ATLANTA, GA. 30309

DRAWING TITLE:
ADJACENCY DIAGRAM


DATE:
05/24/19

ARCHIVE NUMBER:


DESIGNER: Designer	DWG SHEET NO: A002
DRAWN BY: Author	

CHECKED BY: Checker	
------------------------	--


PROJECT NO: 12432P18D0002	SHEET XXX OF XXX
------------------------------	------------------

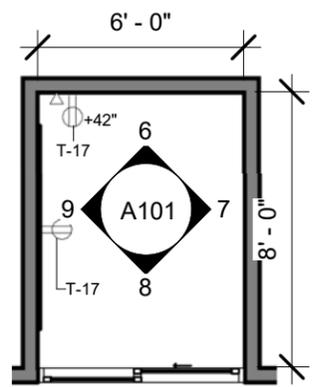


1 GETAWAY C1
3/16" = 1'-0"

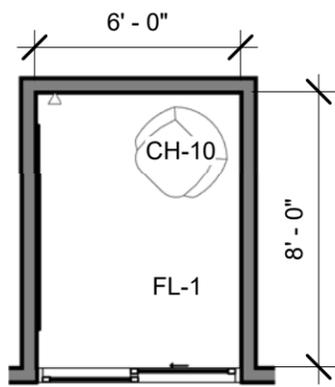

2 GETAWAY C1 FURNITURE OPT 1
3/16" = 1'-0"

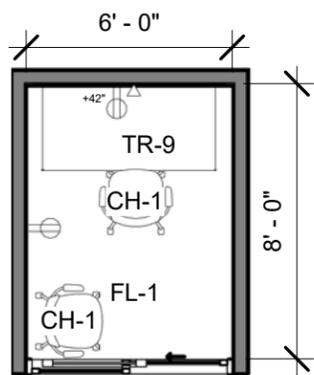


3 GETAWAY C1 FURNITURE OPT 2
3/16" = 1'-0"

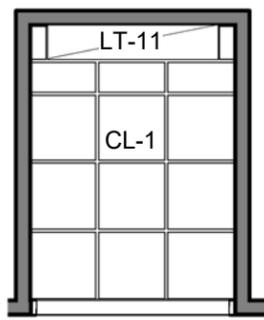


4 GETAWAY C1 RCP
3/16" = 1'-0"




5 GETAWAY C1

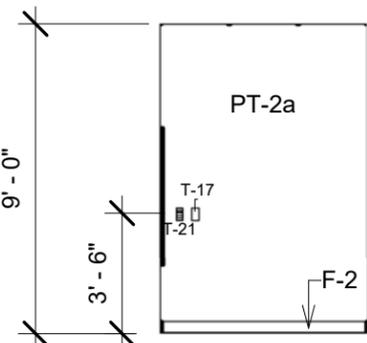


6 GET. C1 ELEV. 1
3/16" = 1'-0"

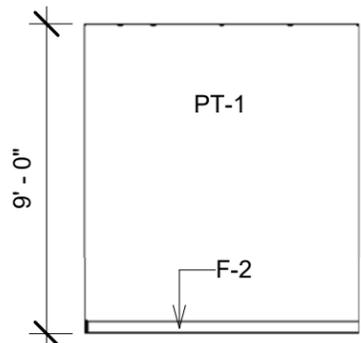

7 GET. C1 ELEV. 2
3/16" = 1'-0"

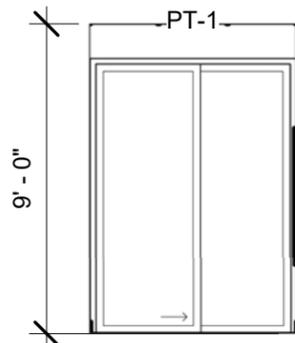

8 GET. C1 ELEV. 3
3/16" = 1'-0"

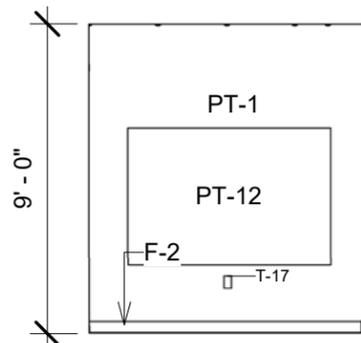

9 GET. C1 ELEV. 4
3/16" = 1'-0"

KEYNOTE LEGEND

CH-1	STACKABLE HIGHBACK TASK CHAIR
CH-10	LARGE LOUNGE CHAIR
CL-1	2X2 ACCOUSTIC CEILING TILE, ASTM E1264, FORM 2, PATTERN E, FIRE CLASS A. DUCTED RETURNS ONLY.
F-2	VINYL WALL BASE, SEE FLOOR FINISH FOR COLOR
FL-1	MODULAR CARPET TILE
LT-11	5'-0" RECESSED LED STRIP LIGHTING
PT-1	PAINT #1, PRIMARY WALL COLOR SW6539
PT-2a	PAINT #2a, SECONDARY WALL COLOR SW6437, TO PAIR W/ PAINT #3a
PT-12	TACKABLE ACCOUSTICAL WALL PANEL
T-17	120V WALL MOUNTED DUPLEX POWER OUTLET-WHITE
T-21	WALL MOUNTED DATA OUTLET
TR-9	30"Dx60W TABLE



United States Department of Agriculture
Forest Service

R-08
Southern Region

PROJECT NAME:

R-08 SOUTHERN REGION OFFICE SPACE TOOLS & TEMPLATES

UNITED STATES DEPARTMENT OF AGRICULTURE
FOREST SERVICE

SOUTHERN REGION (R8)
1720 PEACHTREE ROAD, NW
ATLANTA, GA. 30309

DRAWING TITLE

GETAWAY C1

DATE
05/24/19

ARCHIVE NUMBER:

DESIGNER:
Designer

DWG SHEET NO:


A101

DRAWN BY:
Author


CHECKED BY:
Checker

PROJECT NO:
12432P18D0002


SHEET XXX OF XXX

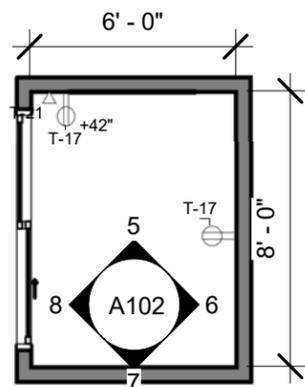


1 GETAWAY D1
3/16" = 1'-0"

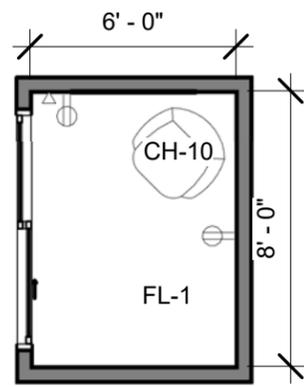


2 GETAWAY D1 FURNITURE OPT 1
3/16" = 1'-0"

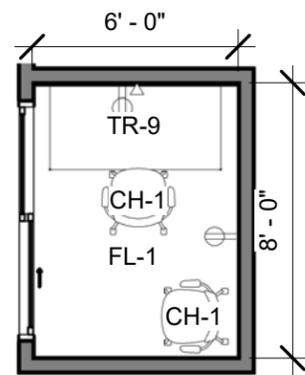


3 GETAWAY D1 FURNITURE OPT 2
3/16" = 1'-0"

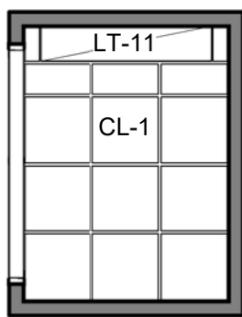


4 GETAWAY D1 RCP
3/16" = 1'-0"

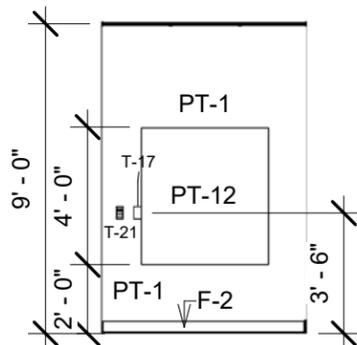


5 GET. D1 ELEV. 1
3/16" = 1'-0"

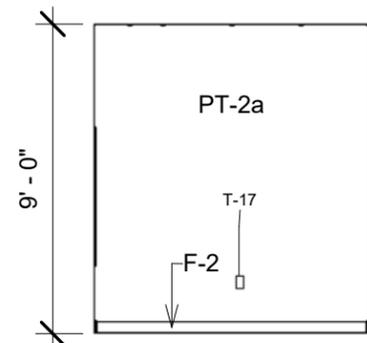

6 GET. D1 ELEV. 2
3/16" = 1'-0"

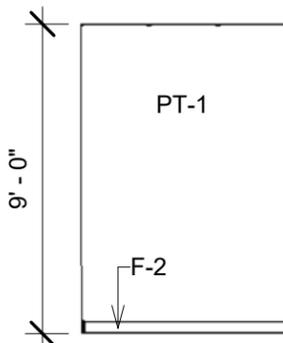

7 GET. D1 ELEV. 3
3/16" = 1'-0"

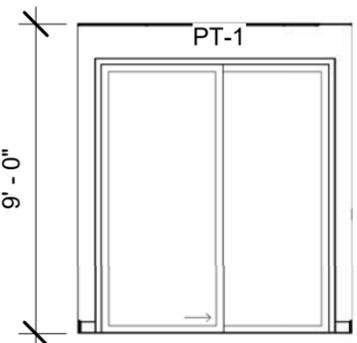

8 GET. D1 ELEV. 4
3/16" = 1'-0"



9 GETAWAY D1

KEYNOTE LEGEND	
CH-1	STACKABLE HIGHBACK TASK CHAIR
CH-10	LARGE LOUNGE CHAIR
CL-1	2X2 ACCOUSTIC CEILING TILE, ASTM E1264, FORM 2, PATTERN E, FIRE CLASS A. DUCTED RETURNS ONLY.
F-2	VINYL WALL BASE, SEE FLOOR FINISH FOR COLOR
FL-1	MODULAR CARPET TILE
LT-11	5'-0" RECESSED LED STRIP LIGHTING
PT-1	PAINT #1, PRIMARY WALL COLOR SW6539
PT-2a	PAINT #2a, SECONDARY WALL COLOR SW6437, TO PAIR W/ PAINT #3a
PT-12	TACKABLE ACCOUSTICAL WALL PANEL
T-17	120V WALL MOUNTED DUPLEX POWER OUTLET-WHITE
T-21	WALL MOUNTED DATA OUTLET
TR-9	30"Dx60W TABLE



R-08

Southern Region

PROJECT NAME:
R-08 SOUTHERN REGION OFFICE SPACE TOOLS & TEMPLATES

UNITED STATES DEPARTMENT OF AGRICULTURE FOREST SERVICE

SOUTHERN REGION (R8)
1720 PEACHTREE ROAD, NW
ATLANTA, GA. 30309

DRAWING TITLE
GETAWAY D1

DATE 05/24/19	
ARCHIVE NUMBER:	
DESIGNER: Designer	DWG SHEET NO: A102
DRAWN BY: Author	
CHECKED BY: Checker	
PROJECT NO: 12432P18D0002	SHEET XXX OF XXX



United States Department of Agriculture
Forest Service

R-08

Southern Region

PROJECT NAME:

R-08 SOUTHERN
REGION OFFICE
SPACE TOOLS &
TEMPLATES

UNITED STATES
DEPARTMENT OF
AGRICULTURE
FOREST SERVICE

SOUTHERN REGION (R8)
1720 PEACHTREE ROAD, NW
ATLANTA, GA. 30309

DRAWING TITLE

SMALL MEETING
A

DATE

05/24/19

ARCHIVE NUMBER:

DESIGNER:

Designer

DWG SHEET NO.:

A103

DRAWN BY:

Author

CHECKED BY:

Checker


PROJECT NO.:

12432P18D0002


SHEET XXX OF XXX




3 SMALL MEETING A

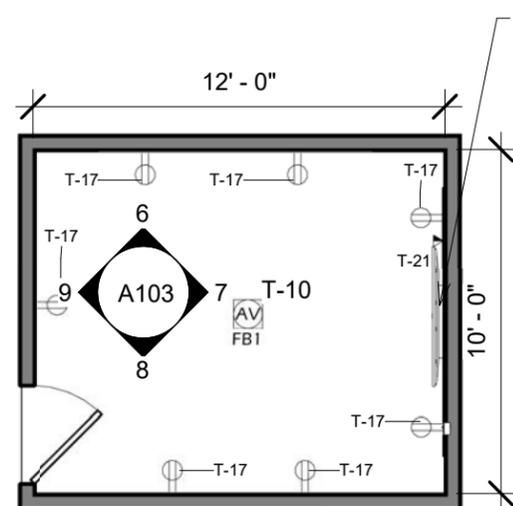


1 SMALL MEETING A
3/16" = 1'-0"

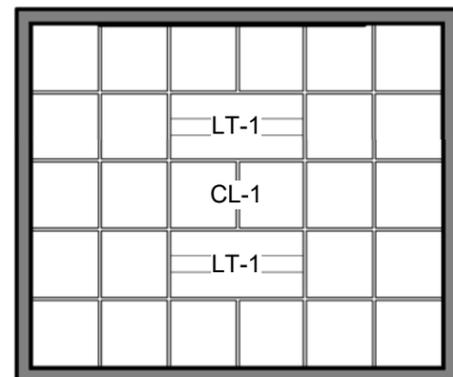


2 SMALL MEETING RCP
3/16" = 1'-0"

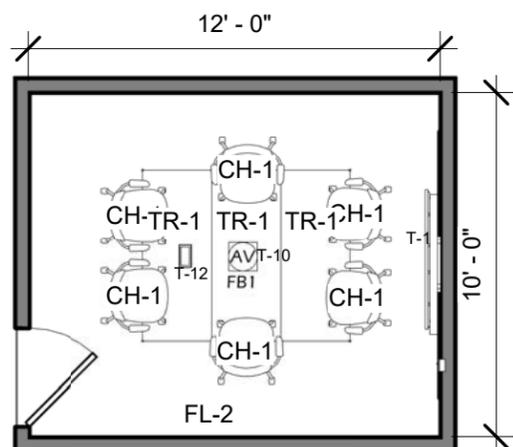


4 SMALL MEETING FURNITURE OPT 3
3/16" = 1'-0"

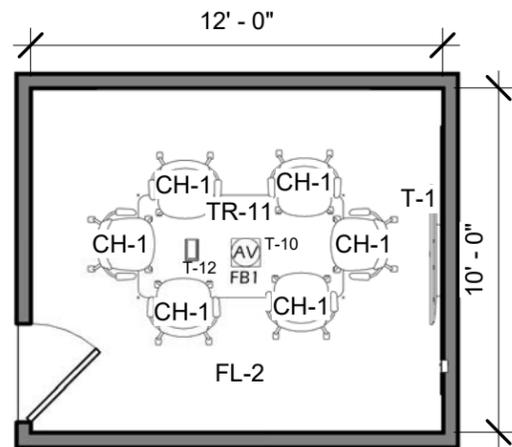


5 SMALL MEETING FURNITURE OPT 1
3/16" = 1'-0"

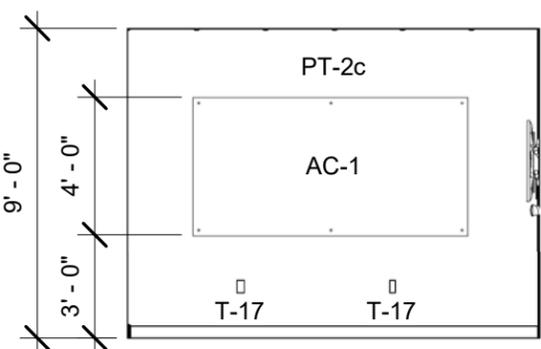


6 S. MEET. A ELEV. 1
3/16" = 1'-0"

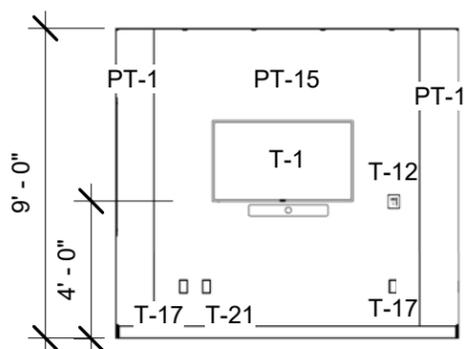

7 S. MEET. A ELEV. 2
3/16" = 1'-0"

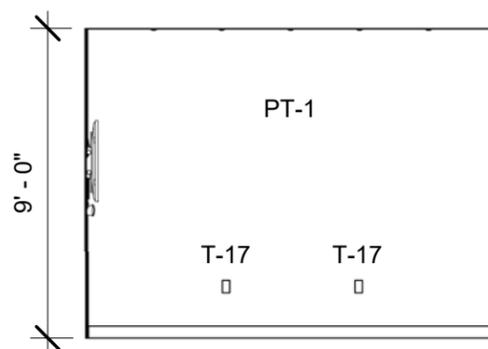


8 S. MEET. A ELEV. 3
3/16" = 1'-0"

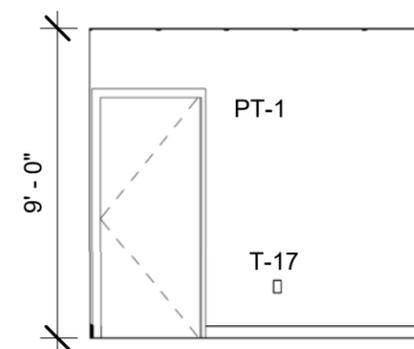


9 S. MEET. A ELEV. 4
3/16" = 1'-0"

OUTLET & TV DATA
HOOK UP BEHIND
SCREEN.

KEYNOTE LEGEND	
AC-1	BACK PAINTED WRITABLE GLASS MARKERBOARD- CLARIDGE GLASS MARKERBOARD BRILLIANT WHITE OR EQUAL
CH-1	STACKABLE HIGHBACK TASK CHAIR
CL-1	2X2 ACCOUSTIC CEILING TILE, ASTM E1264, FORM 2, PATTERN E, FIRE CLASS A. DUCTED RETURNS ONLY.
FL-2	MODULAR CARPET TILE - ALT 1
LT-1	2'x4' RECESSED TROFFER
PT-1	PAINT #1, PRIMARY WALL COLOR SW6539
PT-2c	PAINT #2c, SECONDARY WALL COLOR SW6527, TO PAIR W/ PAINT #3c
PT-15	TACKABLE ACCOUSTICAL WALL PANEL W/ PRINTED US FOREST IMAGE
T-1	FLAT PANEL DISPLAY MONITOR W/ SPEAKERS AS REQUIRED
T-10	FLOOR MOUNTED AUDIO VISUAL INTERFACE CONNECTION
T-12	WALL OR TABLE MOUNTED CONTROL PANEL
T-17	120V WALL MOUNTED DUPLEX POWER OUTLET-WHITE
T-21	WALL MOUNTED DATA OUTLET
TR-1	24"Wx60"L TRAINING TABLE
TR-11	36"Dx72"W TABLE

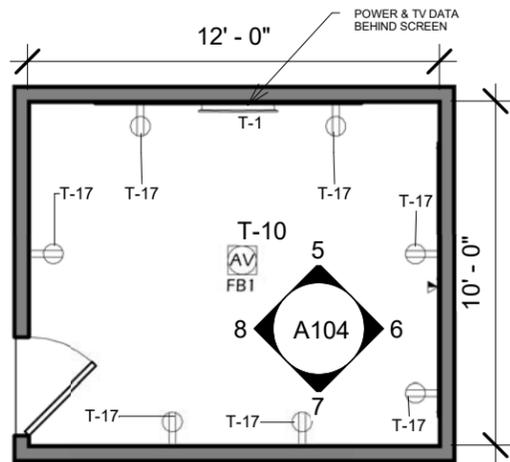


1 SMALL MEETING B
3/16" = 1'-0"

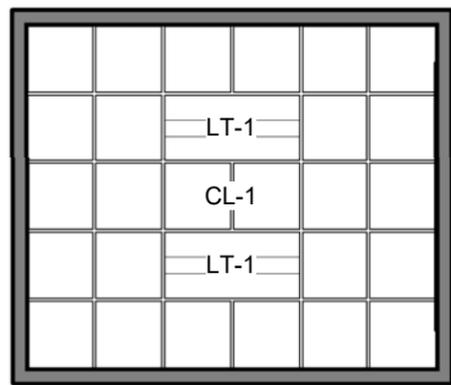


2 SMALL MEETING B RCP
3/16" = 1'-0"




3 SMALL MEETING B

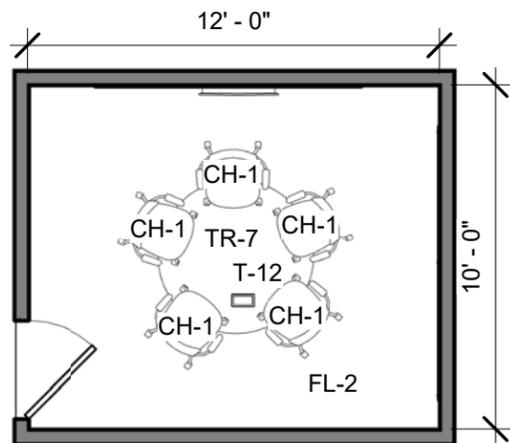


4 SMALL MEETING B FURNITURE
3/16" = 1'-0"

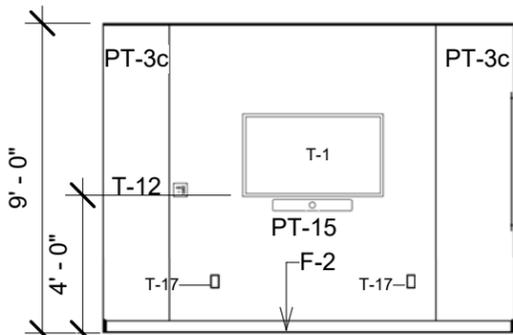


5 S. MEET. B ELEV. 1
3/16" = 1'-0"

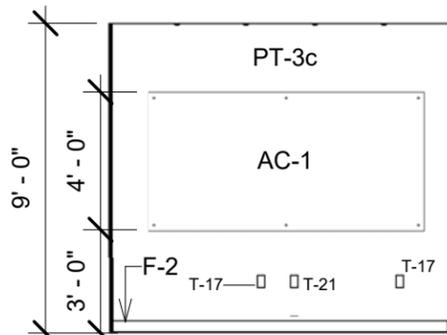

6 S. MEET. B ELEV. 2
3/16" = 1'-0"

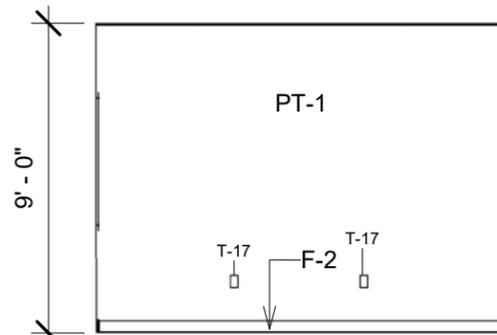

7 S. MEET. B ELEV. 3
3/16" = 1'-0"

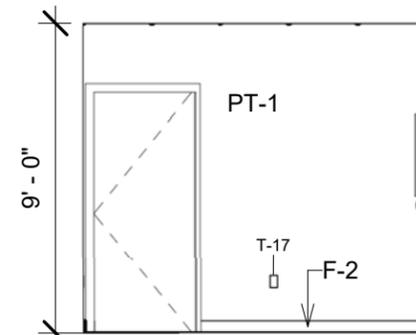

8 S. MEET. B ELEV. 4
3/16" = 1'-0"

KEYNOTE LEGEND	
AC-1	BACK PAINTED WRITABLE GLASS MARKERBOARD- CLARIDGE GLASS MARKERBOARD BRILLIANT WHITE OR EQUAL
CH-1	STACKABLE HIGHBACK TASK CHAIR
CL-1	2X2 ACCOUSTIC CEILING TILE, ASTM E1264, FORM 2, PATTERN E, FIRE CLASS A. DUCTED RETURNS ONLY.
F-2	VINYL WALL BASE, SEE FLOOR FINISH FOR COLOR
FL-2	MODULAR CARPET TILE - ALT 1
LT-1	2'x4' RECESSED TROFFER
PT-1	PAINT #1, PRIMARY WALL COLOR SW6539
PT-3c	PAINT #3c, SECONDARY WALL COLOR SW6529, TO PAIR W/ PAINT #2c
PT-15	TACKABLE ACCOUSTICAL WALL PANEL W/ PRINTED US FOREST IMAGE
T-1	FLAT PANEL DISPLAY MONITOR W/ SPEAKERS AS REQUIRED
T-10	FLOOR MOUNTED AUDIO VISUAL INTERFACE CONNECTION
T-12	WALL OR TABLE MOUNTED CONTROL PANEL
T-17	120V WALL MOUNTED DUPLEX POWER OUTLET-WHITE
T-21	WALL MOUNTED DATA OUTLET
TR-7	54" DIAMETER ROUND TABLE



United States Department of Agriculture
Forest Service

R-08

Southern Region

PROJECT NAME:
*R-08 SOUTHERN
REGION OFFICE
SPACE TOOLS &
TEMPLATES*

*UNITED STATES
DEPARTMENT OF
AGRICULTURE
FOREST SERVICE*

SOUTHERN REGION (R8)
1720 PEACHTREE ROAD, NW
ATLANTA, GA. 30309

DRAWING TITLE

*SMALL MEETING
B*

DATE
05/24/19

ARCHIVE NUMBER:

DESIGNER:
Designer

DWG SHEET NO:
A104

DRAWN BY:
Author

CHECKED BY:
Checker

PROJECT NO:
12432P18D0002

SHEET XXX OF XXX



KEYNOTE LEGEND	
CL-1	2X2 ACCOUSTIC CEILING TILE, ASTM E1264, FORM 2, PATTERN E, FIRE CLASS A, DUCTED RETURNS ONLY.
LT-1	2'x4' RECESSED TROFFER
T-8	CEILING MOUNTED MICROPHONE
T-10	FLOOR MOUNTED AUDIO VISUAL INTERFACE CONNECTION
T-17	120V WALL MOUNTED DUPLEX POWER OUTLET-WHITE
T-21	WALL MOUNTED DATA OUTLET

United States Department of Agriculture
Forest Service

R-08


Southern Region

PROJECT NAME:
R-08 SOUTHERN REGION OFFICE SPACE TOOLS & TEMPLATES


UNITED STATES DEPARTMENT OF AGRICULTURE
FOREST SERVICE

SOUTHERN REGION (R8)
1720 PEACHTREE ROAD, NW
ATLANTA, GA. 30309

1 MEDIUM MEETING A


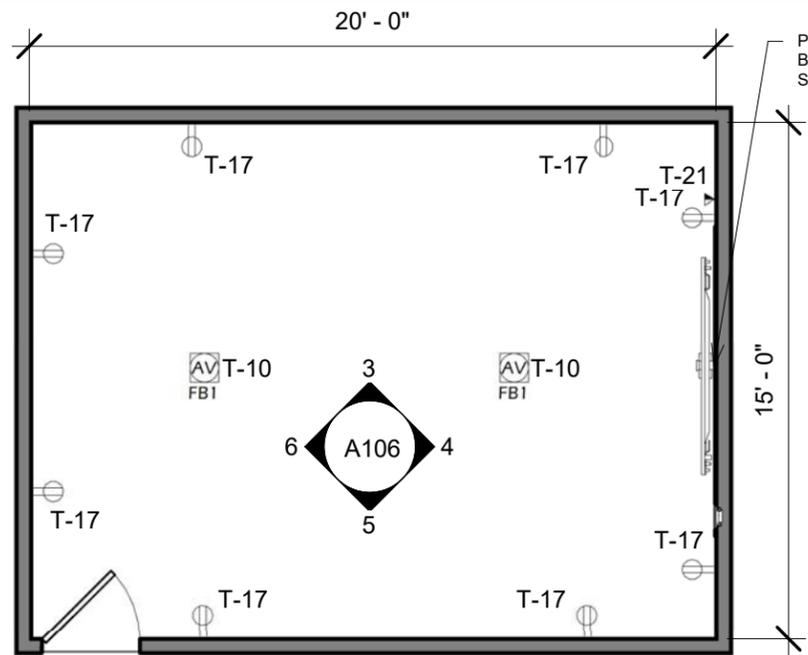


2 MEDIUM MEETING A
3/16" = 1'-0"

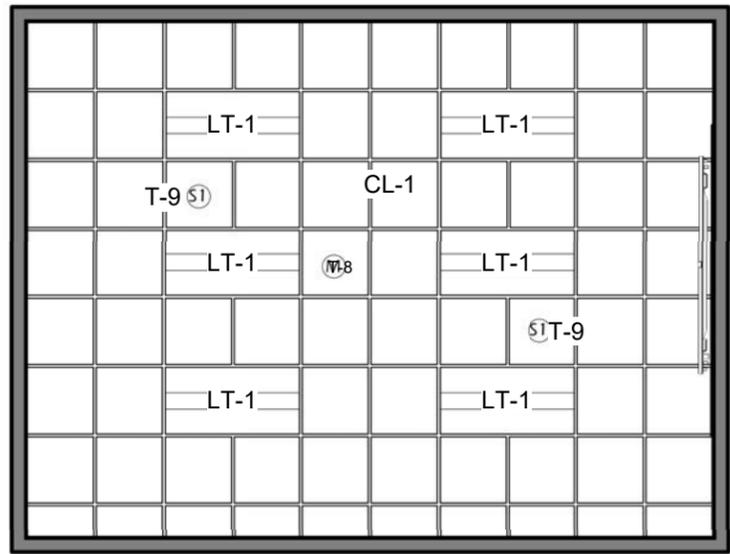



3 MEDIUM MEETING A RCP
3/16" = 1'-0"

DRAWING TITLE	
MEDIUM MEETING A	
DATE 05/24/19	
ARCHIVE NUMBER:	
DESIGNER: Designer	DWG SHEET NO: A105
DRAWN BY: Author	
CHECKED BY: Checker	
PROJECT NO: 12432P18D0002	SHEET XXX OF XXX

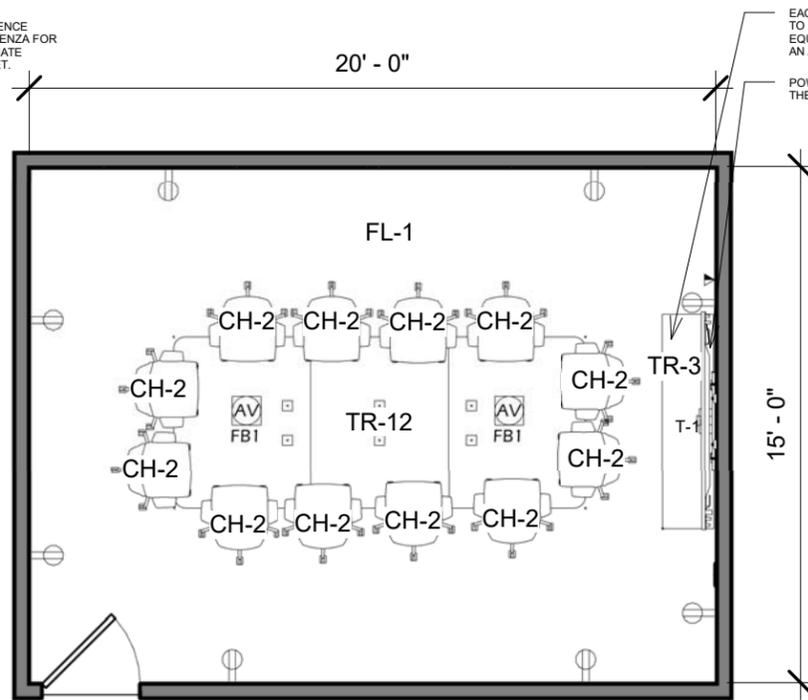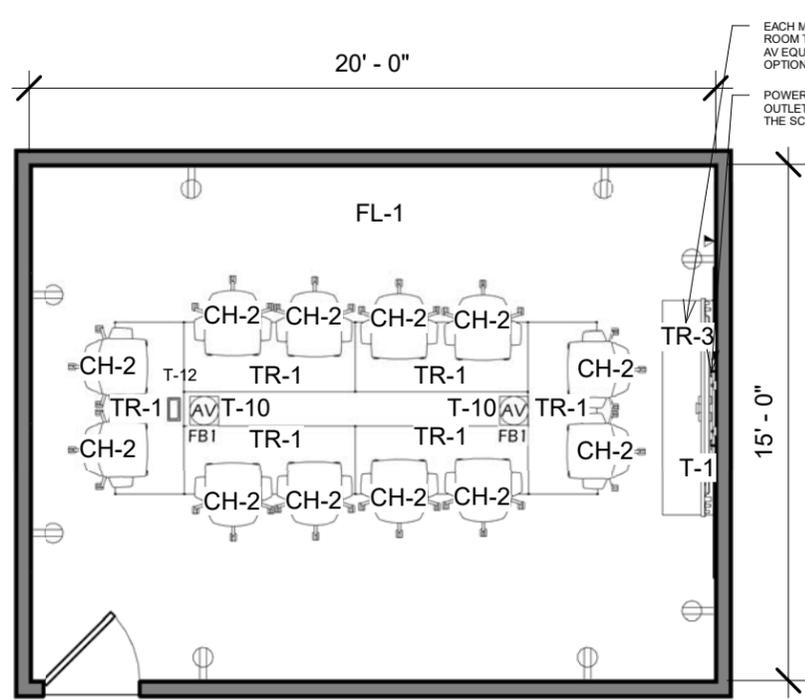



① MEDIUM MEETING A OPT. 1
3/16" = 1'-0"

② MEDIUM MEETING A OPT. 2
3/16" = 1'-0"

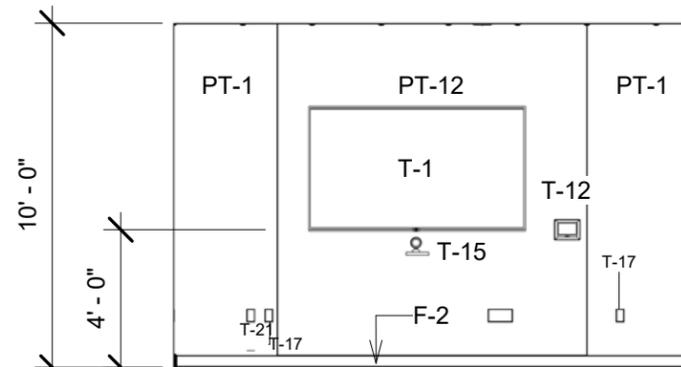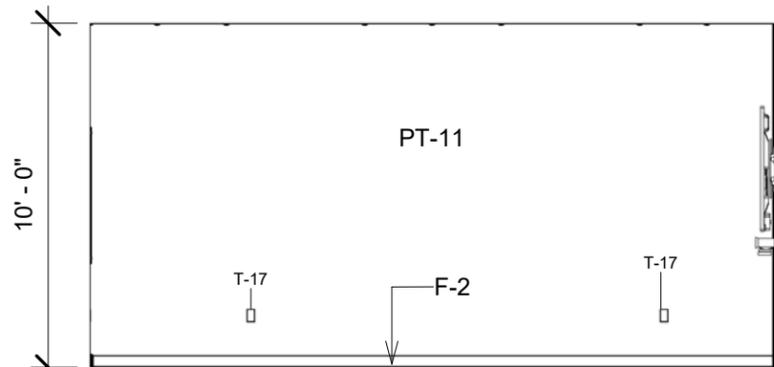

③ M. MEET. A ELEV. 1
3/16" = 1'-0"

④ M. MEET. A ELEV. 2
3/16" = 1'-0"

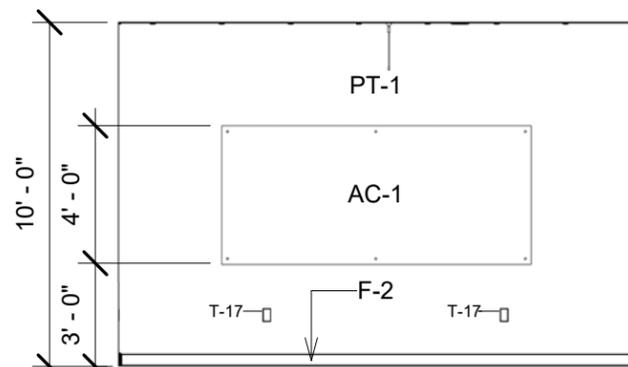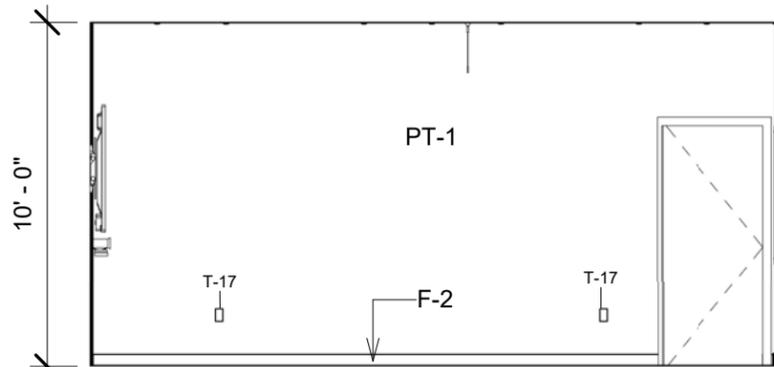

⑤ M. MEET. A ELEV. 3
3/16" = 1'-0"

⑥ M. MEET. A ELEV. 4
3/16" = 1'-0"

KEYNOTE LEGEND	
AC-1	BACK PAINTED WRITABLE GLASS MARKERBOARD- CLARIDGE GLASS MARKERBOARD BRILLIANT WHITE OR EQUAL
CH-2	DESK CHAIR W/ MESH SEAT, W/ ARMS & CASTERS
F-2	VINYL WALL BASE, SEE FLOOR FINISH FOR COLOR
FL-1	MODULAR CARPET TILE
PT-1	PAINT #1, PRIMARY WALL COLOR SW6539
PT-11	LARGE WALL GRAPHIC/IMAGE ACCENT
PT-12	TACKABLE ACCOUSTICAL WALL PANEL
T-10	FLOOR MOUNTED AUDIO VISUAL INTERFACE CONNECTION
T-12	WALL OR TABLE MOUNTED CONTROL PANEL
T-15	SURFACE MOUNTED VIDEO CONFERNCING CAMERA
T-17	120V WALL MOUNTED DUPLEX POWER OUTLET-WHITE
T-21	WALL MOUNTED DATA OUTLET
TR-1	24"Wx60"L TRAINING TABLE
TR-3	CREDENZA, MIN. 24" DEEP, FOR AV RACKS
TR-12	60"Dx144"W TABLE



United States Department of Agriculture
Forest Service

R-08

Southern Region

PROJECT NAME:
R-08 SOUTHERN REGION OFFICE SPACE TOOLS & TEMPLATES

UNITED STATES DEPARTMENT OF AGRICULTURE
FOREST SERVICE

SOUTHERN REGION (R8)
1720 PEACHTREE ROAD, NW
ATLANTA, GA. 30309

DRAWING TITLE
MEDIUM MEETING A

DATE
05/24/19

ARCHIVE NUMBER:

DESIGNER:
Designer

DWG SHEET NO:
A106

DRAWN BY:
Author

CHECKED BY:
Checker

PROJECT NO:
12432P18D0002

SHEET XXX OF XXX



KEYNOTE LEGEND	
CL-1	2X2 ACOUSTIC CEILING TILE, ASTM E1264, FORM 2, PATTERN E, FIRE CLASS A. DUCTED RETURNS ONLY.
LT-1	2'x4' RECESSED TROFFER
T-8	CEILING MOUNTED MICROPHONE
T-9	CEILING MOUNTED SPEAKER
T-10	FLOOR MOUNTED AUDIO VISUAL INTERFACE CONNECTION
T-17	120V WALL MOUNTED DUPLEX POWER OUTLET-WHITE
T-21	WALL MOUNTED DATA OUTLET



United States Department of Agriculture
Forest Service

R-08

Southern Region

PROJECT NAME:

R-08 SOUTHERN REGION OFFICE SPACE TOOLS & TEMPLATES

UNITED STATES DEPARTMENT OF AGRICULTURE FOREST SERVICE

SOUTHERN REGION (R8)
1720 PEACHTREE ROAD, NW
ATLANTA, GA. 30309

DRAWING TITLE

MEDIUM MEETING B

DATE
05/24/19

ARCHIVE NUMBER:

DESIGNER:
Designer

DWG SHEET NO:

A107


DRAWN BY:
Author

CHECKED BY:
Checker


PROJECT NO:
12432P18D0002

SHEET XXX OF XXX


1 MEDIUM MEETING B

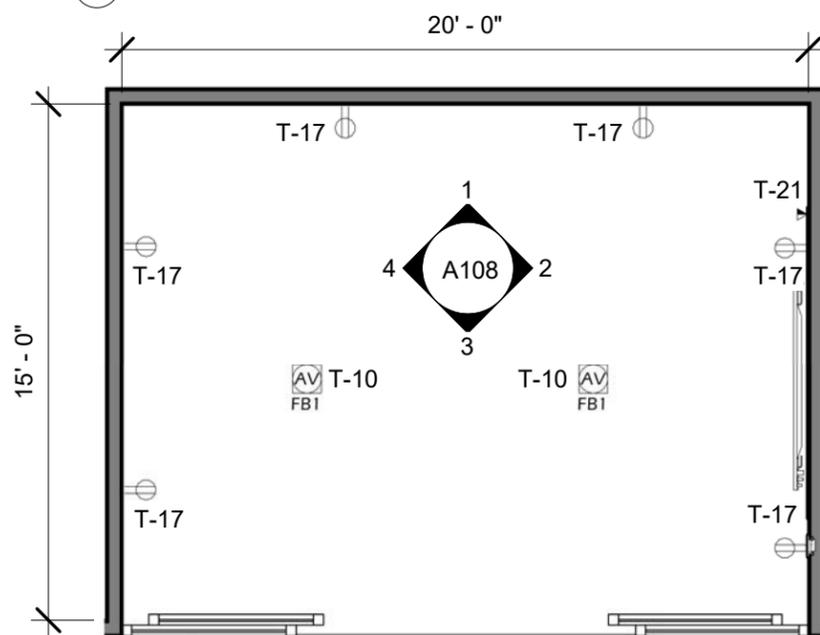


2 MEDIUM MEETING B
3/16" = 1'-0"

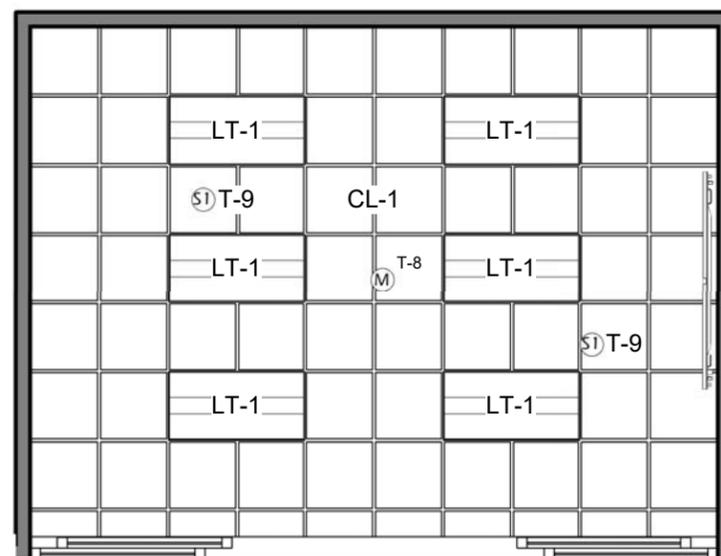


4 MEDIUM MEETING B RCP
3/16" = 1'-0"

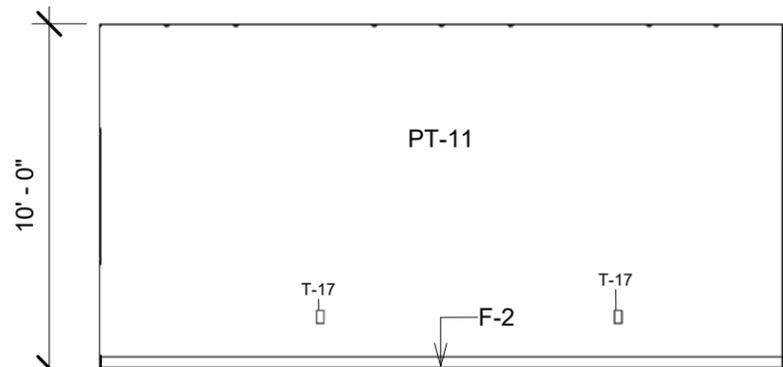


1 M. MEET. B ELEV. 1
3/16" = 1'-0"

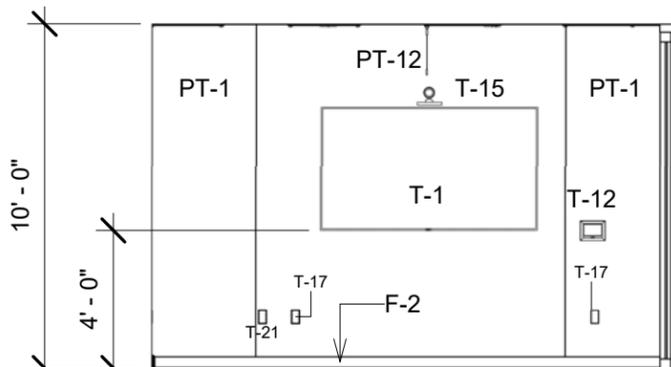

2 M. MEET. B ELEV. 2
3/16" = 1'-0"

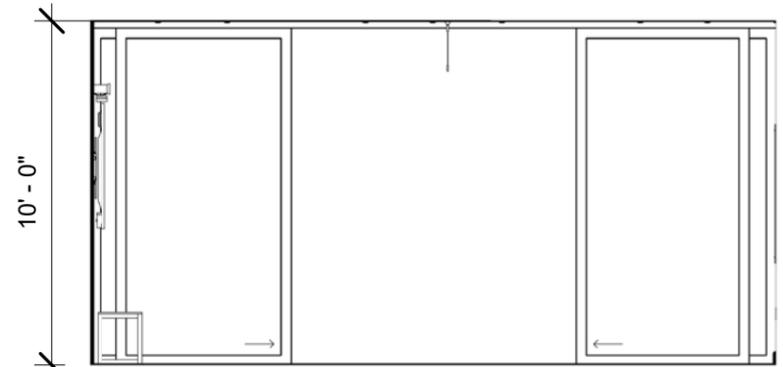

3 M. MEET. B ELEV. 3
3/16" = 1'-0"

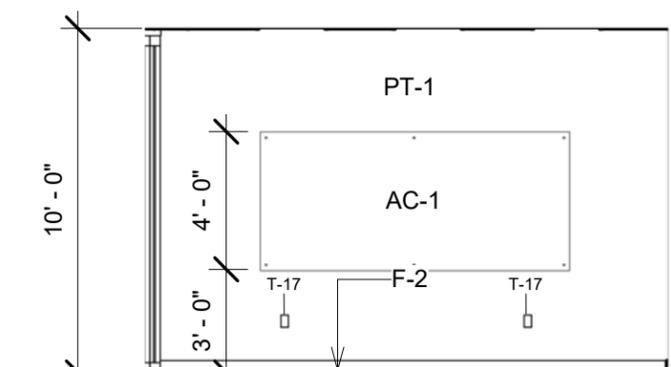

4 M. MEET. B ELEV. 4
3/16" = 1'-0"

KEYNOTE LEGEND	
AC-1	BACK PAINTED WRITABLE GLASS MARKERBOARD- CLARIDGE GLASS MARKERBOARD BRILLIANT WHITE OR EQUAL
CH-2	DESK CHAIR W/ MESH SEAT, W/ ARMS & CASTERS
F-2	VINYL WALL BASE, SEE FLOOR FINISH FOR COLOR
FL-1	MODULAR CARPET TILE
PT-1	PAINT #1, PRIMARY WALL COLOR SW6539
PT-11	LARGE WALL GRAPHIC/IMAGE ACCENT
PT-12	TACKABLE ACCOUSTICAL WALL PANEL
T-1	FLAT PANEL DISPLAY MONITOR W/ SPEAKERS AS REQUIRED
T-12	WALL OR TABLE MOUNTED CONTROL PANEL
T-15	SURFACE MOUNTED VIDEO CONFERNCING CAMERA
T-17	120V WALL MOUNTED DUPLEX POWER OUTLET-WHITE
T-21	WALL MOUNTED DATA OUTLET
TR-1	24"Wx60"L TRAINING TABLE
TR-3	CREDENZA, MIN. 24" DEEP, FOR AV RACKS
TR-12	60"Dx144"W TABLE



United States Department of Agriculture
Forest Service

R-08

Southern Region

PROJECT NAME:
R-08 SOUTHERN REGION OFFICE SPACE TOOLS & TEMPLATES

UNITED STATES DEPARTMENT OF AGRICULTURE
FOREST SERVICE

SOUTHERN REGION (R8)
1720 PEACHTREE ROAD, NW
ATLANTA, GA. 30309

DRAWING TITLE
MEDIUM MEETING B

DATE
05/24/19

ARCHIVE NUMBER:

DESIGNER:
Designer


DWG SHEET NO:
A108

DRAWN BY:
Author


CHECKED BY:
Checker

PROJECT NO:
12432P18D0002


SHEET XXX OF XXX

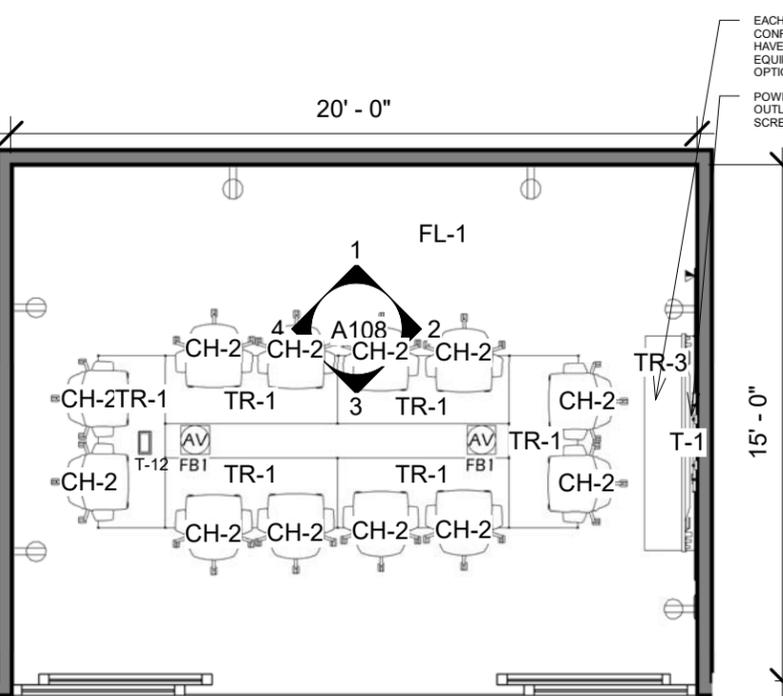

5 MEDIUM MEETING B OPT. 1
3/16" = 1'-0"

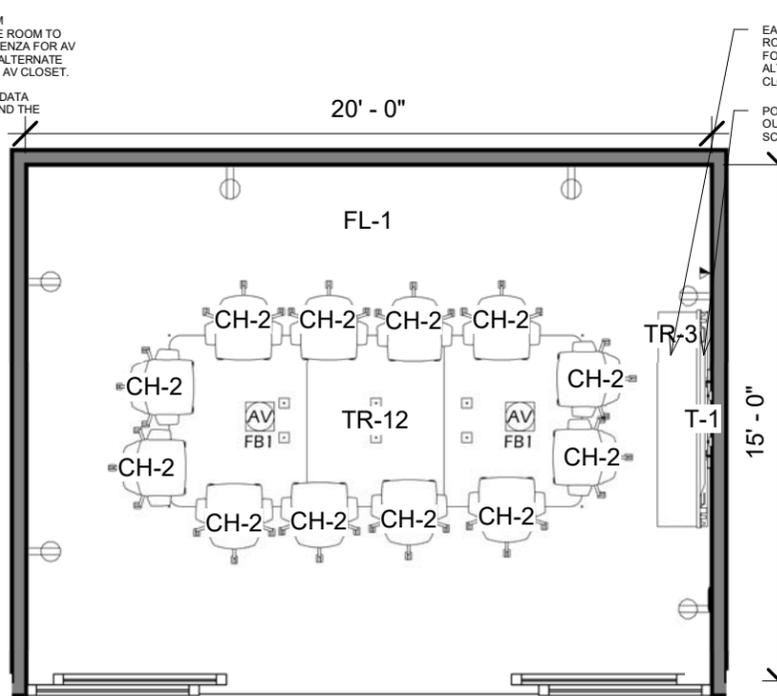

6 MEDIUM MEETING B OPT. 2
3/16" = 1'-0"

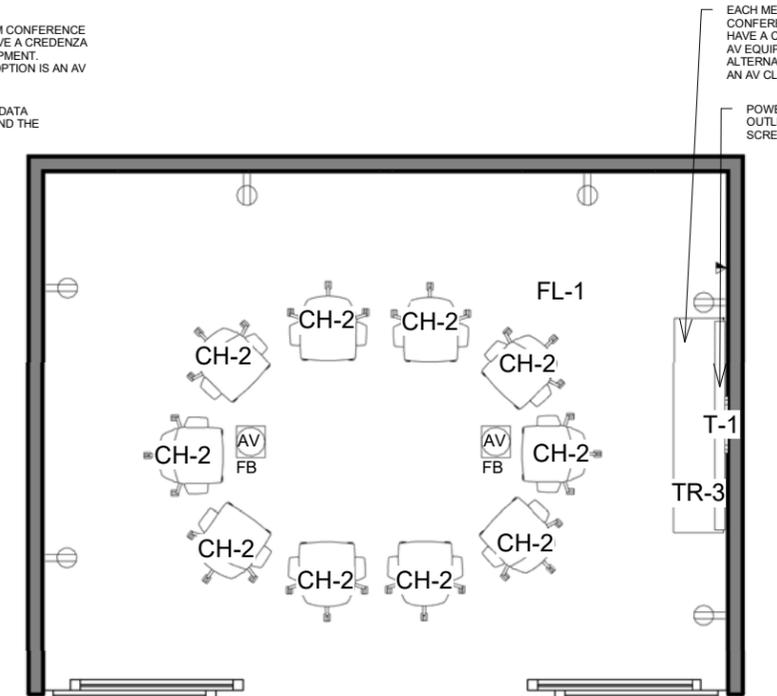

7 MEDIUM MEETING B OPT. 3
3/16" = 1'-0"

EACH MEDIUM CONFERENCE ROOM TO HAVE A CREDENZA FOR AV EQUIPMENT. ALTERNATE OPTION IS AN AV CLOSET.


EACH MEDIUM CONFERENCE ROOM TO HAVE A CREDENZA FOR AV EQUIPMENT. ALTERNATE OPTION IS AN AV CLOSET.

EACH MEDIUM CONFERENCE ROOM TO HAVE A CREDENZA FOR AV EQUIPMENT. ALTERNATE OPTION IS AN AV CLOSET.

POWER & TV DATA OUTLET BEHIND THE SCREEN

POWER & TV DATA OUTLET BEHIND THE SCREEN

POWER & TV DATA OUTLET BEHIND THE SCREEN

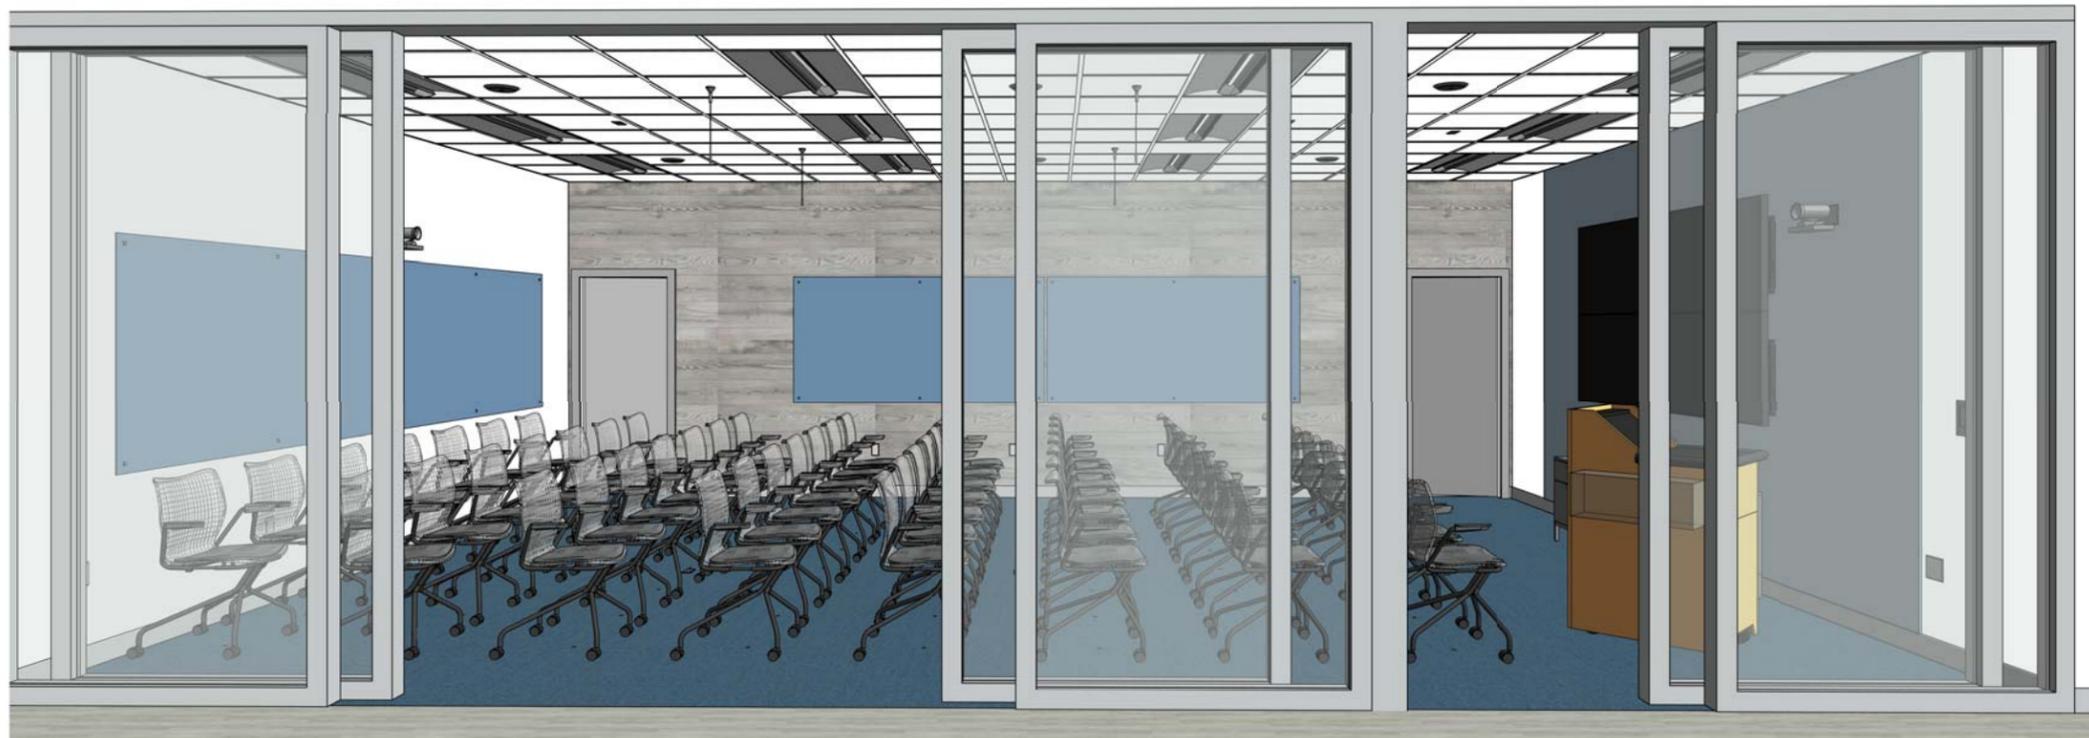

KEYNOTE LEGEND	
CL-1	2X2 ACOUSTIC CEILING TILE, ASTM E1264, FORM 2, PATTERN E, FIRE CLASS A. DUCTED RETURNS ONLY.
FL-2	MODULAR CARPET TILE - ALT 1
LT-1	2'x4' RECESSED TROFFER
T-3	VIDEO WALL DISPLAY SYSTEM
T-10	FLOOR MOUNTED AUDIO VISUAL INTERFACE CONNECTION
T-15	SURFACE MOUNTED VIDEO CONFENCING CAMERA
T-16	CEILING MOUNTED DATA OUTLET
T-17	120V WALL MOUNTED DUPLEX POWER OUTLET-WHITE
T-18	120V WALL MOUNTED QUAD POWER OUTLET- WHITE
T-21	WALL MOUNTED DATA OUTLET



United States Department of Agriculture
Forest Service

R-08

Southern Region

PROJECT NAME:

R-08 SOUTHERN REGION OFFICE SPACE TOOLS & TEMPLATES


UNITED STATES DEPARTMENT OF AGRICULTURE
FOREST SERVICE

SOUTHERN REGION (R8)
1720 PEACHTREE ROAD, NW
ATLANTA, GA. 30309

PARTITION NOTES:

1. ALL ROOMS LARGER THAN 500SF, OR SECURED ROOMS, TO HAVE DECK TO DECK PARTITIONS.

① LARGE MEETING A

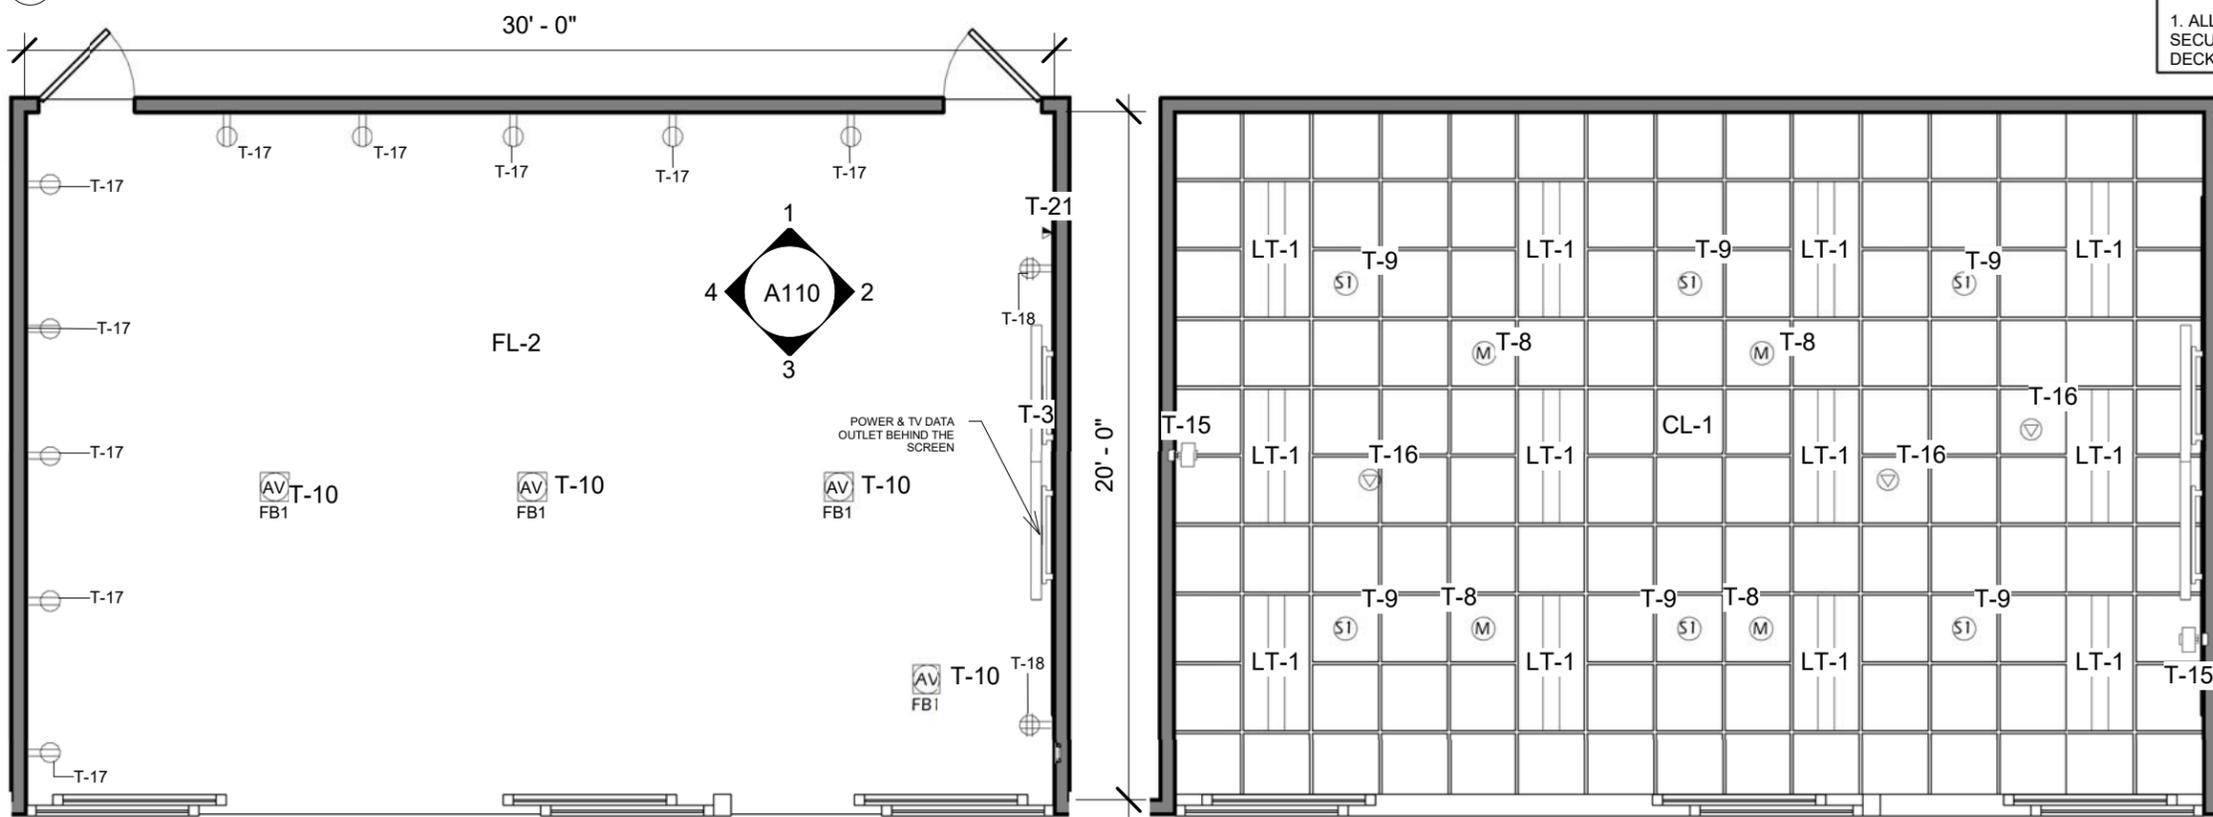

② LARGE MEETING A
3/16" = 1'-0"

③ LARGE MEETING A RCP
3/16" = 1'-0"

DRAWING TITLE

LARGE MEETING A

DATE

05/24/19

ARCHIVE NUMBER:

DESIGNER:

Designer

DWG SHEET NO.:

A109

DRAWN BY:

Author


CHECKED BY:

Checker


PROJECT NO.:

12432P18D0002


SHEET XXX OF XXX

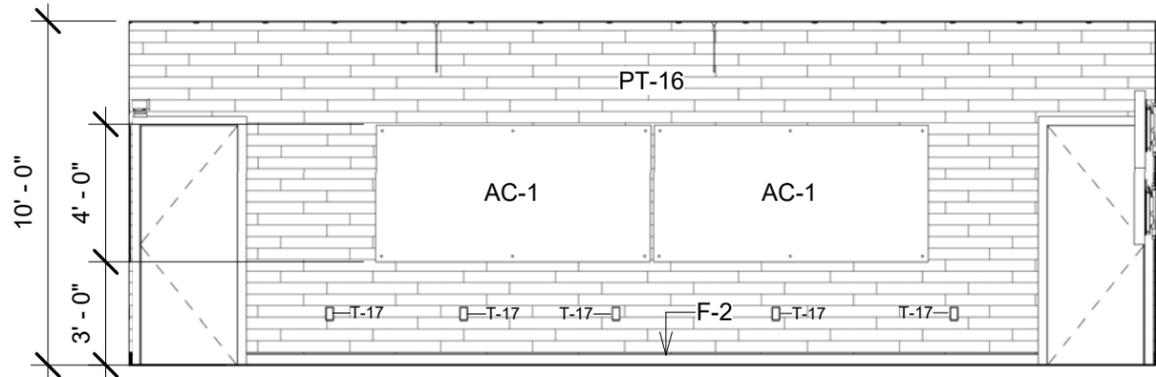


1 L. MEETING A ELEV. 1
3/16" = 1'-0"

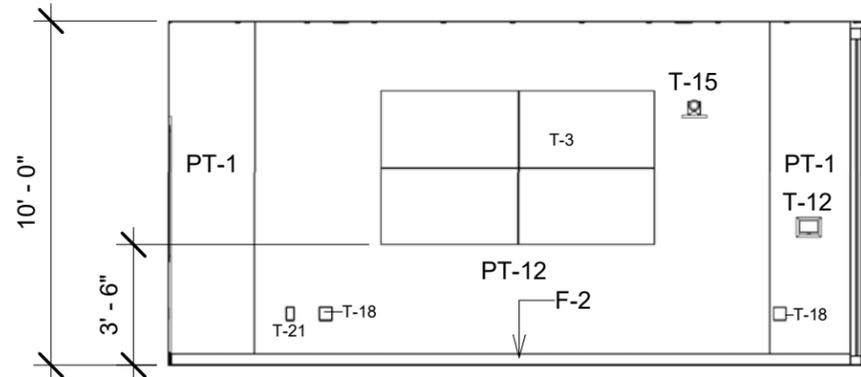

2 L. MEETING A ELEV. 2
3/16" = 1'-0"

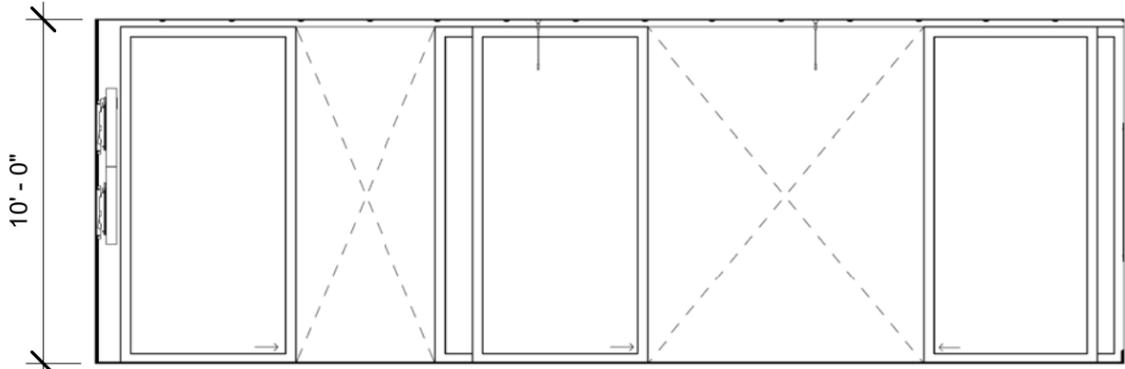

3 L. MEETING A ELEV. 3
3/16" = 1'-0"

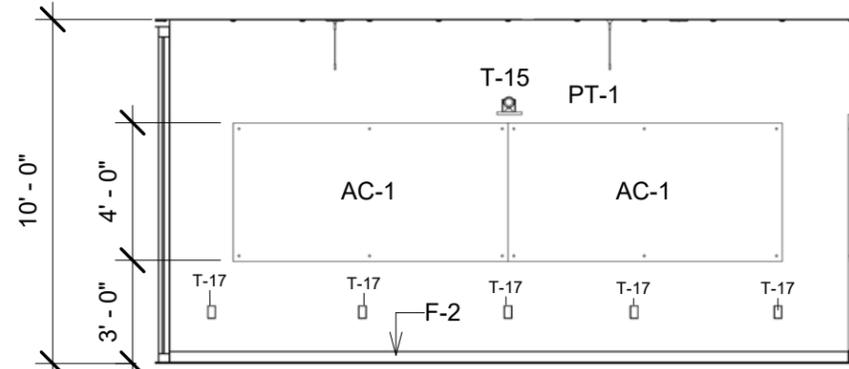

4 L. MEETING A ELEV. 4
3/16" = 1'-0"

KEYNOTE LEGEND	
AC-1	BACK PAINTED WRITABLE GLASS MARKERBOARD- CLARIDGE GLASS MARKERBOARD BRILLIANT WHITE OR EQUAL
CH-1	STACKABLE HIGHBACK TASK CHAIR
CH-2	DESK CHAIR W/ MESH SEAT, W/ ARMS & CASTERS
F-2	VINYL WALL BASE, SEE FLOOR FINISH FOR COLOR
FL-2	MODULAR CARPET TILE - ALT 1
PT-1	PAINT #1, PRIMARY WALL COLOR SW6539
PT-12	TACKABLE ACCOUSTICAL WALL PANEL
PT-16	ACCOUSTICAL WOOD WALL PANELS
SF-17	PRESENTER LECTERN W/ AV CONNECTIONS AS SHOWN
T-3	VIDEO WALL DISPLAY SYSTEM
T-10	FLOOR MOUNTED AUDIO VISUAL INTERFACE CONNECTION
T-12	WALL OR TABLE MOUNTED CONTROL PANEL
T-15	SURFACE MOUNTED VIDEO CONFENCING CAMERA
T-17	120V WALL MOUNTED DUPLEX POWER OUTLET-WHITE
T-18	120V WALL MOUNTED QUAD POWER OUTLET- WHITE
T-21	WALL MOUNTED DATA OUTLET
TR-1	24"Wx60"L TRAINING TABLE
TR-3	CRENDENZA, MIN. 24" DEEP, FOR AV RACKS
TR-6	36"x36" SQUARE TABLE



United States Department of Agriculture
Forest Service

R-08

Southern Region

PROJECT NAME:
R-08 SOUTHERN REGION OFFICE SPACE TOOLS & TEMPLATES

UNITED STATES DEPARTMENT OF AGRICULTURE
FOREST SERVICE

SOUTHERN REGION (R8)
1720 PEACHTREE ROAD, NW
ATLANTA, GA. 30309

DRAWING TITLE
LARGE MEETING A

DATE
05/24/19

ARCHIVE NUMBER:

DESIGNER:
Designer


DWG SHEET NO:
A110

DRAWN BY:
Author


CHECKED BY:
Checker

PROJECT NO:
12432P18D0002


SHEET XXX OF XXX

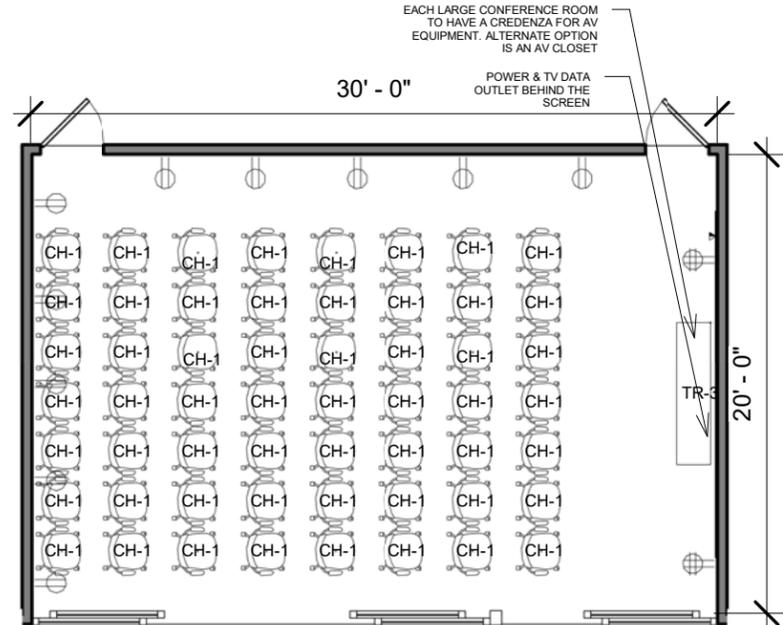

5 LARGE MEETING A OPT. 1
1/8" = 1'-0"

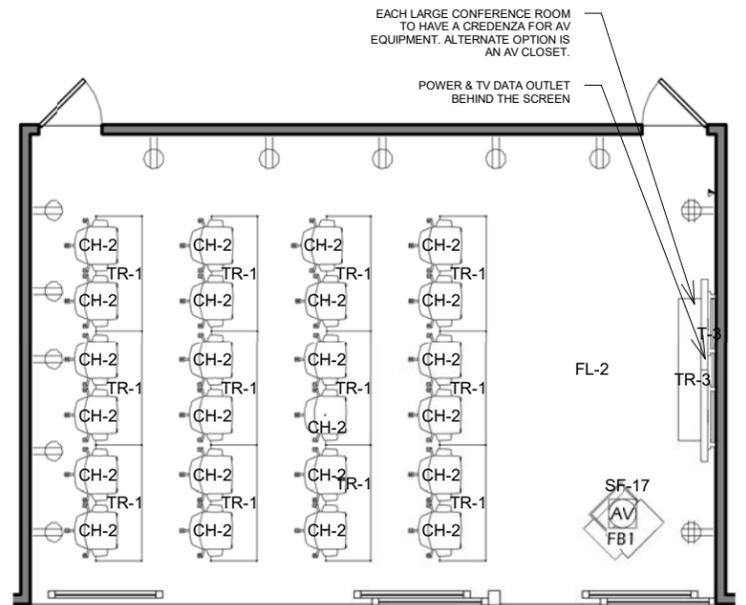

6 LARGE MEETING A OPT. 2
1/8" = 1'-0"

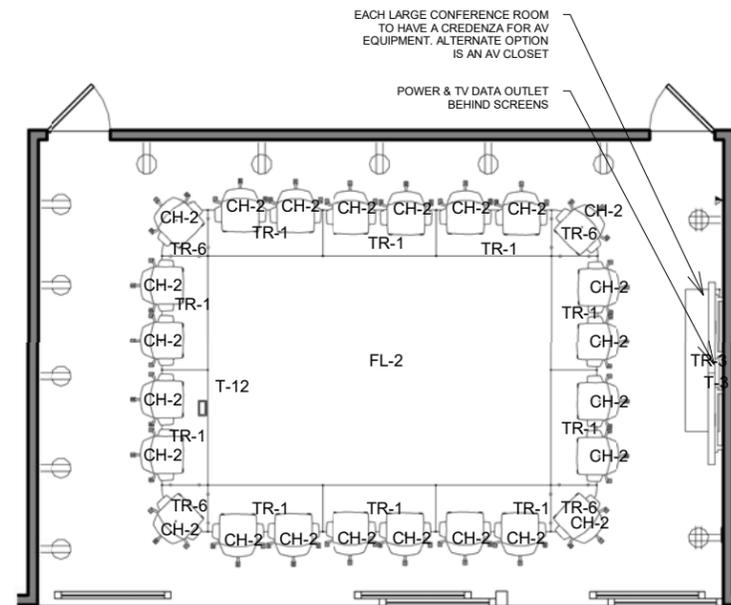

7 LARGE MEETING A OPT. 3
1/8" = 1'-0"



KEYNOTE LEGEND	
CL-1	2X2 ACOUSTIC CEILING TILE, ASTM E1264, FORM 2, PATTERN E, FIRE CLASS A. DUCTED RETURNS ONLY.
FL-2	MODULAR CARPET TILE - ALT 1
LT-1	2'x4' RECESSED TROFFER
T-3	VIDEO WALL DISPLAY SYSTEM
T-8	CEILING MOUNTED MICROPHONE
T-9	CEILING MOUNTED SPEAKER
T-10	FLOOR MOUNTED AUDIO VISUAL INTERFACE CONNECTION
T-15	SURFACE MOUNTED VIDEO CONFERNING CAMERA
T-16	CEILING MOUNTED DATA OUTLET
T-17	120V WALL MOUNTED DUPLEX POWER OUTLET-WHITE
T-18	120V WALL MOUNTED QUAD POWER OUTLET- WHITE
T-21	WALL MOUNTED DATA OUTLET

United States Department of Agriculture
Forest Service

R-08


Southern Region

PROJECT NAME:
R-08 SOUTHERN REGION OFFICE SPACE TOOLS & TEMPLATES

UNITED STATES DEPARTMENT OF AGRICULTURE
FOREST SERVICE


SOUTHERN REGION (R8)
1720 PEACHTREE ROAD, NW
ATLANTA, GA. 30309

1 LARGE MEETING B

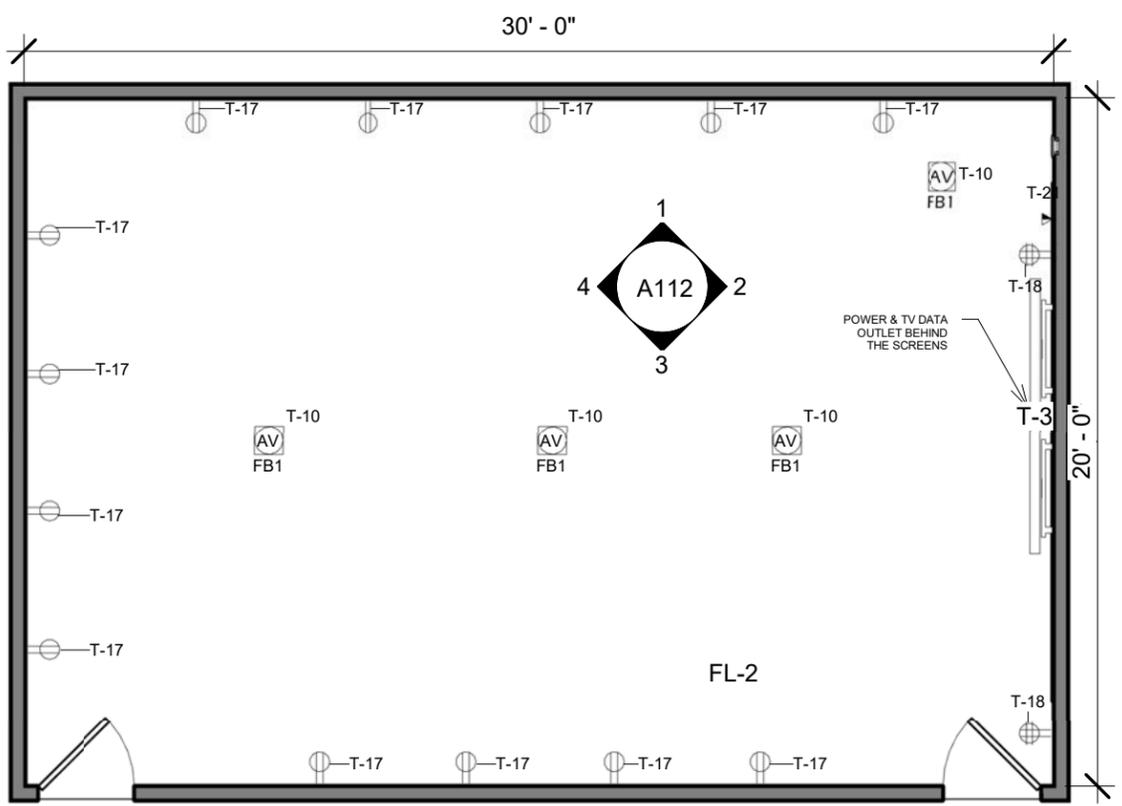


2 LARGE MEETING B
3/16" = 1'-0"

PARTITION NOTES:
1. ALL ROOMS LARGER THAN 500SF, OR SECURED ROOMS, TO HAVE DECK TO DECK PARTITIONS.

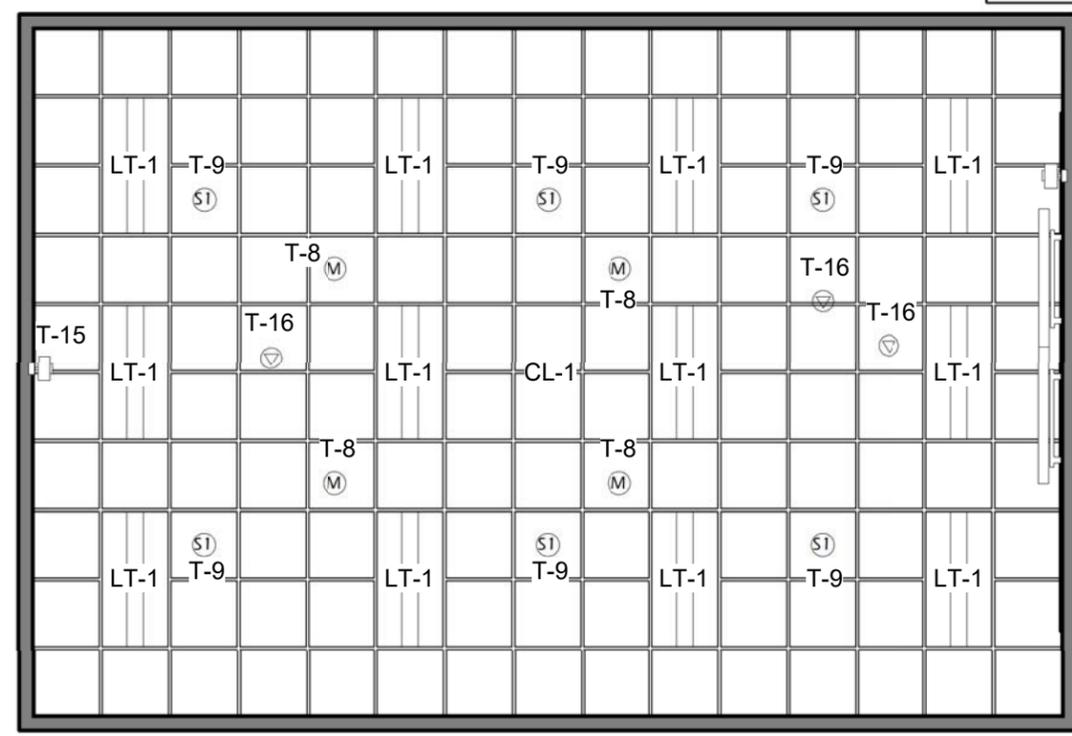


3 LARGE MEETING B RCP
3/16" = 1'-0"


DRAWING TITLE	
LARGE MEETING B	
DATE 05/24/19	
ARCHIVE NUMBER:	
DESIGNER: Designer	DWG SHEET NO: A111
DRAWN BY: Author	
CHECKED BY: Checker	
PROJECT NO: 12432P18D0002	SHEET XXX OF XXX

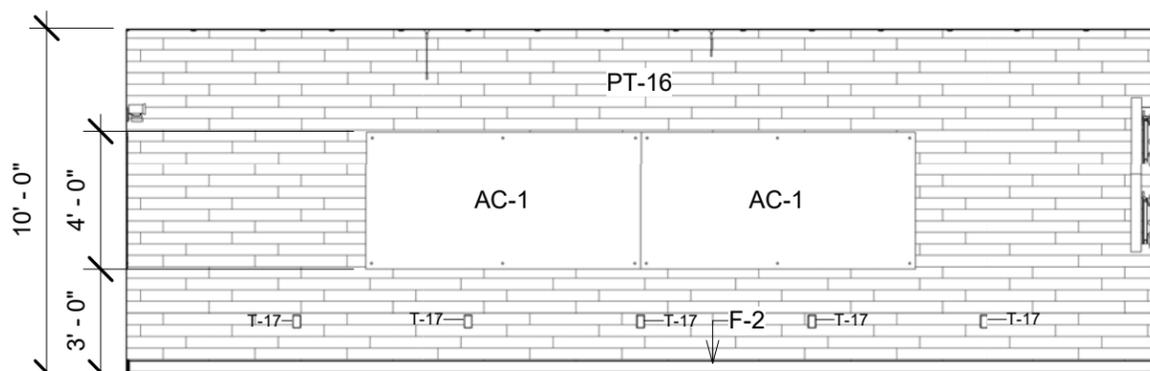


1 L. MEETING B ELEV. 1
3/16" = 1'-0"

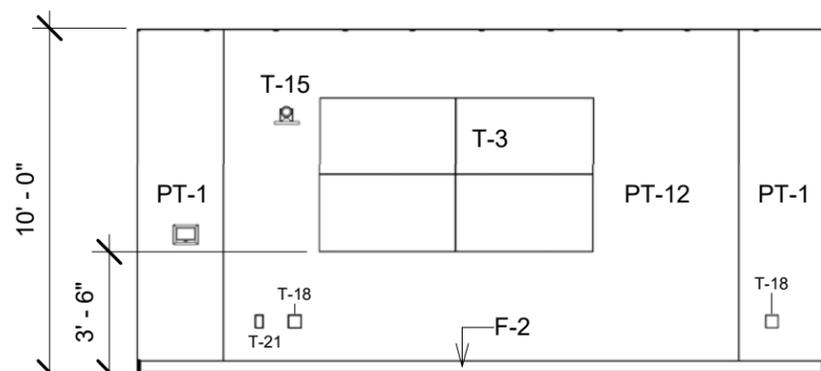

2 L. MEETING B ELEV. 2
3/16" = 1'-0"

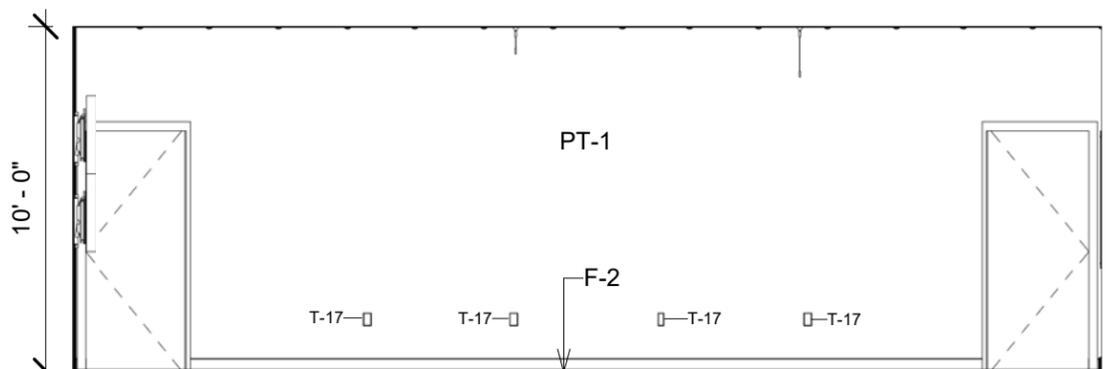

3 L. MEETING B ELEV. 3
3/16" = 1'-0"

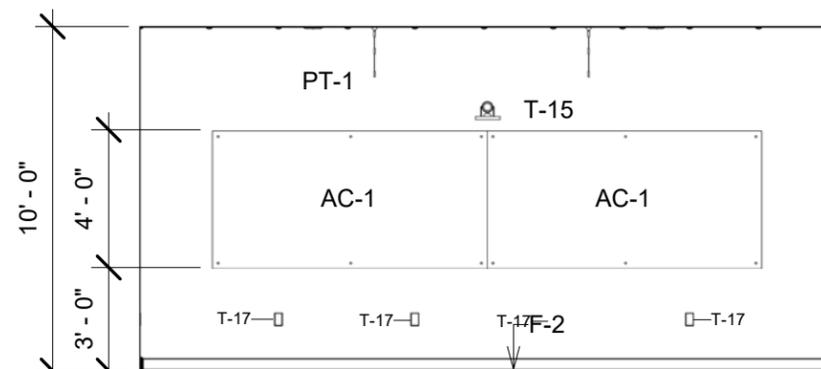

4 L. MEETING B ELEV. 4
3/16" = 1'-0"

KEYNOTE LEGEND	
AC-1	BACK PAINTED WRITABLE GLASS MARKERBOARD- CLARIDGE GLASS MARKERBOARD BRILLIANT WHITE OR EQUAL
CH-1	STACKABLE HIGHBACK TASK CHAIR
CH-2	DESK CHAIR W/ MESH SEAT, W/ ARMS & CASTERS
F-2	VINYL WALL BASE, SEE FLOOR FINISH FOR COLOR
FL-2	MODULAR CARPET TILE - ALT 1
PT-1	PAINT #1, PRIMARY WALL COLOR SW6539
PT-12	TACKABLE ACCOUSTICAL WALL PANEL
PT-16	ACCOUSTICAL WOOD WALL PANELS
SF-17	PRESENTER LECTERN W/ AV CONNECTIONS AS SHOWN
T-3	VIDEO WALL DISPLAY SYSTEM
T-15	SURFACE MOUNTED VIDEO CONFERNING CAMERA
T-17	120V WALL MOUNTED DUPLEX POWER OUTLET-WHITE
T-18	120V WALL MOUNTED QUAD POWER OUTLET- WHITE
T-21	WALL MOUNTED DATA OUTLET
TR-1	24"Wx60"L TRAINING TABLE
TR-3	CRENZENZA, MIN. 24" DEEP, FOR AV RACKS
TR-6	36"x36" SQUARE TABLE



United States Department of Agriculture
Forest Service

R-08

Southern Region

PROJECT NAME:
*R-08 SOUTHERN
REGION OFFICE
SPACE TOOLS &
TEMPLATES*

UNITED STATES
DEPARTMENT OF
AGRICULTURE
FOREST SERVICE

SOUTHERN REGION (R8)
1720 PEACHTREE ROAD, NW
ATLANTA, GA. 30309

DRAWING TITLE

*LARGE MEETING
B*

DATE
05/24/19

ARCHIVE NUMBER:

DESIGNER:
Designer


DWG SHEET NO:
A112

DRAWN BY:
Author


CHECKED BY:
Checker

PROJECT NO:
12432P18D0002


SHEET XXX OF XXX

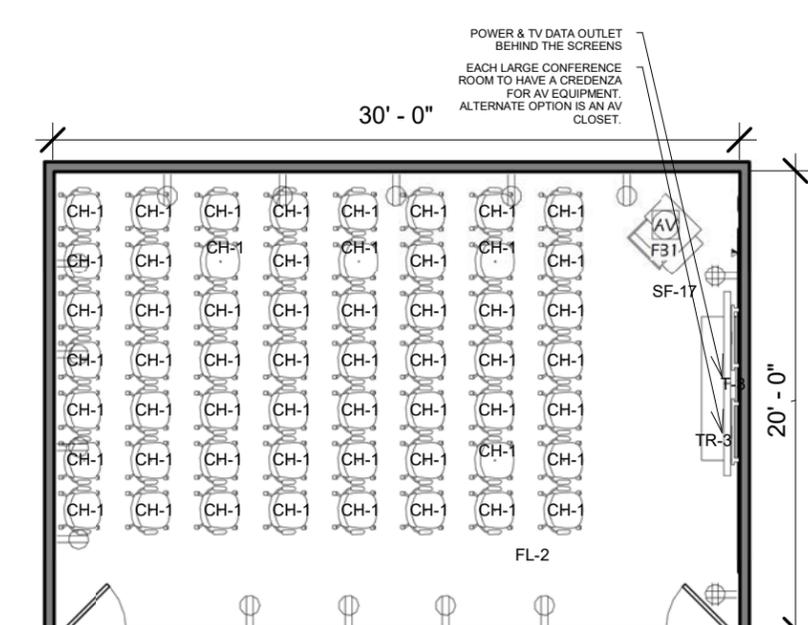

5 LARGE MEETING B OPT. 1
1/8" = 1'-0"

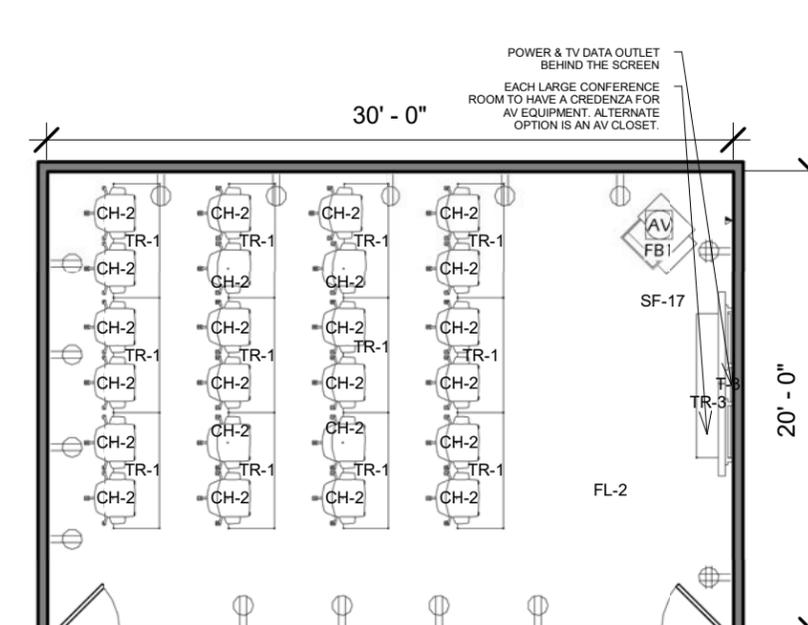

6 LARGE MEETING B OPT. 2
1/8" = 1'-0"

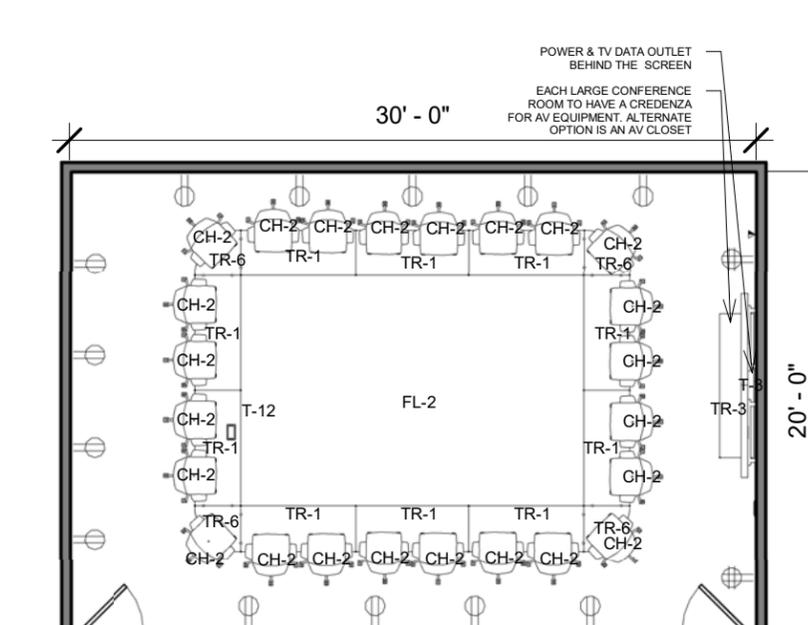

7 LARGE MEETING B OPT. 3
1/8" = 1'-0"



11 X LARGE MEETING

KEYNOTE LEGEND	
FL-1	MODULAR CARPET TILE
SF-17	PRESENTER LECTERN W/ AV CONNECTIONS AS SHOWN
T-3	VIDEO WALL DISPLAY SYSTEM
T-10	FLOOR MOUNTED AUDIO VISUAL INTERFACE CONNECTION
T-17	120V WALL MOUNTED DUPLEX POWER OUTLET-WHITE
T-18	120V WALL MOUNTED QUAD POWER OUTLET- WHITE
T-21	WALL MOUNTED DATA OUTLET

PARTITION NOTES:
 1. ALL ROOMS LARGER THAN 500SF, OR SECURED ROOMS, TO HAVE DECK TO DECK PARTITIONS.



United States Department of Agriculture
Forest Service

R-08

Southern Region

PROJECT NAME:

R-08 SOUTHERN REGION OFFICE SPACE TOOLS & TEMPLATES

UNITED STATES DEPARTMENT OF AGRICULTURE FOREST SERVICE

SOUTHERN REGION (R8)
1720 PEACHTREE ROAD, NW
ATLANTA, GA. 30309

DRAWING TITLE

X-LARGE MEETING

DATE

05/24/19

ARCHIVE NUMBER:

DESIGNER:

Designer

DWG SHEET NO.:

A113

DRAWN BY:

Author


CHECKED BY:

Checker


PROJECT NO.:

12432P18D0002


SHEET XXX OF XXX

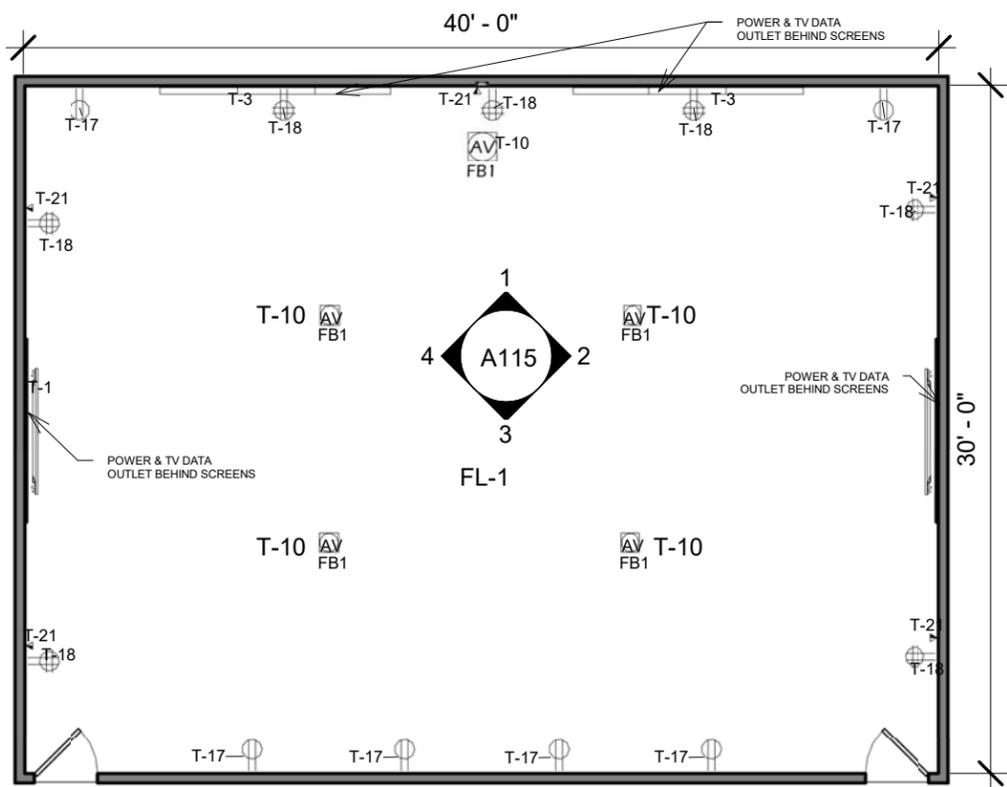


2 X-LARGE MEETING A
1/8" = 1'-0"

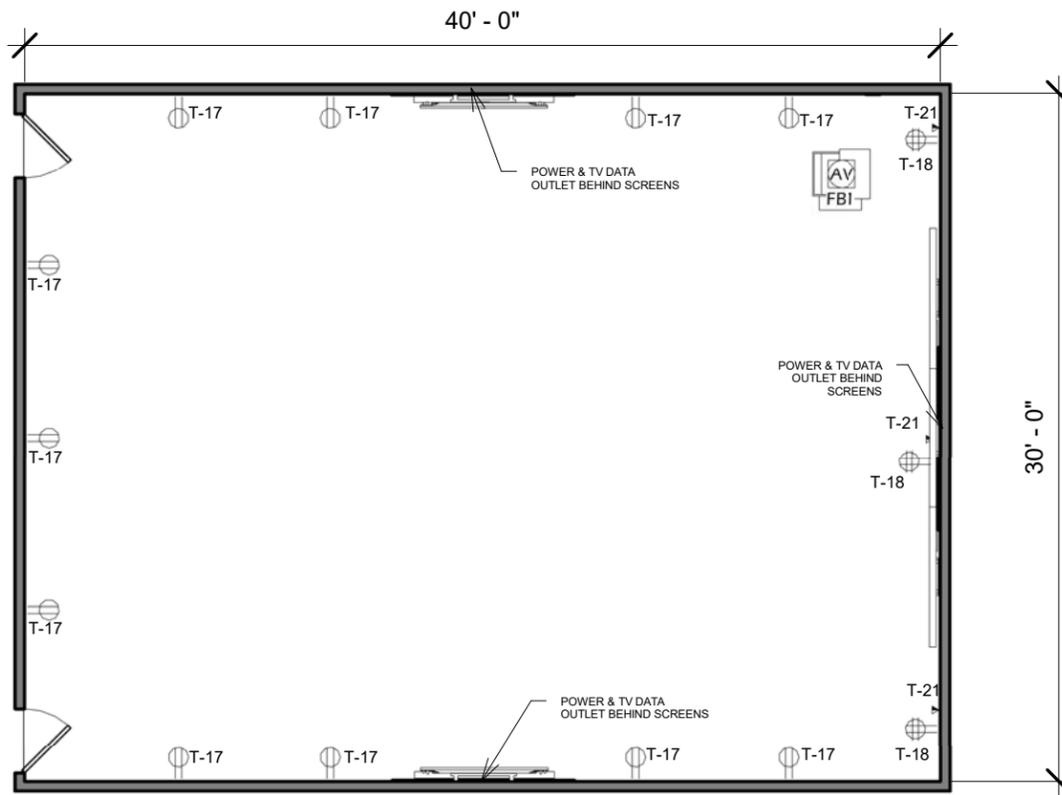


3 X-LARGE MEETING B
1/8" = 1'-0"

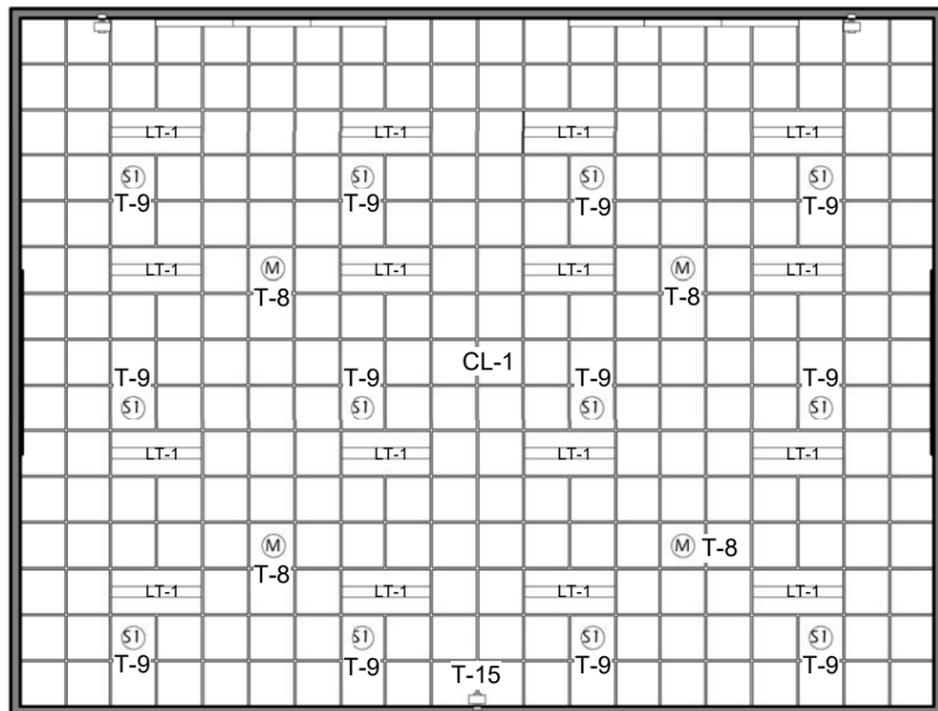

1 X-LARGE MEETING RCP
1/8" = 1'-0"

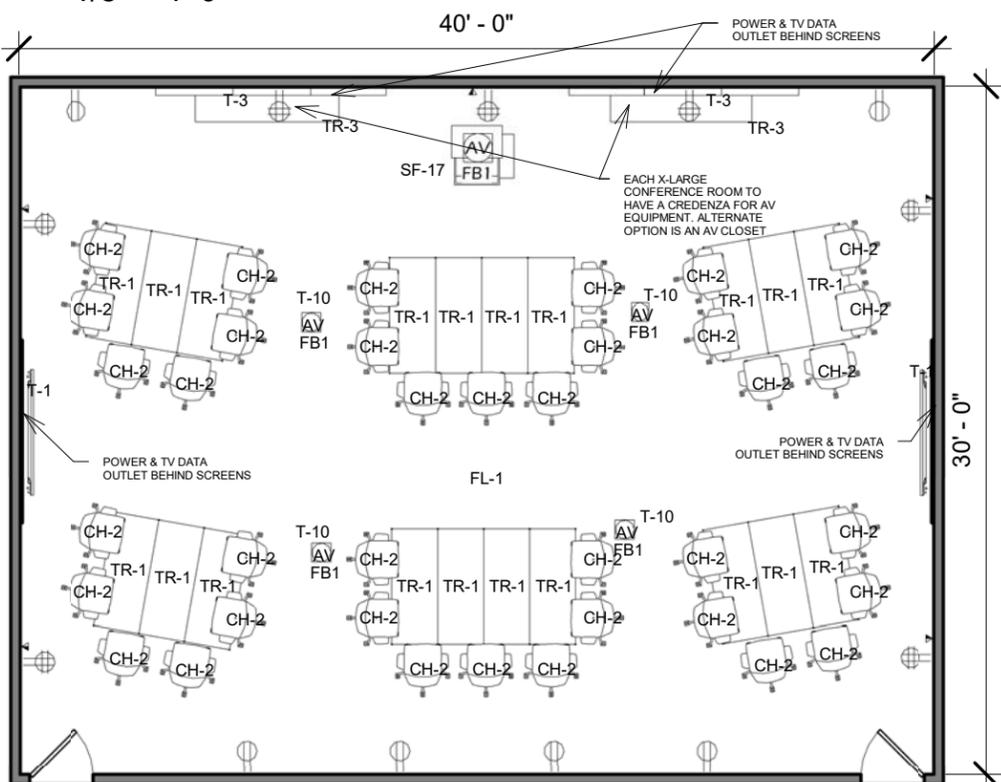

2 X-LARGE MEETING A FURNITURE
1/8" = 1'-0"

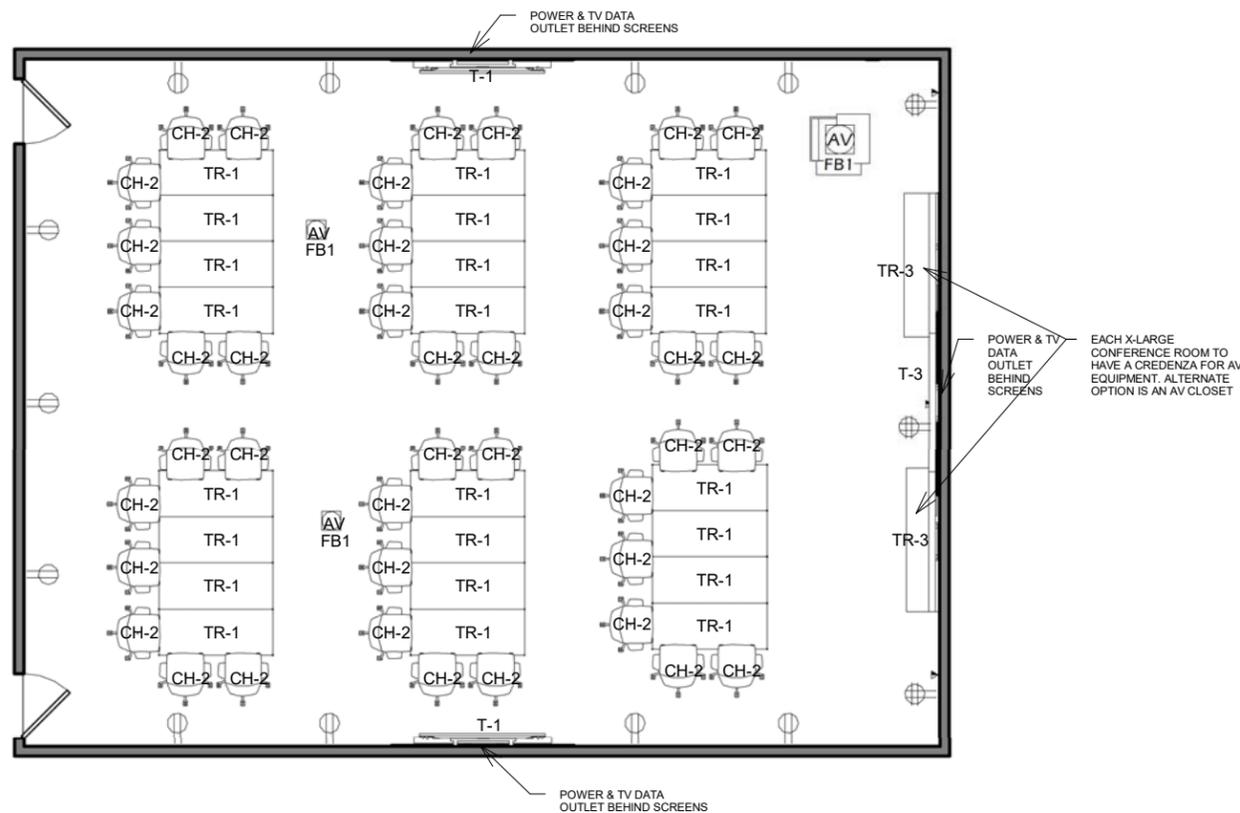

3 X-LARGE MEETING B FURNITURE
1/8" = 1'-0"

KEYNOTE LEGEND	
CH-2	DESK CHAIR W/ MESH SEAT, W/ ARMS & CASTERS
CL-1	2X2 ACCOUSTIC CEILING TILE, ASTM E1264, FORM 2, PATTERN E, FIRE CLASS A. DUCTED RETURNS ONLY.
FL-1	MODULAR CARPET TILE
LT-1	2'x4' RECESSED TROFFER
SF-17	PRESENTER LECTERN W/ AV CONNECTIONS AS SHOWN
T-1	FLAT PANEL DISPLAY MONITOR W/ SPEAKERS AS REQUIRED
T-3	VIDEO WALL DISPLAY SYSTEM
T-8	CEILING MOUNTED MICROPHONE
T-9	CEILING MOUNTED SPEAKER
T-10	FLOOR MOUNTED AUDIO VISUAL INTERFACE CONNECTION
T-15	SURFACE MOUNTED VIDEO CONFERNING CAMERA
TR-1	24"Wx60"L TRAINING TABLE
TR-3	CREDENZA, MIN. 24" DEEP, FOR AV RACKS



United States Department of Agriculture
Forest Service

R-08

Southern Region

PROJECT NAME:
R-08 SOUTHERN REGION OFFICE SPACE TOOLS & TEMPLATES

UNITED STATES DEPARTMENT OF AGRICULTURE
FOREST SERVICE

SOUTHERN REGION (R8)
1720 PEACHTREE ROAD, NW
ATLANTA, GA. 30309

DRAWING TITLE
X-LARGE MEETING

DATE
05/24/19

ARCHIVE NUMBER:

DESIGNER:
Designer

DWG SHEET NO:
A114

DRAWN BY:
Author

CHECKED BY:
Checker

PROJECT NO:
12432P18D0002

SHEET XXX OF XXX

KEYNOTE LEGEND	
AC-1	BACK PAINTED WRITABLE GLASS MARKERBOARD- CLARIDGE GLASS MARKERBOARD BRILLIANT WHITE OR EQUAL
F-2	VINYL WALL BASE, SEE FLOOR FINISH FOR COLOR
PT-1	PAINT #1, PRIMARY WALL COLOR SW6539
PT-11	LARGE WALL GRAPHIC/IMAGE ACCENT
PT-12	TACKABLE ACCOUSTICAL WALL PANEL
T-1	FLAT PANEL DISPLAY MONITOR W/ SPEAKERS AS REQUIRED
T-3	VIDEO WALL DISPLAY SYSTEM
T-12	WALL OR TABLE MOUNTED CONTROL PANEL
T-15	SURFACE MOUNTED VIDEO CONFERNING CAMERA
T-17	120V WALL MOUNTED DUPLEX POWER OUTLET-WHITE
T-18	120V WALL MOUNTED QUAD POWER OUTLET- WHITE
T-21	WALL MOUNTED DATA OUTLET



United States Department of Agriculture
Forest Service

R-08

Southern Region

PROJECT NAME:
R-08 SOUTHERN REGION OFFICE SPACE TOOLS & TEMPLATES

UNITED STATES DEPARTMENT OF AGRICULTURE
FOREST SERVICE

SOUTHERN REGION (R8)
1720 PEACHTREE ROAD, NW
ATLANTA, GA. 30309

DRAWING TITLE

X-LARGE MEETING


DATE
05/24/19

ARCHIVE NUMBER:


DESIGNER: Designer	DWG SHEET NO: A115
DRAWN BY: Author	

CHECKED BY: Checker	
------------------------	--


PROJECT NO: 12432P18D0002	SHEET XXX OF XXX
------------------------------	------------------

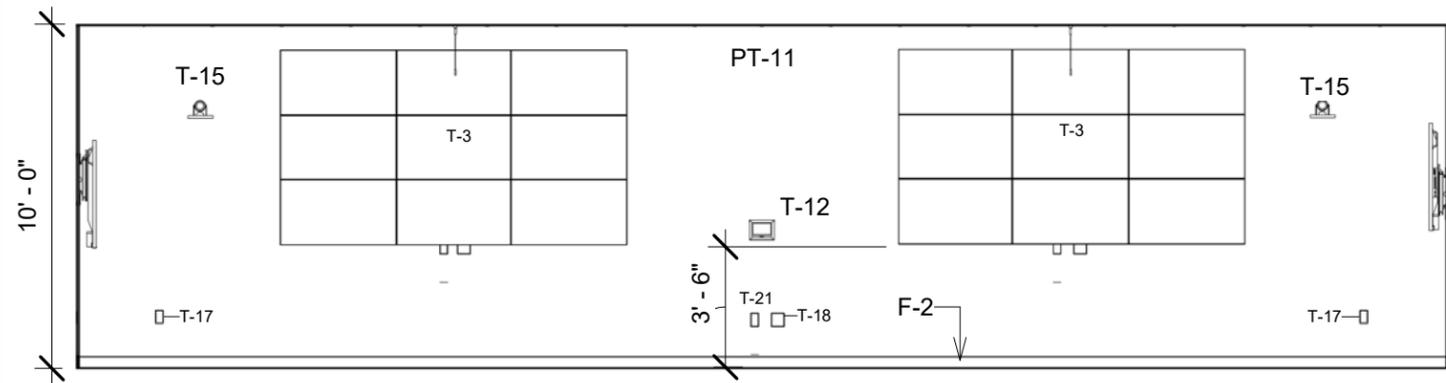


1 X LARGE MEETING ELEV. 1
3/16" = 1'-0"

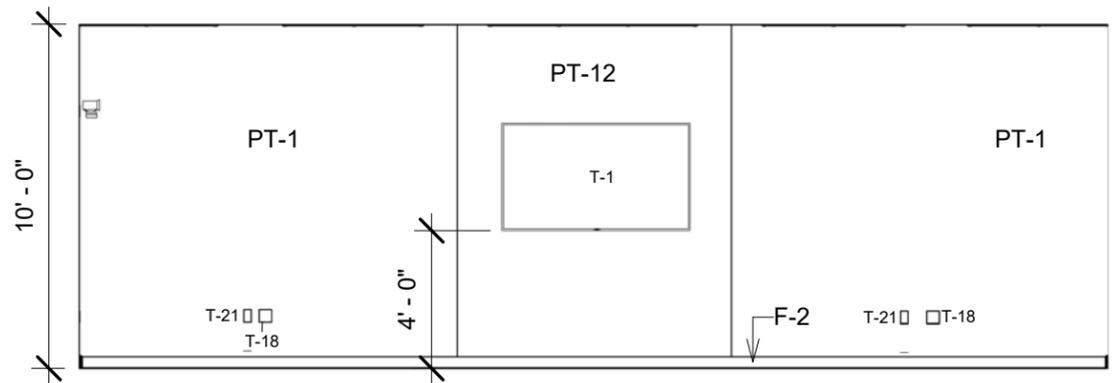


2 X LARGE MEETING ELEV. 2
3/16" = 1'-0"

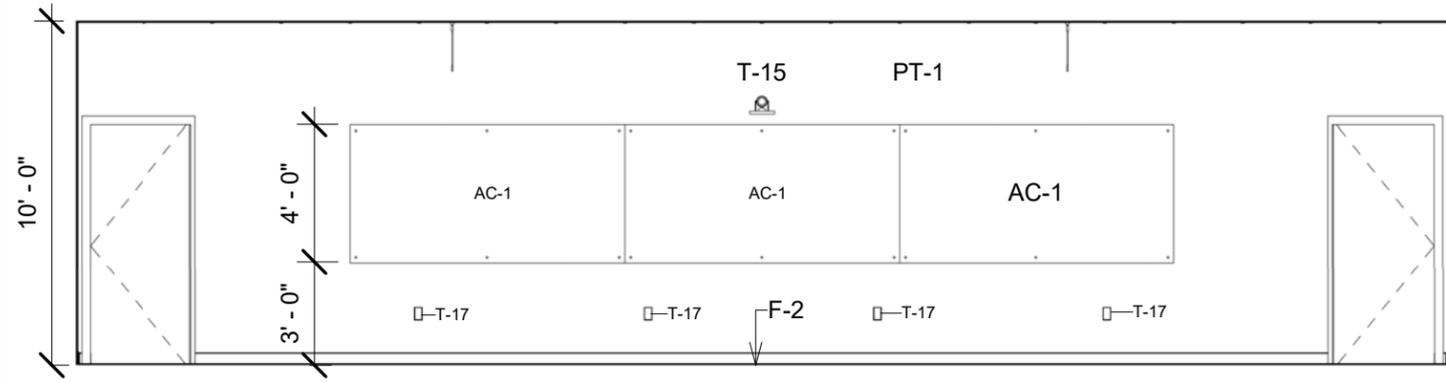


3 X LARGE MEETING ELEV. 3
3/16" = 1'-0"

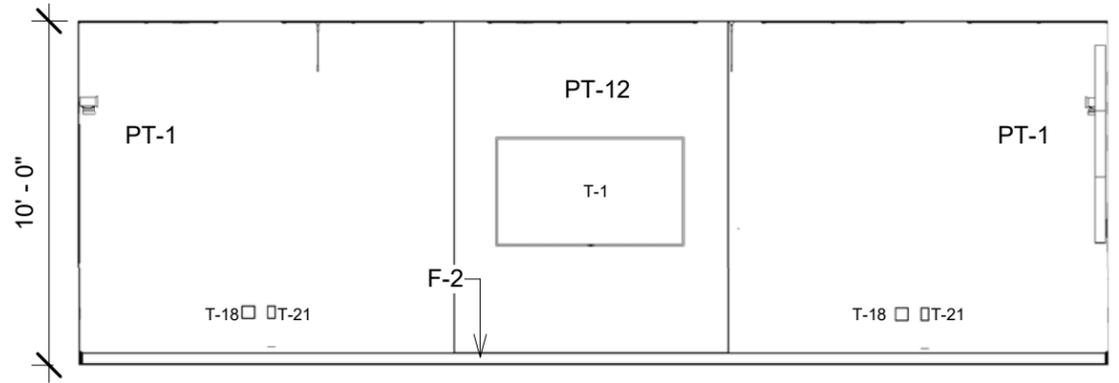


4 X LARGE MEETING ELEV. 4
3/16" = 1'-0"

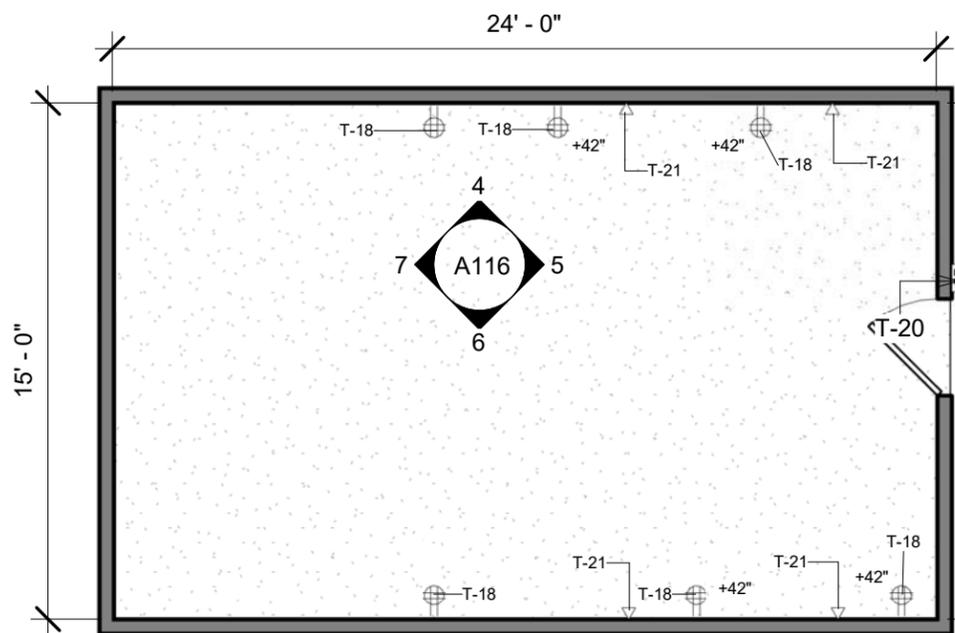


① IT SHOP
3/16" = 1'-0"

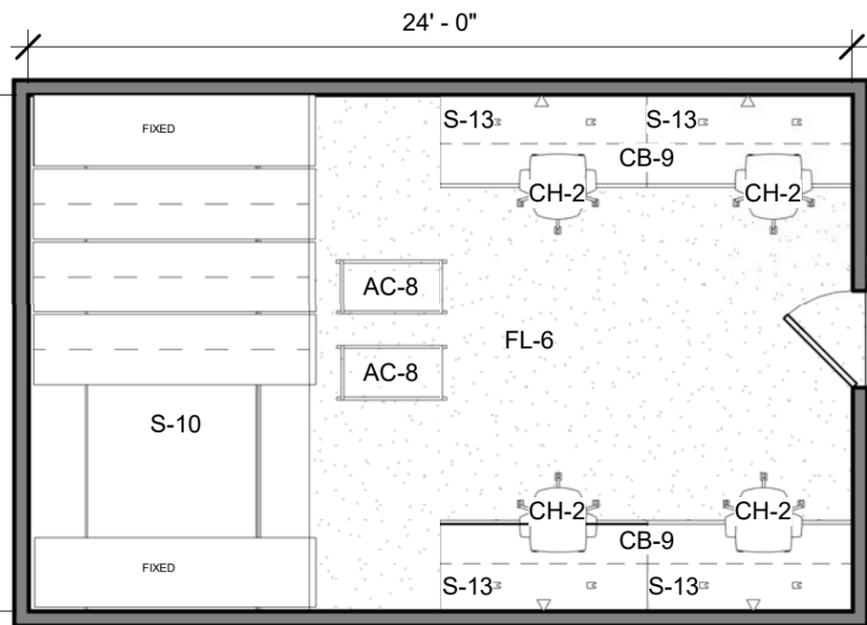


② IT SHOP FURNITURE
3/16" = 1'-0"

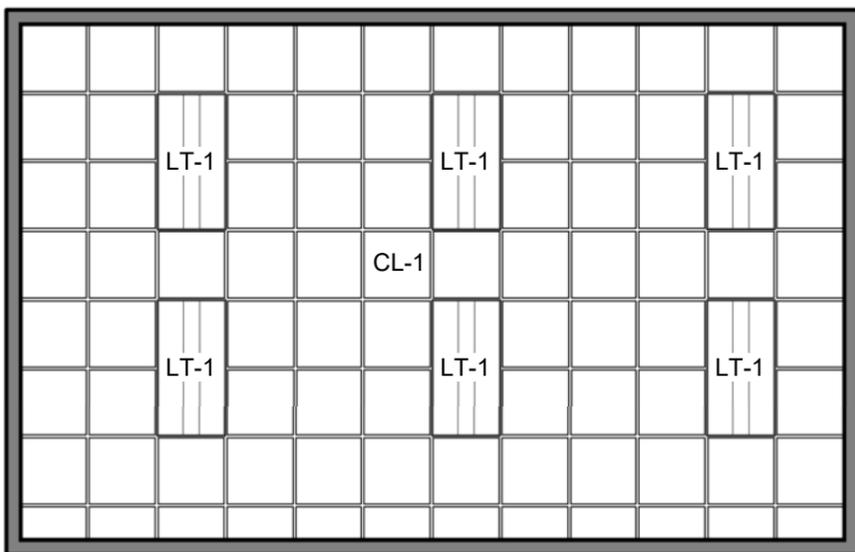


③ IT SHOP RCP
3/16" = 1'-0"

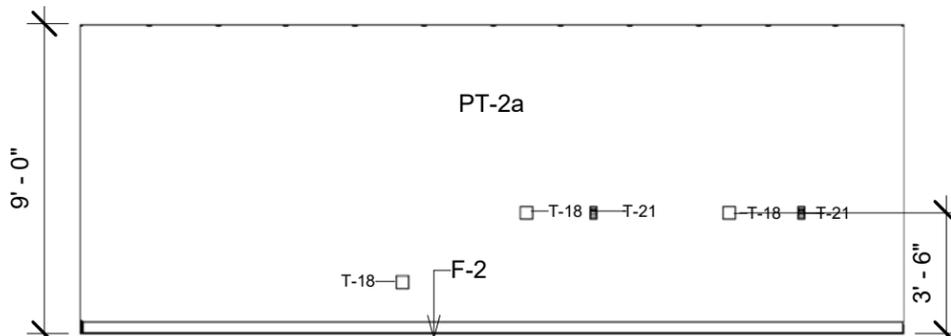


④ IT ELEV. 1
3/16" = 1'-0"

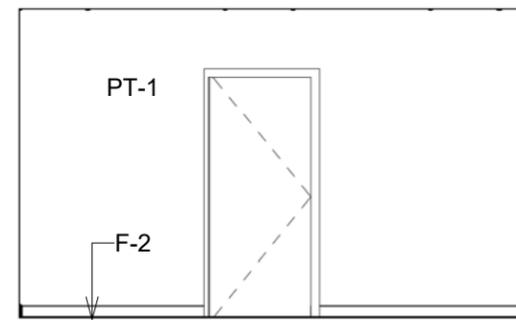

⑤ IT ELEV. 2
3/16" = 1'-0"

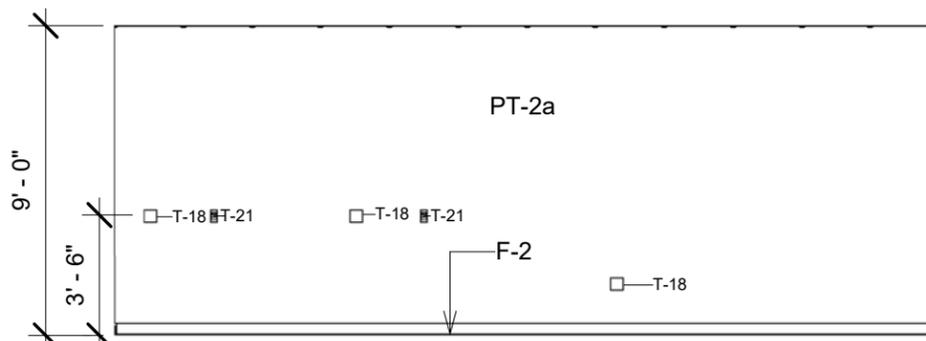

⑥ IT ELEV. 3
3/16" = 1'-0"

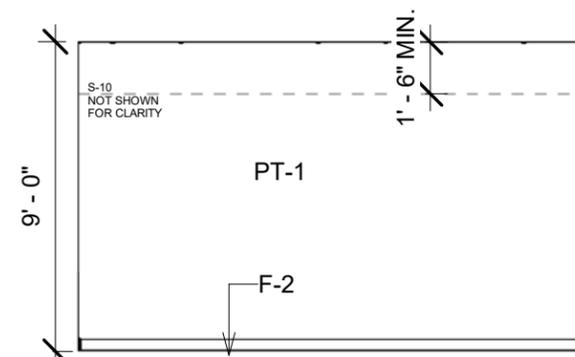

⑦ IT ELEV. 4
3/16" = 1'-0"

KEYNOTE LEGEND	
AC-8	MOBILE LAB CART, 38"L x 19"D x 36"H
CB-9	COUNTERTOP, 24" DEEP
CH-2	DESK CHAIR W/ MESH SEAT, W/ ARMS & CASTERS
CL-1	2X2 ACCOUSTIC CEILING TILE, ASTM E1264, FORM 2, PATTERN E, FIRE CLASS A. DUCTED RETURNS ONLY.
F-2	VINYL WALL BASE, SEE FLOOR FINISH FOR COLOR
FL-6	POLISHED CONCRETE FLOOR FINISH
LT-1	2'x4' RECESSED TROFFER
PT-1	PAINT #1, PRIMARY WALL COLOR SW6539
PT-2a	PAINT #2a, SECONDARY WALL COLOR SW6437, TO PAIR W/ PAINT #3a
S-10	SLIDING STORAGE SYSTEM ON RAILS, 5 RACKS
S-13	ABOVE DESK OPEN STORAGE SHELVES
T-18	120V WALL MOUNTED QUAD POWER OUTLET-WHITE
T-20	CARD READER FOR SECURE ACCESS
T-21	WALL MOUNTED DATA OUTLET



United States Department of Agriculture
Forest Service

R-08

Southern Region

PROJECT NAME:
R-08 SOUTHERN REGION OFFICE SPACE TOOLS & TEMPLATES

UNITED STATES DEPARTMENT OF AGRICULTURE
FOREST SERVICE

SOUTHERN REGION (R8)
1720 PEACHTREE ROAD, NW
ATLANTA, GA. 30309

DRAWING TITLE
IT SHOP

DATE
05/24/19

ARCHIVE NUMBER:

DESIGNER:
Designer

DWG SHEET NO:
A116

DRAWN BY:
Author

CHECKED BY:
Checker

PROJECT NO:
12432P18D0002

SHEET XXX OF XXX



KEYNOTE LEGEND	
CL-1	2X2 ACOUSTIC CEILING TILE, ASTM E1264, FORM 2, PATTERN E, FIRE CLASS A. DUCTED RETURNS ONLY.
LT-2	6" DIAMETER RECESSED LED CAN
LT-6	LARGE 3'-0" DIA. PENDANT
LT-7	SURFACE MOUNTED ADJUSTABLE TRACK LIGHT FIXTURE
LT-9	SPECIALITY PENDANT LIGHT FIXTURE
T-10	FLOOR MOUNTED AUDIO VISUAL INTERFACE CONNECTION
T-17	120V WALL MOUNTED DUPLEX POWER OUTLET-WHITE
T-19	120V WALL MOUNTED DUPLEX POWER OUTLET W/ GROUND FAULT INTERRUPT (GFI)-WHITE
T-21	WALL MOUNTED DATA OUTLET

PARTITION NOTES:
 1. ALL ROOMS LARGER THAN 500SF, OR SECURED ROOMS, TO HAVE DECK TO DECK PARTITIONS.



United States Department of Agriculture
Forest Service

R-08

Southern Region

PROJECT NAME:

R-08 SOUTHERN REGION OFFICE SPACE TOOLS & TEMPLATES

UNITED STATES DEPARTMENT OF AGRICULTURE
FOREST SERVICE

SOUTHERN REGION (R8)
1720 PEACHTREE ROAD, NW
ATLANTA, GA. 30309

DRAWING TITLE

CAFE

DATE

05/24/19

ARCHIVE NUMBER:

DESIGNER:

Designer

DWG SHEET NO.:

A117

DRAWN BY:

Author

CHECKED BY:


Checker

PROJECT NO.:


12432P18D0002

SHEET XXX OF XXX


1 CAFE 30' - 0"

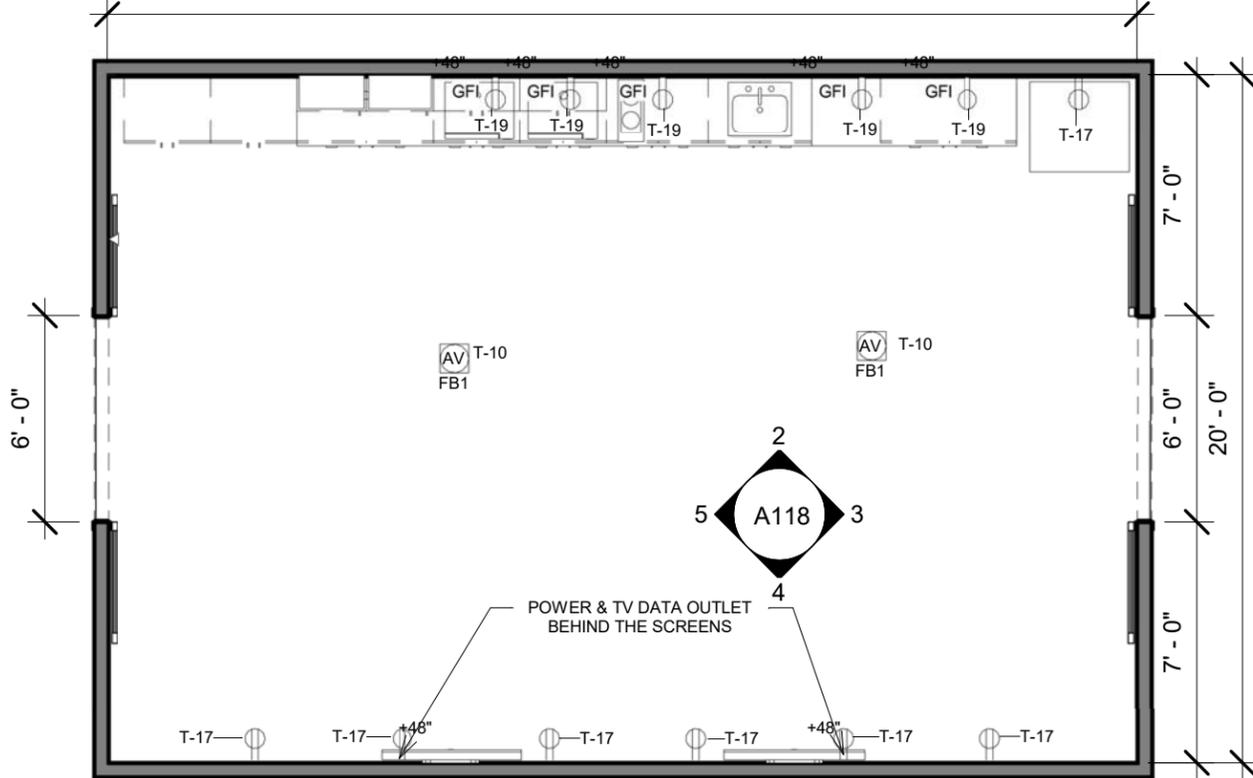


2 CAFE 3/16" = 1'-0"

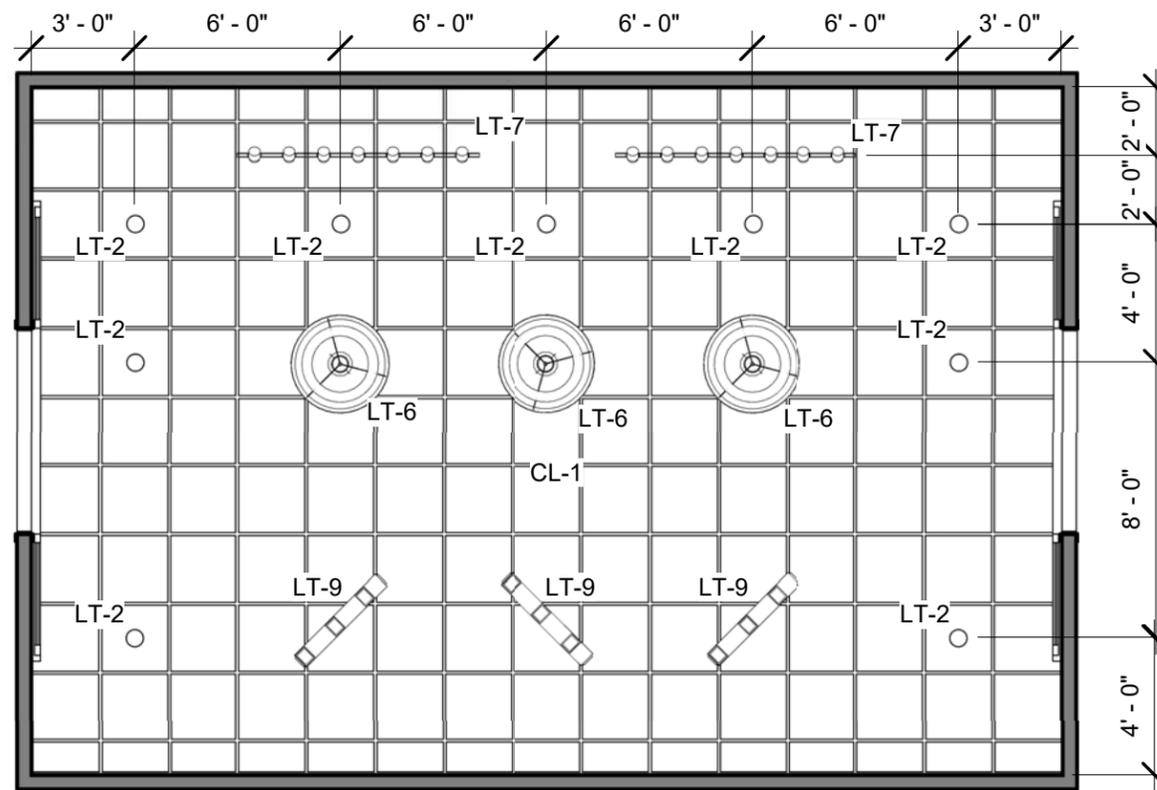

3 CAFE RCP 3/16" = 1'-0"

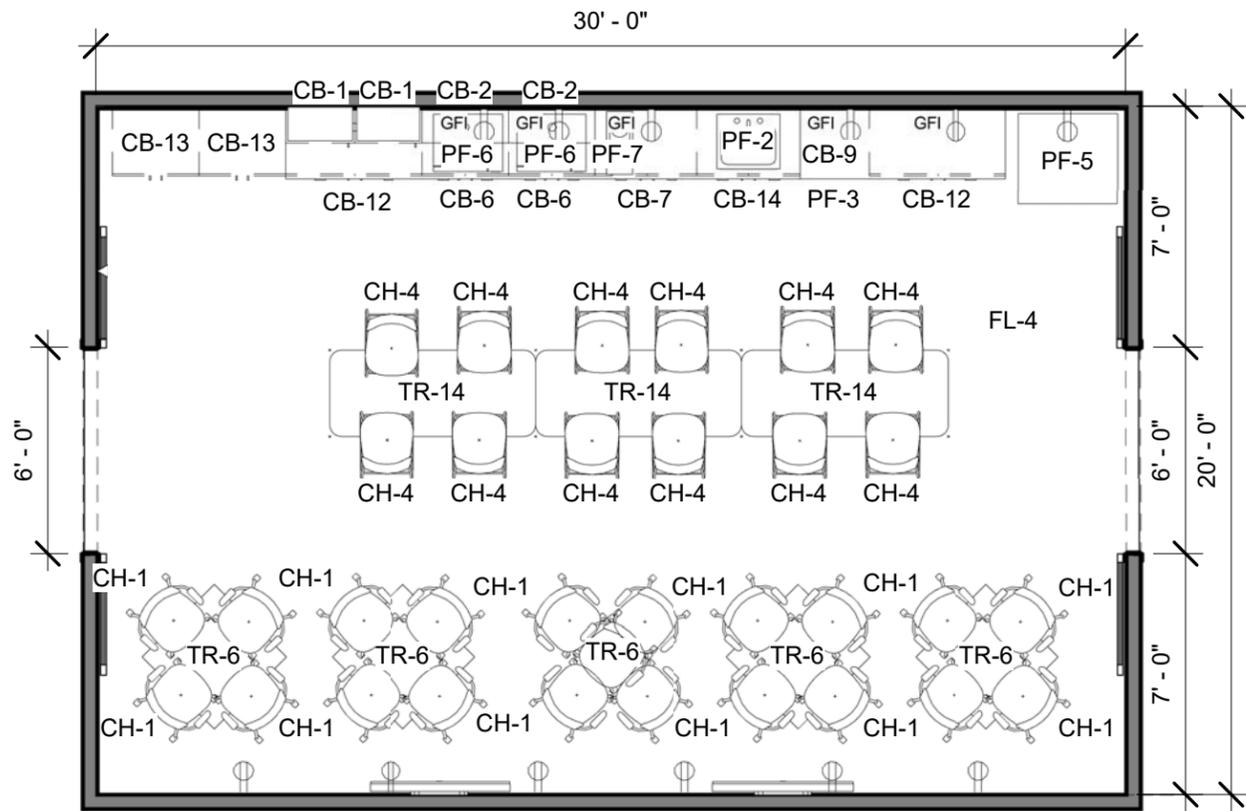


1 CAFE FURNITURE
3/16" = 1'-0"

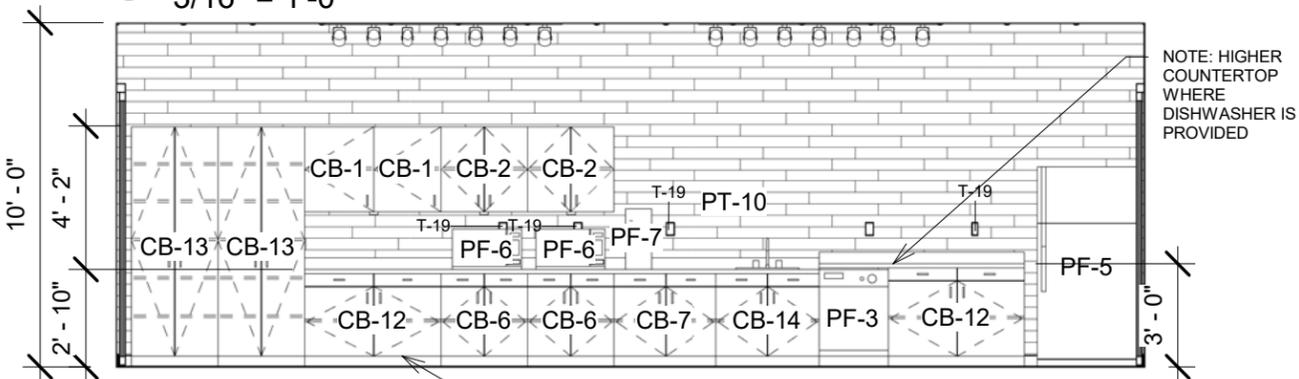


2 CAFE ELEV. 1
3/16" = 1'-0"


NOTE: CUSTOM CABINETRY FOR TRASH & RECYCLE RECEPTACLES PER FOREST SERVICE

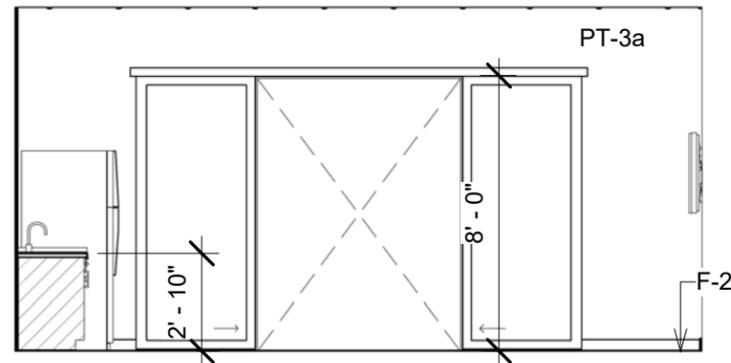

3 CAFE ELEV. 2
3/16" = 1'-0"

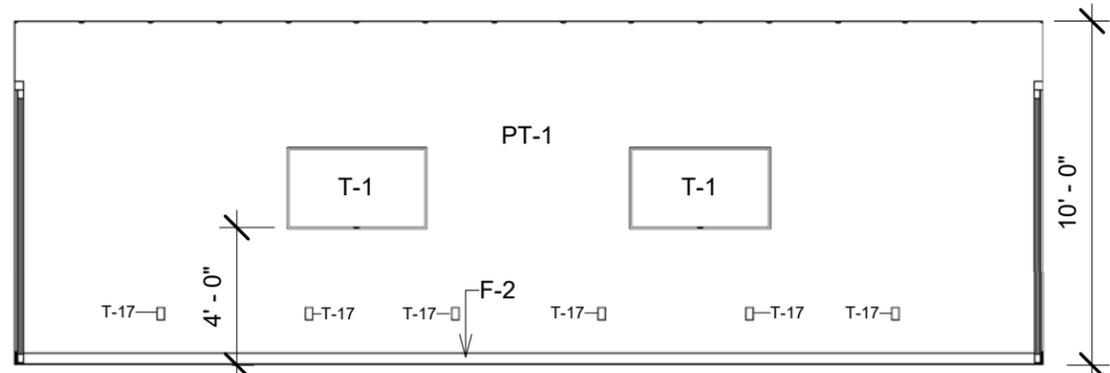

4 CAFE ELEV. 3
3/16" = 1'-0"

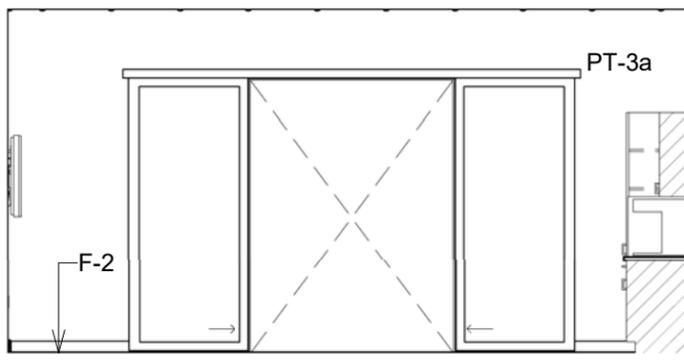

5 CAFE ELEV. 4
3/16" = 1'-0"

KEYNOTE LEGEND	
CB-1	24" MODULAR CASEWORK UPPER SINGLE DOOR CABINET 36"T
CB-2	30" MODULAR CASEWORK UPPER DOUBLE DOOR CABINET 36"T
CB-6	30" MODULAR CASEWORK BASE CABINET, DOUBLE DRAWERS & DOORS
CB-7	36" MODULAR CASEWORK BASE CABINET, DOUBLE DRAWERS & DOORS
CB-9	COUNTERTOP, 24" DEEP
CB-12	48" MODULAR CASEWORK DOUBLE DOOR BASE CABINET
CB-13	24"D x 30"W x 72"H SHELVED CABINETRY
CB-14	36" MODULAR CASEWORK DOUBLE DOOR BASE SINK CABINET
CH-1	STACKABLE HIGHBACK TASK CHAIR
CH-4	HIGH TOP CAFÉ CHAIR W/ MESH SEAT, ARMLESS, NO CASTERS
F-2	VINYL WALL BASE, SEE FLOOR FINISH FOR COLOR
FL-4	LUXURY VINYL TILE (LVT)
PF-2	KITCHEN GRADE SINK
PF-3	KITCHEN DISHWASHER
PF-5	KITCHEN REFRIGERATOR
PF-6	KITCHEN MICROWAVE
PF-7	COFFEE MAKER
PT-1	PAINT #1, PRIMARY WALL COLOR SW6539
PT-3a	PAINT #3a, SECONDARY WALL COLOR SW6439, TO PAIR W/ PAINT #2a
PT-10	WALL TILE W/ WOOD GRAIN PATTERN FOR COLOR OPTION 2 & DECO PATTERN FOR COLOR OPTION 2
T-1	FLAT PANEL DISPLAY MONITOR W/ SPEAKERS AS REQUIRED
T-17	120V WALL MOUNTED DUPLEX POWER OUTLET-WHITE
T-19	120V WALL MOUNTED DUPLEX POWER OUTLET W/ GROUND FAULT INTERRUPT (GFI)-WHITE
TR-6	36"x36" SQUARE TABLE
TR-14	30"Dx72"W HIGHTOP TABLE



United States Department of Agriculture
Forest Service

R-08

Southern Region

PROJECT NAME:

R-08 SOUTHERN REGION OFFICE SPACE TOOLS & TEMPLATES

UNITED STATES DEPARTMENT OF AGRICULTURE FOREST SERVICE

SOUTHERN REGION (R8)
1720 PEACHTREE ROAD, NW
ATLANTA, GA. 30309

DRAWING TITLE

CAFE

DATE
05/24/19

ARCHIVE NUMBER:

DESIGNER:
Designer

DWG SHEET NO:


A118

DRAWN BY:
Author


CHECKED BY:
Checker

PROJECT NO:
12432P18D0002


SHEET XXX OF XXX

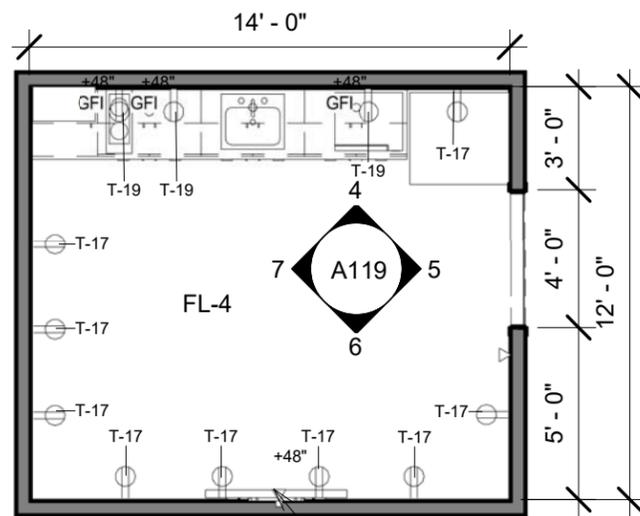

1 BREAK
3/16" = 1'-0"

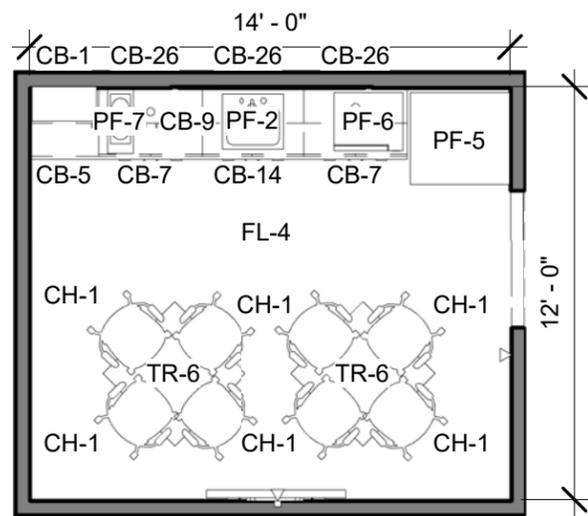

2 BREAK FURNITURE
3/16" = 1'-0"

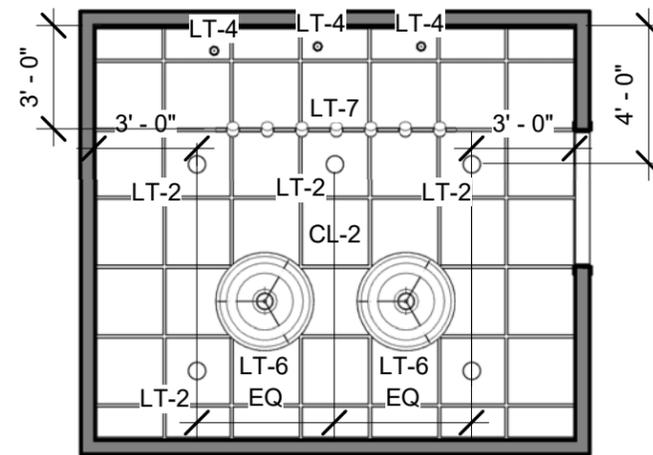

3 BREAK RCP
3/16" = 1'-0"

KEYNOTE LEGEND	
CB-1	24" MODULAR CASEWORK UPPER SINGLE DOOR CABINET 36"T
CB-5	24" MODULAR CASEWORK BASE CABINET, SINGLE DRAWER & DOOR
CB-7	36" MODULAR CASEWORK BASE CABINET, DOUBLE DRAWERS & DOORS
CB-9	COUNTERTOP, 24" DEEP
CB-14	36" MODULAR CASEWORK DOUBLE DOOR BASE SINK CABINET
CB-26	36" MODULAR CASEWORK UPPER WALL CABINET 24"T
CH-1	STACKABLE HIGHBACK TASK CHAIR
CL-2	GYPSUM CEILING BOARD - PAINT TO MATCH PT-1. DUCTED RETURNS ONLY.
F-2	VINYL WALL BASE, SEE FLOOR FINISH FOR COLOR
FL-4	LUXURY VINYL TILE (LVT)
LT-2	6" DIAMETER RECESSED LED CAN
LT-6	LARGE 3'-0" DIA. PENDANT
LT-7	SURFACE MOUNTED ADJUSTABLE TRACK LIGHT FIXTURE
PF-2	KITCHEN GRADE SINK
PF-5	KITCHEN REFRIGERATOR
PF-6	KITCHEN MICROWAVE
PF-7	COFFEE MAKER
PT-1	PAINT #1, PRIMARY WALL COLOR SW6539
PT-3a	PAINT #3a, SECONDARY WALL COLOR SW6439, TO PAIR W/ PAINT #2a
PT-10	WALL TILE W/ WOOD GRAIN PATTERN FOR COLOR OPTION 2 & DECO PATTERN FOR COLOR OPTION 2
T-1	FLAT PANEL DISPLAY MONITOR W/ SPEAKERS AS REQUIRED
T-17	120V WALL MOUNTED DUPLEX POWER OUTLET-WHITE
T-19	120V WALL MOUNTED DUPLEX POWER OUTLET W/ GROUND FAULT INTERRUPT (GFI)-WHITE
TR-6	36"x36" SQUARE TABLE



United States Department of Agriculture
Forest Service


R-08

Southern Region


PROJECT NAME:
R-08 SOUTHERN REGION OFFICE SPACE TOOLS & TEMPLATES

UNITED STATES DEPARTMENT OF AGRICULTURE
FOREST SERVICE


SOUTHERN REGION (R8)
1720 PEACHTREE ROAD, NW
ATLANTA, GA. 30309

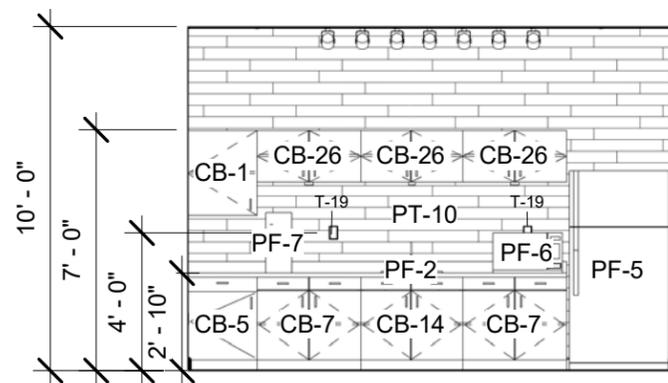


4 BREAK ELEV. 1
3/16" = 1'-0"

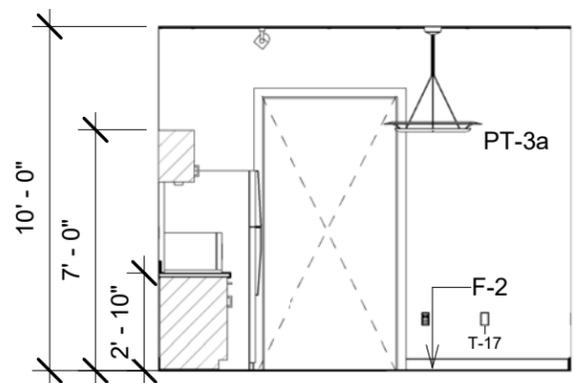

5 BREAK ELEV. 2
3/16" = 1'-0"

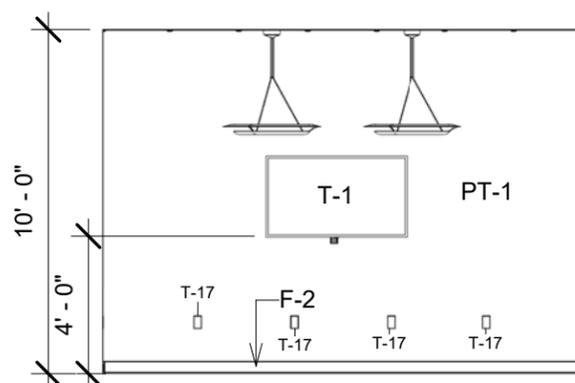

6 BREAK ELEV. 3
3/16" = 1'-0"

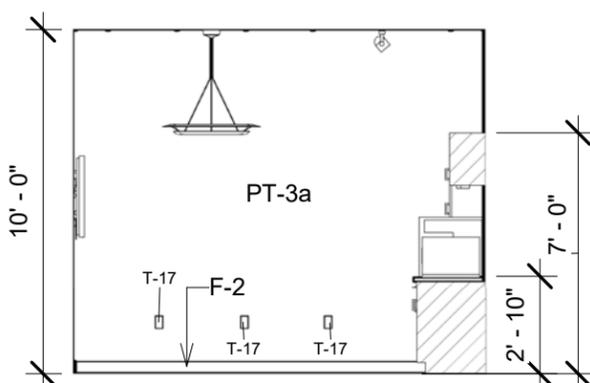

7 BREAK ELEV. 4
3/16" = 1'-0"



8 BREAK

DRAWING TITLE
BREAK

DATE
05/24/19

ARCHIVE NUMBER:

DESIGNER:
Designer

DWG SHEET NO:
A119

DRAWN BY:
Author


CHECKED BY:
Checker

PROJECT NO:
12432P18D0002


SHEET XXX OF XXX




1 PANTRY

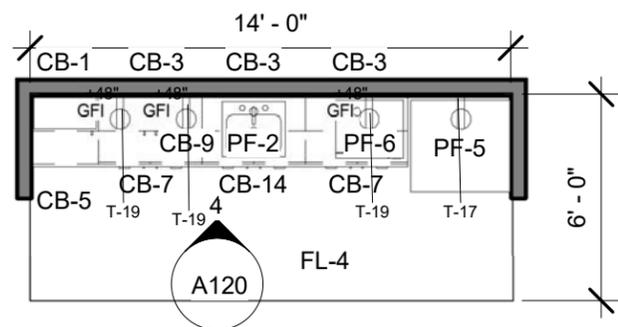

2 PANTRY
3/16" = 1'-0"

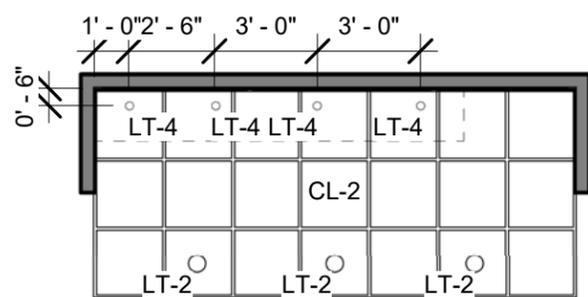

3 PANTRY RCP
3/16" = 1'-0"

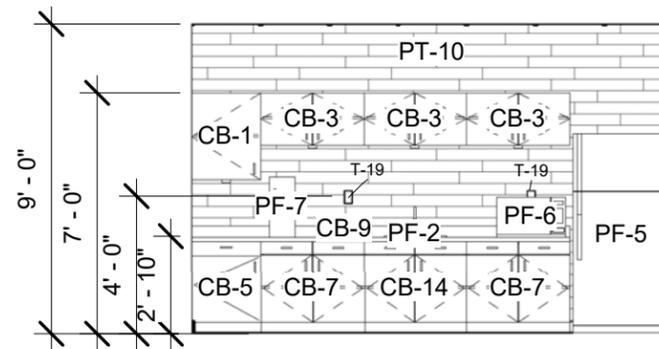

4 PANTRY ELEV. 1
3/16" = 1'-0"

KEYNOTE LEGEND

CB-1	24" MODULAR CASEWORK UPPER SINGLE DOOR CABINET 36"T
CB-3	36" MODULAR CASEWORK UPPER DOUBLE DOOR CABINET 36"T
CB-5	24" MODULAR CASEWORK BASE CABINET, SINGLE DRAWER & DOOR
CB-7	36" MODULAR CASEWORK BASE CABINET, DOUBLE DRAWERS & DOORS
CB-9	COUNTERTOP, 24" DEEP
CB-14	36" MODULAR CASEWORK DOUBLE DOOR BASE SINK CABINET
CL-2	GYPSUM CEILING BOARD - PAINT TO MATCH PT-1. DUCTED RETURNS ONLY.
FL-4	LUXURY VINYL TILE (LVT)
LT-2	6" DIAMETER RECESSED LED CAN
LT-4	OVERHEAD CABINET UNDERMOUNT LIGHT PUCK
PF-2	KITCHEN GRADE SINK
PF-5	KITCHEN REFRIGERATOR
PF-6	KITCHEN MICROWAVE
PF-7	COFFEE MAKER
PT-10	WALL TILE W/ WOOD GRAIN PATTERN FOR COLOR OPTION 2 & DECO PATTERN FOR COLOR OPTION 2
T-17	120V WALL MOUNTED DUPLEX POWER OUTLET-WHITE
T-19	120V WALL MOUNTED DUPLEX POWER OUTLET W/ GROUND FAULT INTERRUPT (GFI)-WHITE



United States Department of Agriculture
Forest Service

R-08
Southern Region

PROJECT NAME:

R-08 SOUTHERN REGION OFFICE SPACE TOOLS & TEMPLATES

UNITED STATES DEPARTMENT OF AGRICULTURE
FOREST SERVICE

SOUTHERN REGION (R8)
1720 PEACHTREE ROAD, NW
ATLANTA, GA. 30309

DRAWING TITLE

PANTRY

DATE
05/24/19

ARCHIVE NUMBER:

DESIGNER:
Designer

DWG SHEET NO:


A120

DRAWN BY:
Author


CHECKED BY:
Checker

PROJECT NO:
12432P18D0002


SHEET XXX OF XXX

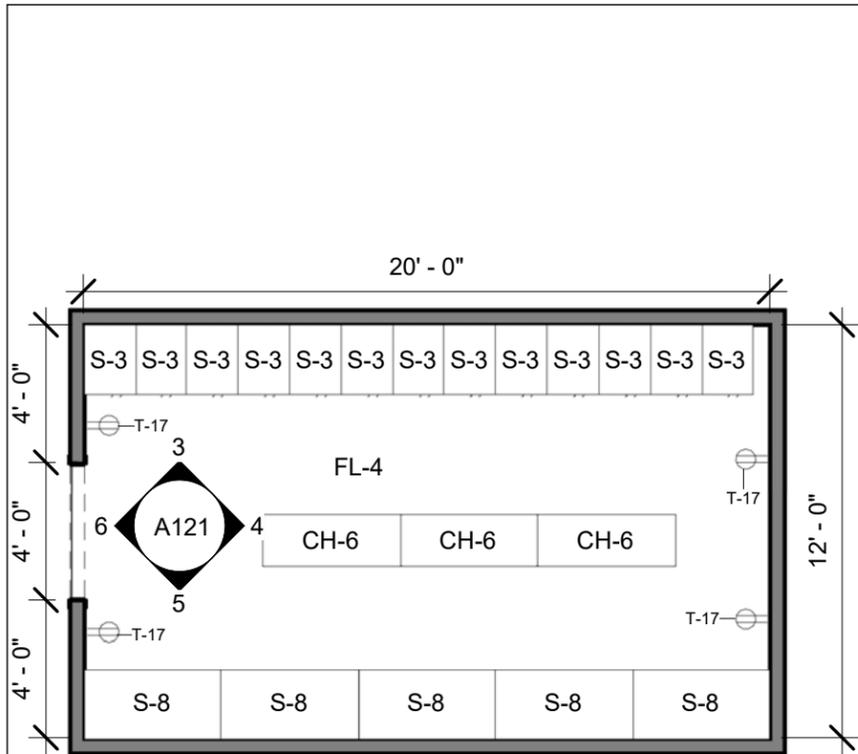


1 MUDROOM A
3/16" = 1'-0"

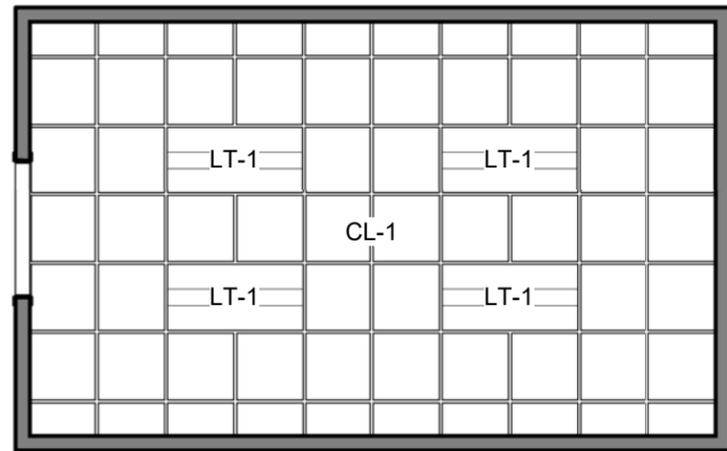


2 MUDROOM A RCP
3/16" = 1'-0"

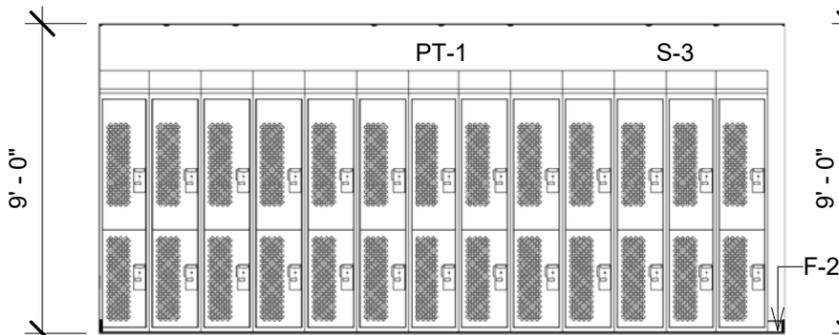


3 MUDROOM A ELEV. 1
3/16" = 1'-0"

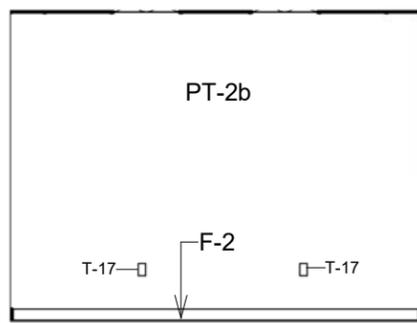

4 MUDROOM A ELEV. 2
3/16" = 1'-0"

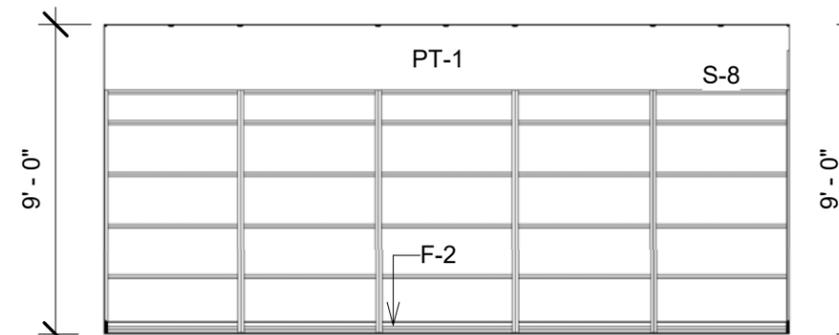

5 MUDROOM A ELEV. 3
3/16" = 1'-0"

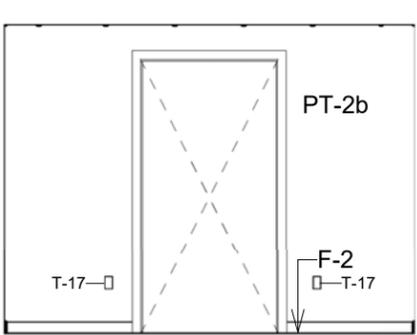

6 MUDROOM A ELEV. 4
3/16" = 1'-0"



KEYNOTE LEGEND	
CH-6	BACKLESS PLASTIC BENCH SEATING 18"x48"
CL-1	2X2 ACCOUSTIC CEILING TILE, ASTM E1264, FORM 2, PATTERN E, FIRE CLASS A, DUCTED RETURNS ONLY.
F-2	VINYL WALL BASE, SEE FLOOR FINISH FOR COLOR
FL-4	LUXURY VINYL TILE (LVT)
LT-1	2'x4' RECESSED TROFFER
PT-1	PAINT #1, PRIMARY WALL COLOR SW6539
PT-2b	PAINT #2b, SECONDARY WALL COLOR SW6379, TO PAIR W/ PAINT #3b
S-3	LOCKER
S-8	OPEN STORAGE UNIT
T-17	120V WALL MOUNTED DUPLEX POWER OUTLET-WHITE

United States Department of Agriculture
Forest Service

R-08

Southern Region

PROJECT NAME:
*R-08 SOUTHERN
REGION OFFICE
SPACE TOOLS &
TEMPLATES*

UNITED STATES
DEPARTMENT OF
AGRICULTURE
FOREST SERVICE

SOUTHERN REGION (R8)
1720 PEACHTREE ROAD, NW
ATLANTA, GA. 30309

DRAWING TITLE:
MUDROOM A

DATE:
05/24/19

ARCHIVE NUMBER:

DESIGNER:
Designer


DWG SHEET NO:
A121

DRAWN BY:
Author


CHECKED BY:
Checker

PROJECT NO:
12432P18D0002


SHEET XXX OF XXX

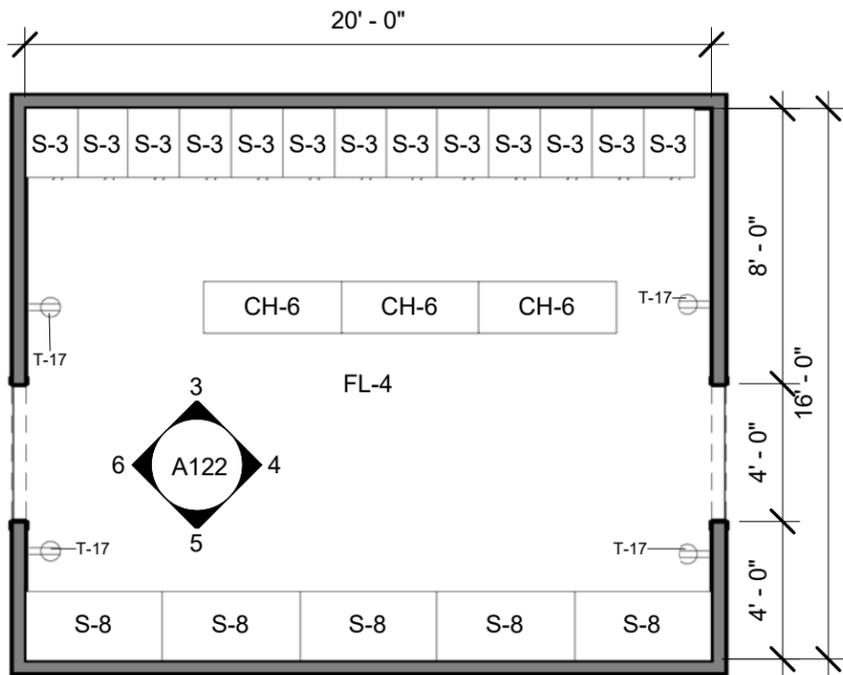


① MUDROOM B
3/16" = 1'-0"

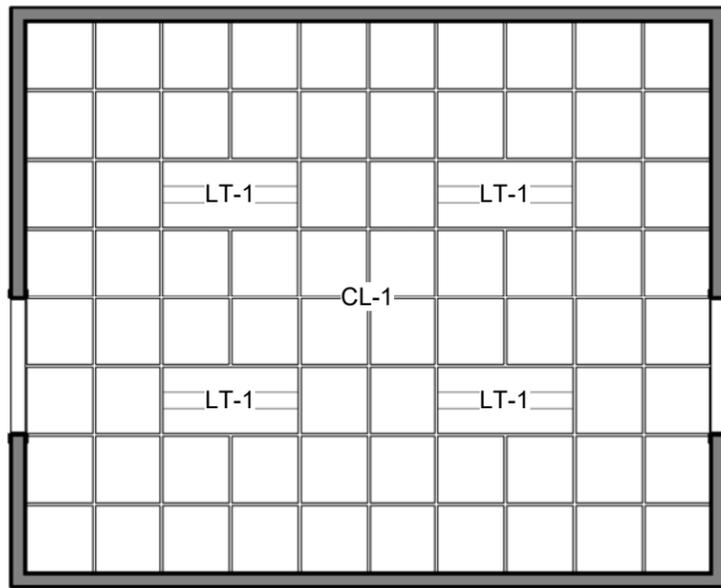


② MUDROOM B RCP
3/16" = 1'-0"

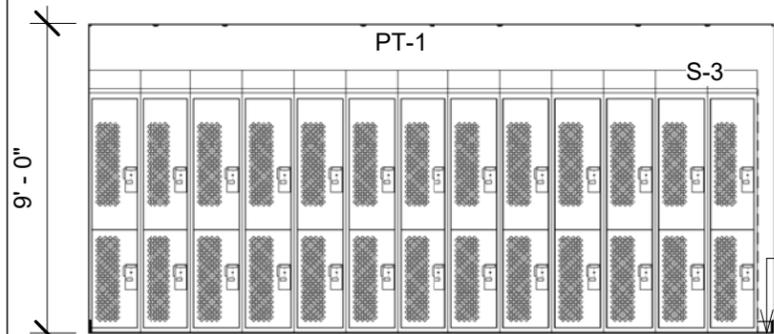


③ MUDROOM B ELEV. 1
3/16" = 1'-0"

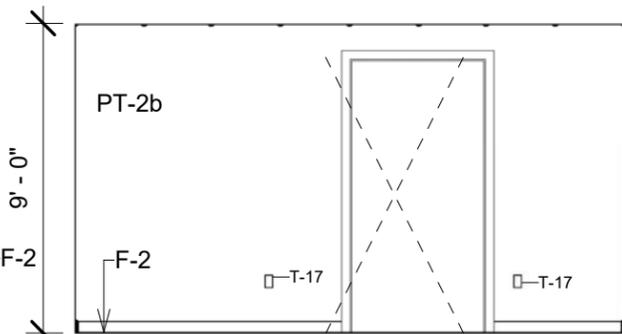

④ MUDROOM B ELEV. 2
3/16" = 1'-0"

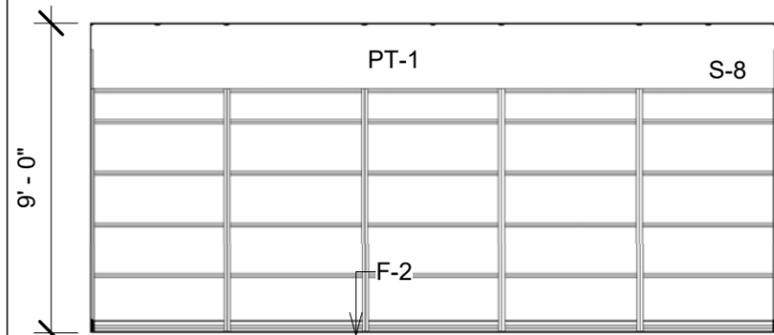

⑤ MUDROOM B ELEV. 3
3/16" = 1'-0"

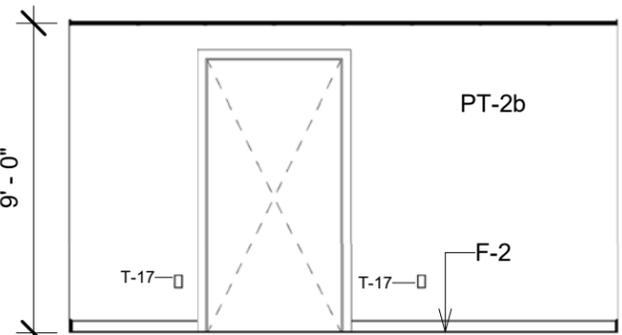

⑥ MUDROOM B ELEV. 4
3/16" = 1'-0"



⑦ MUDROOM B

KEYNOTE LEGEND	
CH-6	BACKLESS PLASTIC BENCH SEATING 18"X48"
CL-1	2X2 ACOUSTIC CEILING TILE, ASTM E1264, FORM 2, PATTERN E, FIRE CLASS A, DUCTED RETURNS ONLY.
F-2	VINYL WALL BASE, SEE FLOOR FINISH FOR COLOR
FL-4	LUXURY VINYL TILE (LVT)
LT-1	2'x4' RECESSED TROFFER
PT-1	PAINT #1, PRIMARY WALL COLOR SW6539
PT-2b	PAINT #2b, SECONDARY WALL COLOR SW6379, TO PAIR W/ PAINT #3b
S-3	LOCKER
S-8	OPEN STORAGE UNIT
T-17	120V WALL MOUNTED DUPLEX POWER OUTLET-WHITE



United States Department of Agriculture
Forest Service

R-08

Southern Region

PROJECT NAME:

R-08 SOUTHERN
REGION OFFICE
SPACE TOOLS &
TEMPLATES

UNITED STATES
DEPARTMENT OF
AGRICULTURE
FOREST SERVICE

SOUTHERN REGION (R8)
1720 PEACHTREE ROAD, NW
ATLANTA, GA. 30309

DRAWING TITLE

MUDROOM B

DATE
05/24/19

ARCHIVE NUMBER:

DESIGNER:
Designer

DWG SHEET NO.:







A122

DRAWN BY:
Author

CHECKED BY:
Checker

PROJECT NO:
12432P18D0002

SHEET XXX OF XXX

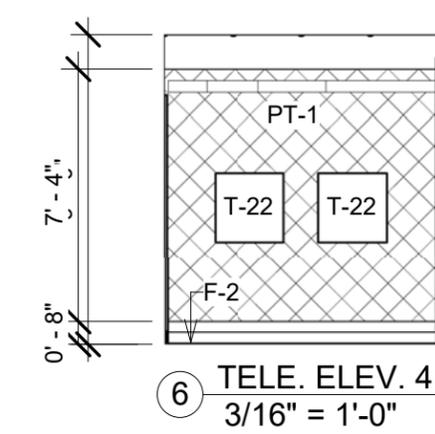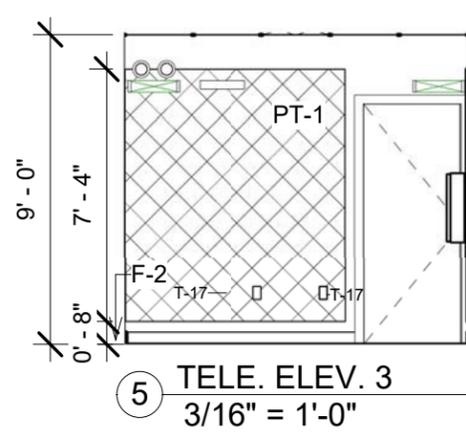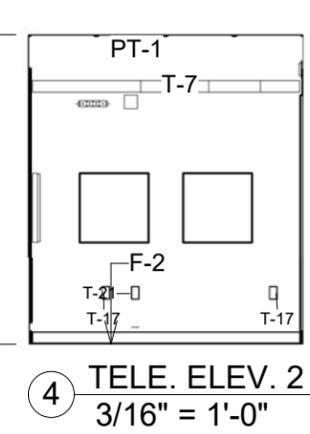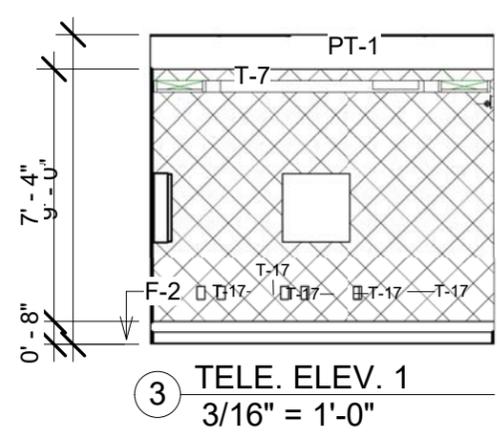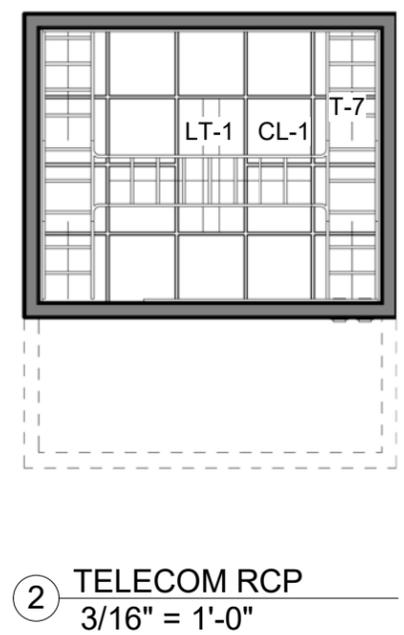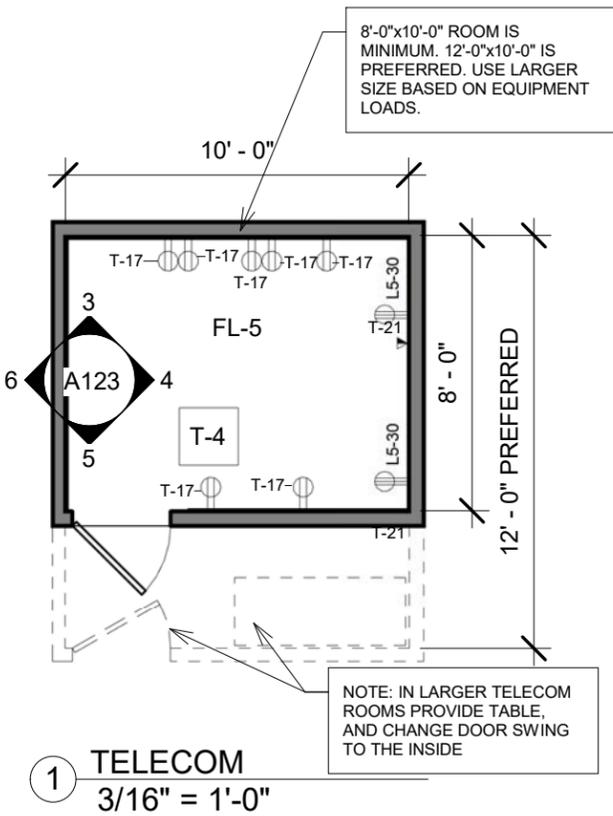

KEYNOTE LEGEND	
CL-1	2X2 ACCOUSTIC CEILING TILE, ASTM E1264, FORM 2, PATTERN E, FIRE CLASS A. DUCTED RETURNS ONLY.
F-2	VINYL WALL BASE, SEE FLOOR FINISH FOR COLOR
FL-5	VINYTL COMPOSITE TILE (VCT)
LT-1	2'x4' RECESSED TROFFER
PT-1	PAINT #1, PRIMARY WALL COLOR SW6539
T-4	TELECOM SERVER RACK/EQUIPMENT
T-7	CABLE TRAYS - SUSPENDED FROM CEILING
T-17	120V WALL MOUNTED DUPLEX POWER OUTLET-WHITE
T-20	CARD READER FOR SECURE ACCESS
T-21	WALL MOUNTED DATA OUTLET
T-22	WALL MOUNTED CAT 5 FIELD

United States Department of Agriculture
Forest Service

R-08

Southern Region


PROJECT NAME:
R-08 SOUTHERN REGION OFFICE SPACE TOOLS & TEMPLATES

UNITED STATES DEPARTMENT OF AGRICULTURE
FOREST SERVICE


SOUTHERN REGION (R8)
1720 PEACHTREE ROAD, NW
ATLANTA, GA. 30309

DRAWING TITLE:
TELECOM


DATE: 05/24/19	
ARCHIVE NUMBER:	
DESIGNER: Designer	DWG SHEET NO: A123
DRAWN BY: Author	
CHECKED BY: Checker	
PROJECT NO: 12432P18D0002	SHEET XXX OF XXX

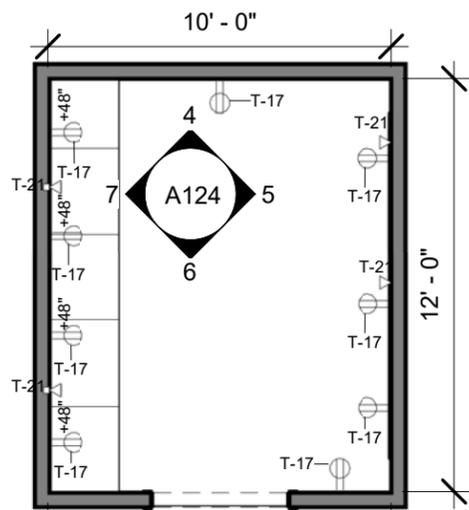


1 OFFICE SERVICES A
3/16" = 1'-0"

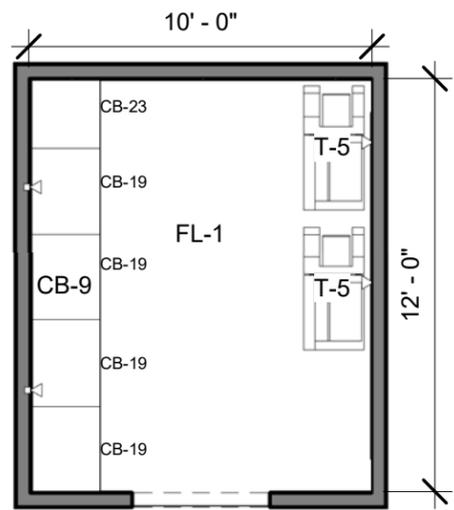


2 OFFICE SERVICES A FURNITURE
3/16" = 1'-0"

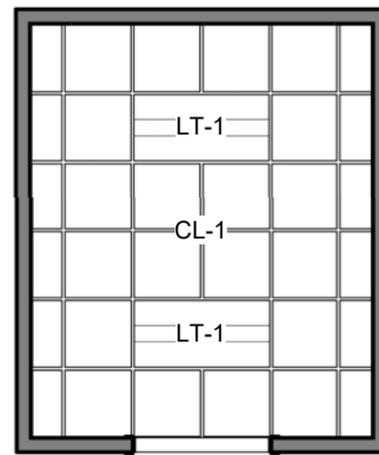


3 OFFICE SERVICES A RCP
3/16" = 1'-0"

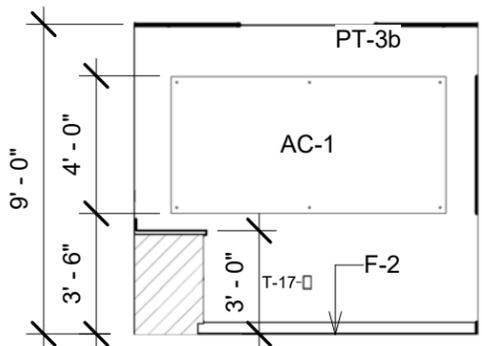


4 OFF. SER. A ELEV. 1
3/16" = 1'-0"

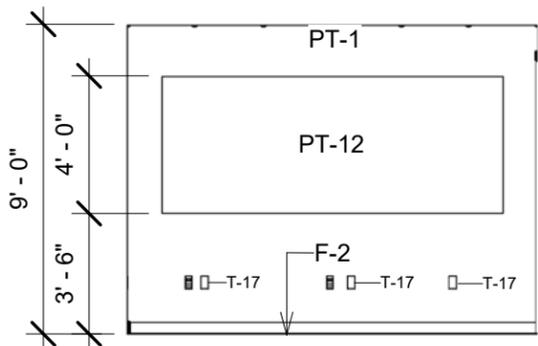

5 OFF. SER. A ELEV. 2
3/16" = 1'-0"

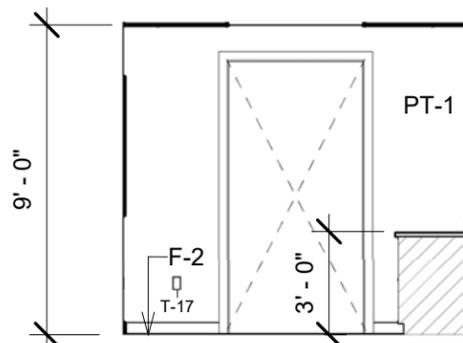

6 OFF. SER. A ELEV. 3
3/16" = 1'-0"

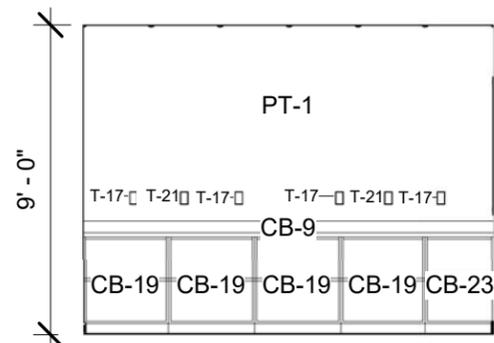

7 OFF. SER. A ELEV. 4
3/16" = 1'-0"



8 OFF SERVICES A

KEYNOTE LEGEND

AC-1	BACK PAINTED WRITABLE GLASS MARKERBOARD-CLARIDGE GLASS MARKERBOARD BRILLIANT WHITE OR EQUAL
CB-9	COUNTERTOP, 24" DEEP
CB-19	30" MODULAR OPEN BASE CABINETS W/ 2 OPEN SHELVES
CB-23	24" MODULAR OPEN BASE CABINETS W/ 2 SHELVES
CL-1	2X2 ACCOUSTIC CEILING TILE, ASTM E1264, FORM 2, PATTERN E, FIRE CLASS A. DUCTED RETURNS ONLY.
F-2	VINYL WALL BASE, SEE FLOOR FINISH FOR COLOR
FL-1	MODULAR CARPET TILE
LT-1	2'x4' RECESSED TROFFER
PT-1	PAINT #1, PRIMARY WALL COLOR SW6539
PT-3b	PAINT #3b, SECONDARY WALL COLOR SW7072, TO PAIR W/ PAINT #2b
PT-12	TACKABLE ACCOUSTICAL WALL PANEL
T-5	COPIER PRINTER
T-17	120V WALL MOUNTED DUPLEX POWER OUTLET-WHITE
T-21	WALL MOUNTED DATA OUTLET



United States Department of Agriculture
Forest Service

R-08
Southern Region

PROJECT NAME:

R-08 SOUTHERN REGION OFFICE SPACE TOOLS & TEMPLATES

UNITED STATES DEPARTMENT OF AGRICULTURE FOREST SERVICE

SOUTHERN REGION (R8)
1720 PEACHTREE ROAD, NW
ATLANTA, GA. 30309

DRAWING TITLE

OFFICE SERVICES A

DATE

05/24/19

ARCHIVE NUMBER:

DESIGNER:

Designer

DWG SHEET NO.:

A124

DRAWN BY:

Author

CHECKED BY:

Checker

PROJECT NO.:

12432P18D0002

SHEET XXX OF XXX

KEYNOTE LEGEND	
AC-1	BACK PAINTED WRITABLE GLASS MARKERBOARD- CLARIDGE GLASS MARKERBOARD BRILLIANT WHITE OR EQUAL
CB-9	COUNTERTOP, 24" DEEP
CB-19	30" MODULAR OPEN BASE CABINETS W/ 2 OPEN SHELVES
CL-1	2X2 ACCOUSTIC CEILING TILE, ASTM E1264, FORM 2, PATTERN E, FIRE CLASS A. DUCTED RETURNS ONLY.
F-2	VINYL WALL BASE, SEE FLOOR FINISH FOR COLOR
FL-1	MODULAR CARPET TILE
LT-1	2'x4' RECESSED TROFFER
PT-1	PAINT #1, PRIMARY WALL COLOR SW6539
PT-3a	PAINT #3a, SECONDARY WALL COLOR SW6439, TO PAIR W/ PAINT #2a
PT-12	TACKABLE ACCOUSTICAL WALL PANEL
T-5	COPIER PRINTER
T-6	LARGE FORMAT PRINTER
T-17	120V WALL MOUNTED DUPLEX POWER OUTLET-WHITE
T-21	WALL MOUNTED DATA OUTLET



United States Department of Agriculture
Forest Service

R-08

Southern Region

PROJECT NAME:
*R-08 SOUTHERN
REGION OFFICE
SPACE TOOLS &
TEMPLATES*

*UNITED STATES
DEPARTMENT OF
AGRICULTURE
FOREST SERVICE*

SOUTHERN REGION (R8)
1720 PEACHTREE ROAD, NW
ATLANTA, GA. 30309

DRAWING TITLE
*OFFICE SERVICES
B*


DATE
05/24/19

ARCHIVE NUMBER:


DESIGNER: Designer	DWG SHEET NO: A125
DRAWN BY: Author	
CHECKED BY: Checker	

PROJECT NO:
12432P18D0002


SHEET XXX OF XXX

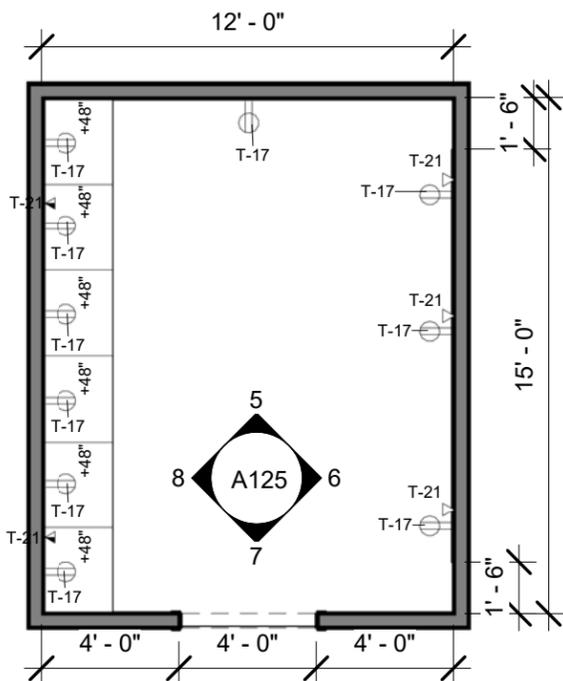

① OFFICE SERVICES B
3/16" = 1'-0"

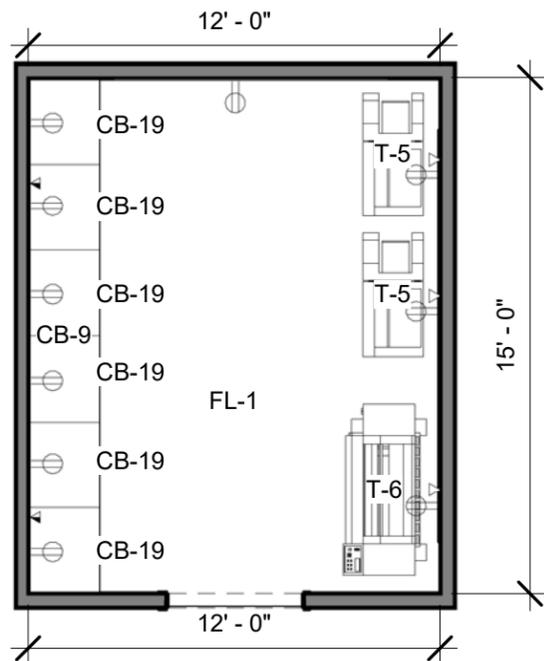


② OFFICE SERVICES B FURNITURE
3/16" = 1'-0"

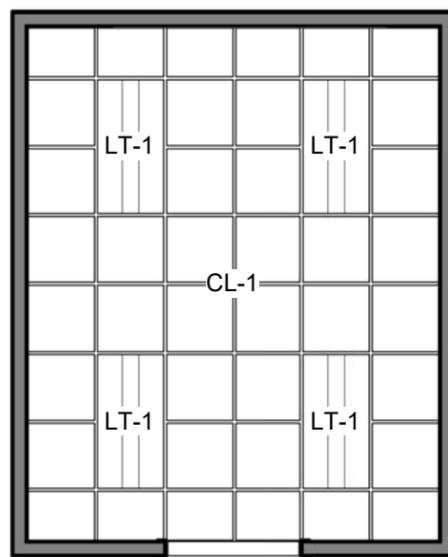


③ OFFICE SERVICES B RCP
3/16" = 1'-0"




④ OFF SERVICES B

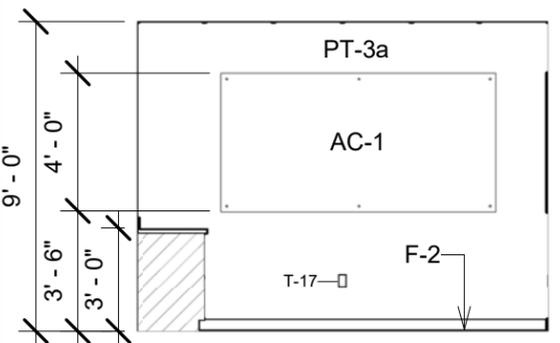


⑤ OFF. SER. B ELEV. 1
3/16" = 1'-0"

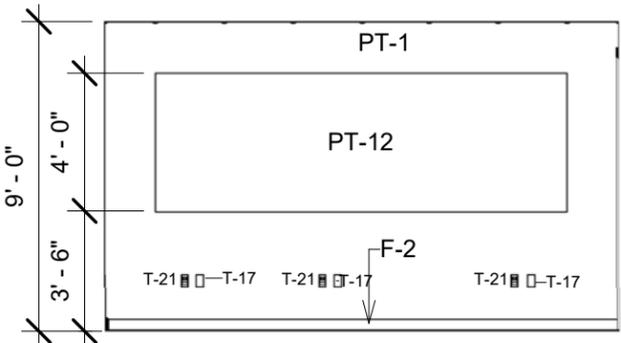


⑥ OFF. SER. B ELEV. 2
3/16" = 1'-0"

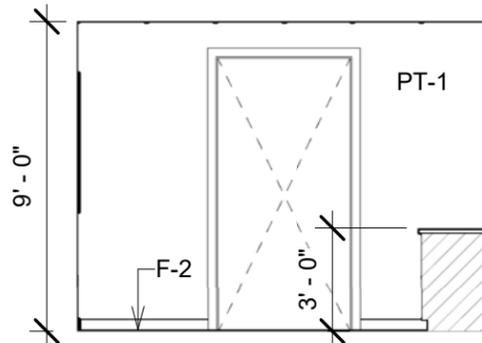

⑦ OFF. SER. B ELEV. 3
3/16" = 1'-0"

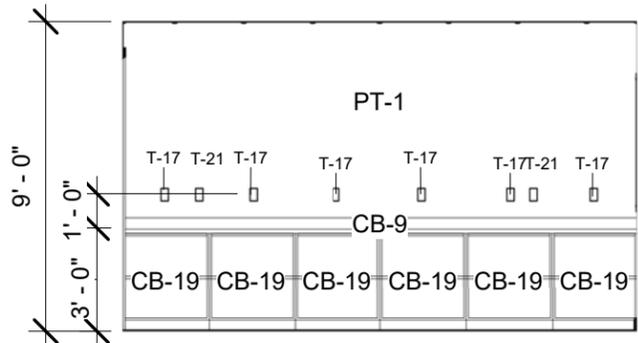


⑧ OFF. SER. B ELEV. 4
3/16" = 1'-0"

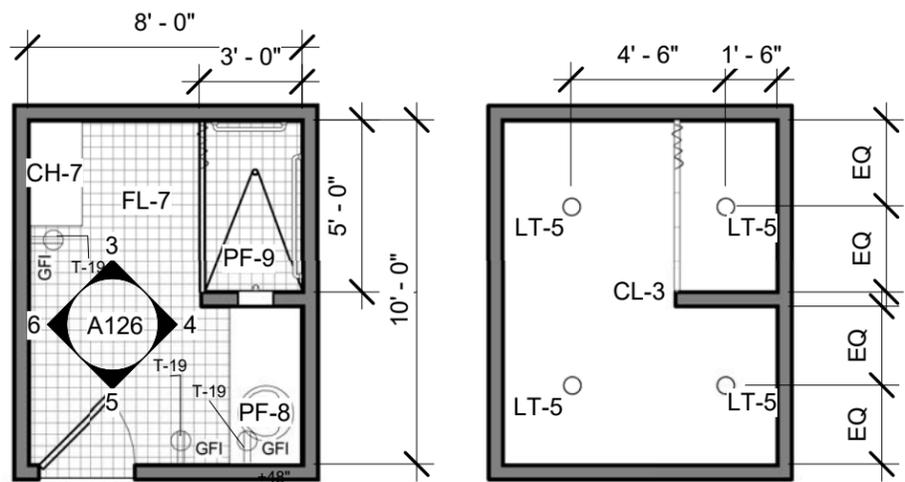


1 SHOWER
3/16" = 1'-0"


2 SHOWER RCP
3/16" = 1'-0"

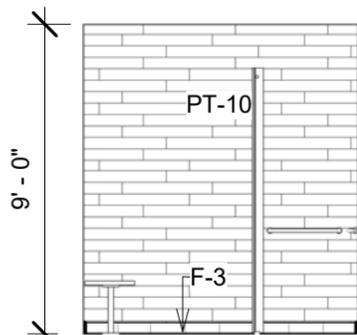


3 SHOWER ELEV. 1
3/16" = 1'-0"

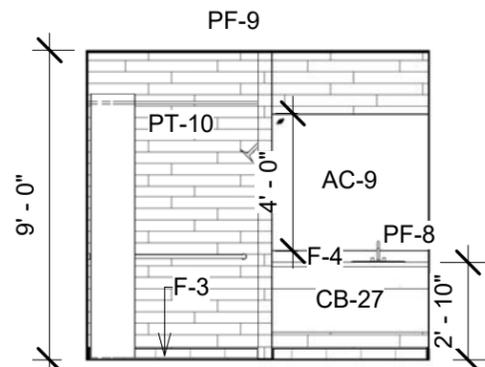

4 SHOWER ELEV. 2
3/16" = 1'-0"

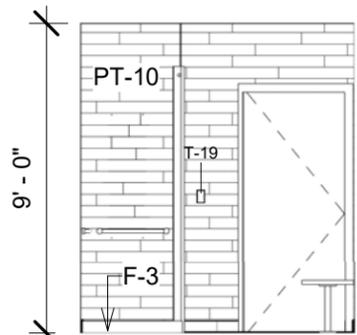

5 SHOWER ELEV. 3
3/16" = 1'-0"

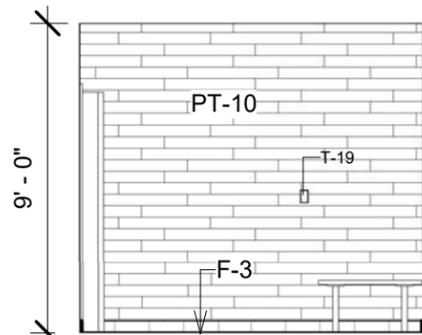

6 SHOWER ELEV. 4
3/16" = 1'-0"



7 SHOWER

KEYNOTE LEGEND

AC-9	MIRROR FULL WIDTH x 48" T
CB-27	BATHROOM UNDER SINK CABINETS W/ KNEE CLEARANCE
CH-7	BACKLESS PLASTIC SLAT BENCH SEATING 18" X 36"
CL-3	MOLD RESISTANT GYPSUM CEILING BOARD - PAINT TO MATCH PT-1.
F-3	CERAMIC COVE TILE BASE
F-4	SOLID SURFACE
FL-7	2" X 2" SLIP RESISTANT TILE MEETING DYNAMIC COEFFICIENT OF FRICTION (DCOF) OF A VALUE OF 0.42 OR LESS FOR WET SURFACES
LT-5	6" DIAMETER RECESSED LED CAN RATED FOR DAMP LOCATIONS
PF-8	VANITY SINK
PF-9	ROLL IN SHOWER W/ GRAB BARS, CURTAIN ROD, SHOWER CURTAIN, & MARBLE THRESHOLD
PT-10	WALL TILE W/ WOOD GRAIN PATTERN FOR COLOR OPTION 2 & DECO PATTERN FOR COLOR OPTION 2
T-19	120V WALL MOUNTED DUPLEX POWER OUTLET W/ GROUND FAULT INTERRUPT (GFI)-WHITE



United States Department of Agriculture
Forest Service

R-08
Southern Region

PROJECT NAME:

R-08 SOUTHERN REGION OFFICE SPACE TOOLS & TEMPLATES

UNITED STATES DEPARTMENT OF AGRICULTURE FOREST SERVICE

SOUTHERN REGION (R8)
1720 PEACHTREE ROAD, NW
ATLANTA, GA. 30309

DRAWING TITLE

SHOWER

DATE

05/24/19

ARCHIVE NUMBER:

DESIGNER:

Designer

DWG SHEET NO.:

A126

DRAWN BY:

Author



CHECKED BY:

Checker

PROJECT NO.:


12432P18D0002

SHEET XXX OF XXX

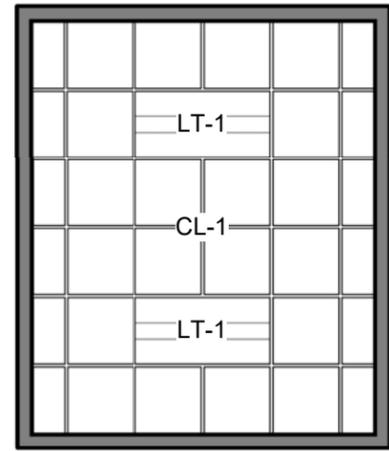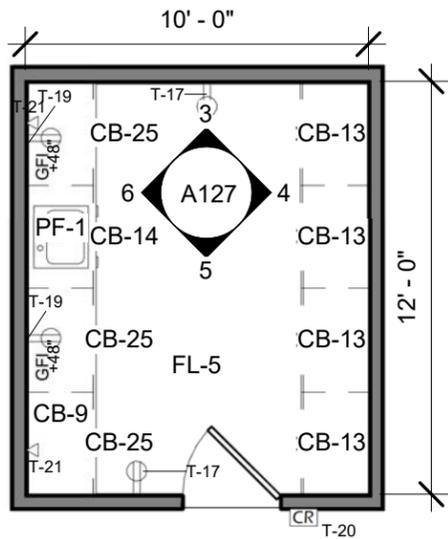


1 STANDARD LAB
3/16" = 1'-0"


2 STANDARD LAB RCP
3/16" = 1'-0"

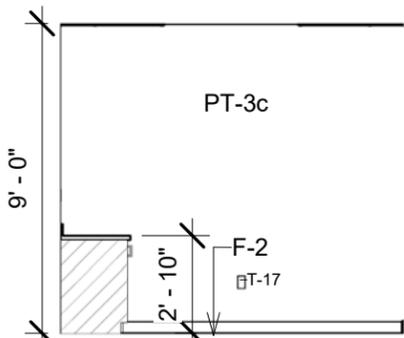


3 S. LAB ELEV. 1
3/16" = 1'-0"

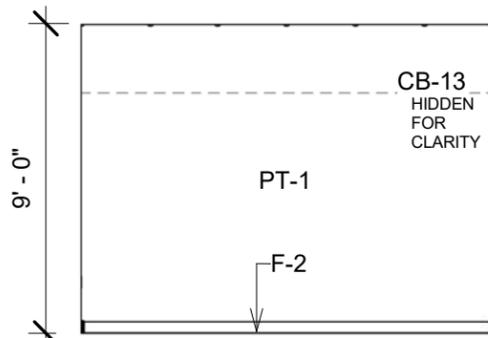

4 S. LAB ELEV. 2
3/16" = 1'-0"

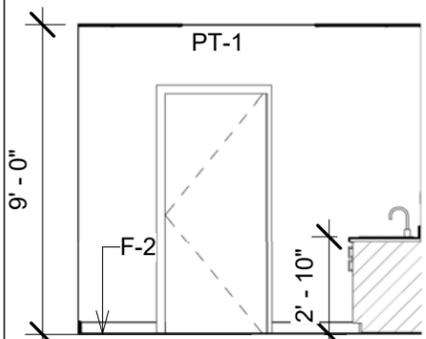

5 S. LAB ELEV. 3
3/16" = 1'-0"

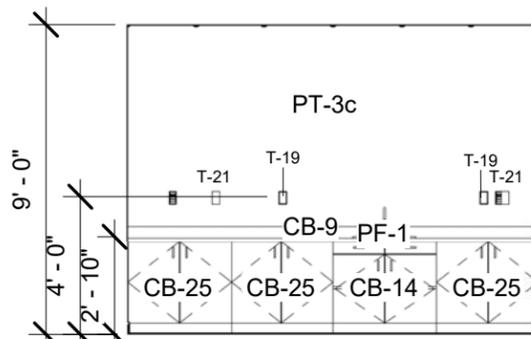

6 S. LAB ELEV. 4
3/16" = 1'-0"



7 STANDARD LAB

KEYNOTE LEGEND	
CB-9	COUNTERTOP, 24" DEEP
CB-13	24"D x 30"W x 72"H SHELVED CABINETRY
CB-14	36" MODULAR CASEWORK DOUBLE DOOR BASE SINK CABINET
CB-25	36" MODULAR CASEWORK BASE CABINET FOR LAB BENCH, FULL HEIGHT DOUBLE DOOR
CL-1	2X2 ACOUSTIC CEILING TILE, ASTM E1264, FORM 2, PATTERN E, FIRE CLASS A. DUCTED RETURNS ONLY.
F-2	VINYL WALL BASE, SEE FLOOR FINISH FOR COLOR
FL-5	VINYL COMPOSITE TILE (VCT)
LT-1	2'x4' RECESSED TROFFER
PF-1	LAB-GRADE SINK
PT-1	PAINT #1, PRIMARY WALL COLOR SW6539
PT-3c	PAINT #3c, SECONDARY WALL COLOR SW6529, TO PAIR W/ PAINT #2c
T-17	120V WALL MOUNTED DUPLEX POWER OUTLET-WHITE
T-19	120V WALL MOUNTED DUPLEX POWER OUTLET W/ GROUND FAULT INTERRUPT (GFI)-WHITE
T-20	CARD READER FOR SECURE ACCESS
T-21	WALL MOUNTED DATA OUTLET



United States Department of Agriculture
Forest Service

R-08

Southern Region

PROJECT NAME:
R-08 SOUTHERN REGION OFFICE SPACE TOOLS & TEMPLATES

UNITED STATES DEPARTMENT OF AGRICULTURE
FOREST SERVICE

SOUTHERN REGION (R8)
1720 PEACHTREE ROAD, NW
ATLANTA, GA. 30309

DRAWING TITLE:
STANDARD LAB

DATE:
05/24/19

ARCHIVE NUMBER:

DESIGNER:
Designer


DWG SHEET NO.:
A127

DRAWN BY:
Author


CHECKED BY:
Checker

PROJECT NO.:
12432P18D0002


SHEET XXX OF XXX

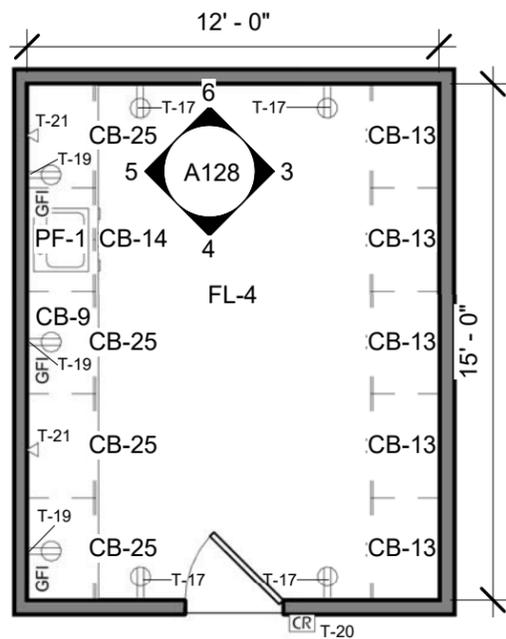


1 LARGE LAB
3/16" = 1'-0"

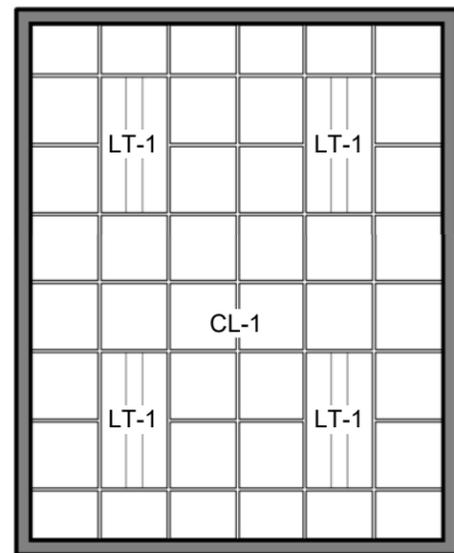


2 LARGE LAB RCP
3/16" = 1'-0"

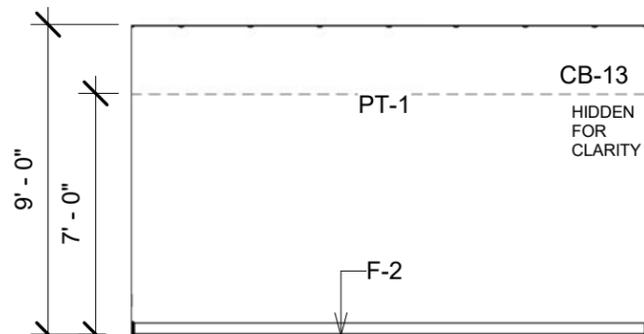


3 L. LAB ELEV. 2
3/16" = 1'-0"

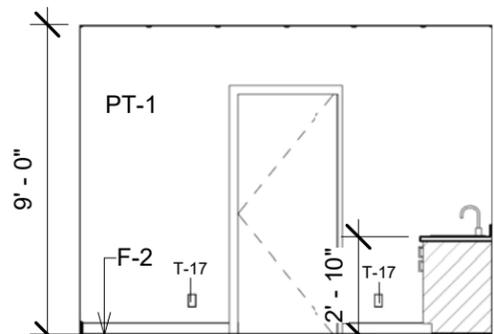

4 L. LAB ELEV. 3
3/16" = 1'-0"

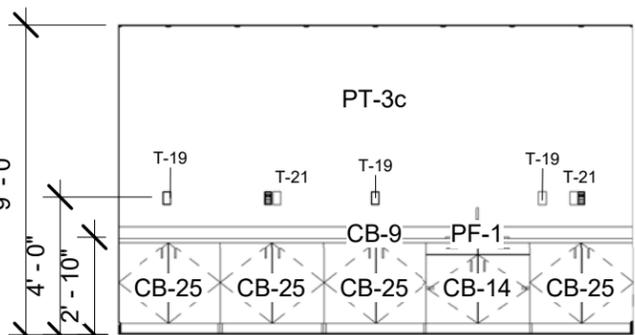

5 L. LAB ELEV. 4
3/16" = 1'-0"

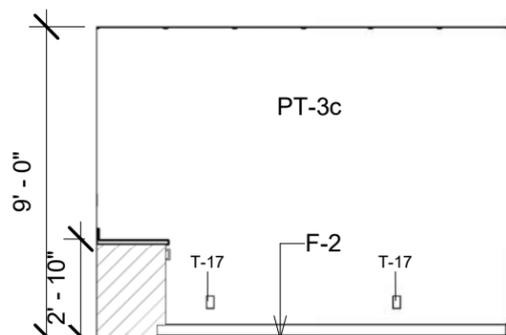

6 L. LAB ELEV. 1
3/16" = 1'-0"



7 LARGE LAB

KEYNOTE LEGEND

CB-9	COUNTERTOP, 24" DEEP
CB-13	24"D x 30"W x 72"H SHELVED CABINETS
CB-14	36" MODULAR CASEWORK DOUBLE DOOR BASE SINK CABINET
CB-25	36" MODULAR CASEWORK BASE CABINET FOR LAB BENCH, FULL HEIGHT DOUBLE DOOR
CL-1	2X2 ACCOUSTIC CEILING TILE, ASTM E1264, FORM 2, PATTERN E, FIRE CLASS A. DUCTED RETURNS ONLY.
F-2	VINYL WALL BASE, SEE FLOOR FINISH FOR COLOR
FL-4	LUXURY VINYL TILE (LVT)
LT-1	2'x4' RECESSED TROFFER
PF-1	LAB-GRADE SINK
PT-1	PAINT #1, PRIMARY WALL COLOR SW6539
PT-3c	PAINT #3c, SECONDARY WALL COLOR SW6529, TO PAIR W/ PAINT #2c
T-17	120V WALL MOUNTED DUPLEX POWER OUTLET-WHITE
T-19	120V WALL MOUNTED DUPLEX POWER OUTLET W/ GROUND FAULT INTERRUPT (GFI)-WHITE
T-20	CARD READER FOR SECURE ACCESS
T-21	WALL MOUNTED DATA OUTLET



United States Department of Agriculture
Forest Service

R-08
Southern Region

PROJECT NAME:

R-08 SOUTHERN REGION OFFICE SPACE TOOLS & TEMPLATES

UNITED STATES DEPARTMENT OF AGRICULTURE
FOREST SERVICE

SOUTHERN REGION (R8)
1720 PEACHTREE ROAD, NW
ATLANTA, GA. 30309

DRAWING TITLE

LARGE LAB

DATE
05/24/19

ARCHIVE NUMBER:

DESIGNER:
Designer

DWG SHEET NO:


A128

DRAWN BY:
Author


CHECKED BY:
Checker

PROJECT NO:
12432P18D0002


SHEET XXX OF XXX

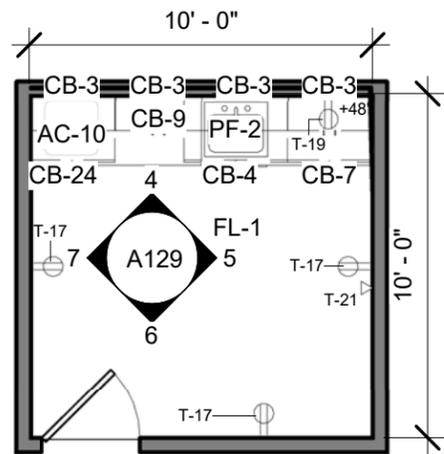


1 WELLNESS
3/16" = 1'-0"

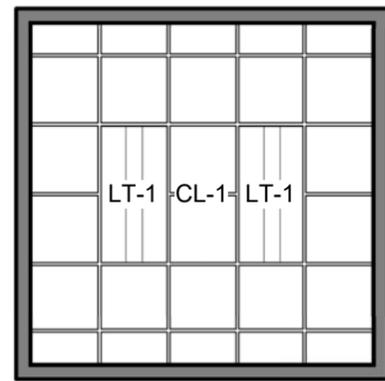


2 WELLNESS RCP
3/16" = 1'-0"

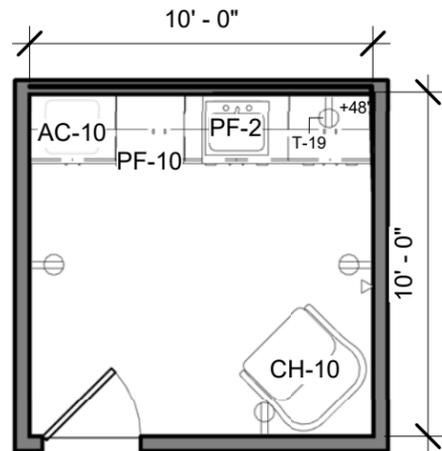


3 WELLNESS FURNITURE
3/16" = 1'-0"

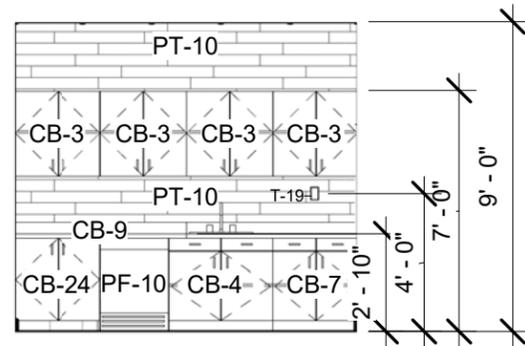


4 WELLNESS ELEV. 1
3/16" = 1'-0"

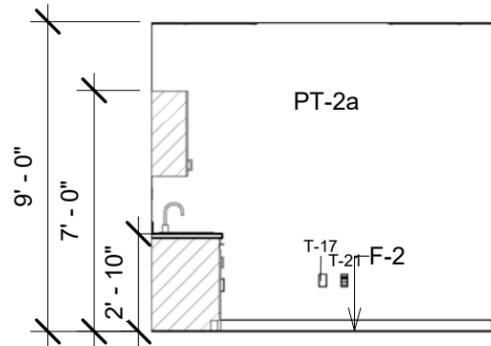

5 WELLNESS ELEV. 2
3/16" = 1'-0"

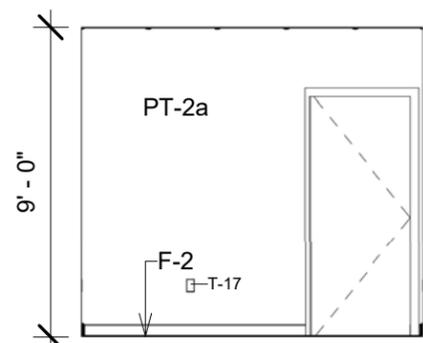

6 WELLNESS ELEV. 3
3/16" = 1'-0"

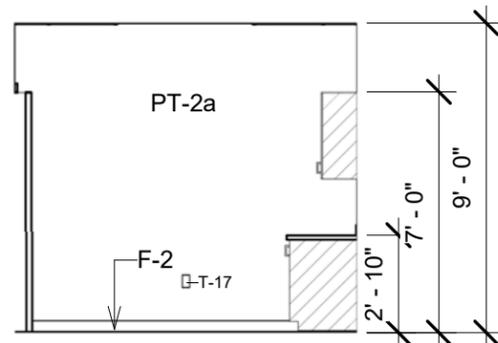

7 WELLNESS ELEV. 4
3/16" = 1'-0"



8 WELLNESS

KEYNOTE LEGEND

AC-10	TRASH CAN -UNDER COUNTER
CB-3	36" MODULAR CASEWORK UPPER DOUBLE DOOR CABINET 36"T
CB-4	36" REMOVABLE FULL HEIGHT DOUBLE DOOR BASE CABINET
CB-7	36" MODULAR CASEWORK BASE CABINET, DOUBLE DRAWERS & DOORS
CB-9	COUNTERTOP, 24" DEEP
CB-24	30" REMOVABLE FULL HEIGHT DOUBLE DOOR BASE CABINET
CH-10	LARGE LOUNGE CHAIR
CL-1	2X2 ACCOUSTIC CEILING TILE, ASTM E1264, FORM 2, PATTERN E, FIRE CLASS A. DUCTED RETURNS ONLY.
F-2	VINYL WALL BASE, SEE FLOOR FINISH FOR COLOR
FL-1	MODULAR CARPET TILE
LT-1	2'x4' RECESSED TROFFER
PF-2	KITCHEN GRADE SINK
PF-10	UNDER CABINET REFRIGERATOR W/ LOCKABLE DOOR
PT-2a	PAINT #2a, SECONDARY WALL COLOR SW6437, TO PAIR W/ PAINT #3a
PT-10	WALL TILE W/ WOOD GRAIN PATTERN FOR COLOR OPTION 2 & DECO PATTERN FOR COLOR OPTION 2
T-17	120V WALL MOUNTED DUPLEX POWER OUTLET-WHITE
T-19	120V WALL MOUNTED DUPLEX POWER OUTLET W/ GROUND FAULT INTERRUPT (GFI)-WHITE
T-21	WALL MOUNTED DATA OUTLET



United States Department of Agriculture
Forest Service

R-08
Southern Region

PROJECT NAME:

R-08 SOUTHERN REGION OFFICE SPACE TOOLS & TEMPLATES

UNITED STATES DEPARTMENT OF AGRICULTURE FOREST SERVICE

SOUTHERN REGION (R8)
1720 PEACHTREE ROAD, NW
ATLANTA, GA. 30309

DRAWING TITLE

WELLNESS

DATE

05/24/19

ARCHIVE NUMBER:

DESIGNER:
Designer

DWG SHEET NO.:

DRAWN BY:
Author

A129

CHECKED BY:
Checker

PROJECT NO:
12432P18D0002

SHEET XXX OF XXX

KEYNOTE LEGEND	
CL-2	GYPSUM CEILING BOARD - PAINT TO MATCH PT-1. DUCTED RETURNS ONLY.
F-2	VINYL WALL BASE, SEE FLOOR FINISH FOR COLOR
FL-6	POLISHED CONCRETE FLOOR FINISH OR VCT
LT-8	2x2' SURFACE MOUNTED LED LIGHT FIXTURE
PT-1	PAINT #1, PRIMARY WALL COLOR SW6539
T-17	120V WALL MOUNTED DUPLEX POWER OUTLET-WHITE

PARTITION NOTES:

- ALL ROOMS LARGER THAN 500SF, OR SECURED ROOMS, TO HAVE DECK TO DECK PARTITIONS.

SECURE STORAGE NOTES:

- IF WALLS ARE STICK BUILT CONSTRUCTION USE 3/4" PLYWOOD AS INTERIOR SHEATHING.
- IF WALLS DO NOT GO TO STRUCTURAL DECK ABOVE, CEILING TO BE 3/4" PLYWOOD SCREWED TO JOISTS.
 - SURFACE MOUNTED FIXTURES ARE ACCEPTABLE IN HARD CEILING CONDITIONS
- INSTALL EXHAUST FAN W/ INLINE CARBON FILTER AND SWITCH.
- DOOR IS ACCESS CONTROLLED OR ON SEPARATE MASTER KEY, DETERMINED @ D.I.D. STAGE BY FOREST SERVICE.



R-08

Southern Region

PROJECT NAME:
R-08 SOUTHERN REGION OFFICE SPACE TOOLS & TEMPLATES

UNITED STATES DEPARTMENT OF AGRICULTURE
FOREST SERVICE

SOUTHERN REGION (R8)
1720 PEACHTREE ROAD, NW
ATLANTA, GA. 30309

DRAWING TITLE:
SMALL SECURE STORAGE

DATE:
05/24/19

ARCHIVE NUMBER:

DESIGNER:
Designer


DWG SHEET NO:
A130

DRAWN BY:
Author


CHECKED BY:
Checker

PROJECT NO:
12432P18D0002


SHEET XXX OF XXX

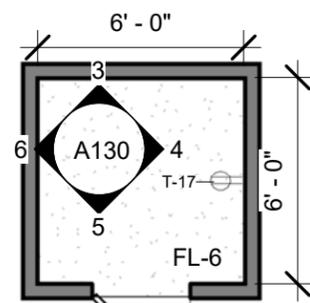


① **SMALL SECURE STORAGE**
3/16" = 1'-0"

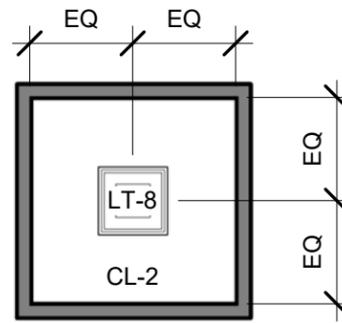


② **SMALL SECURE STORAGE RCP**
3/16" = 1'-0"

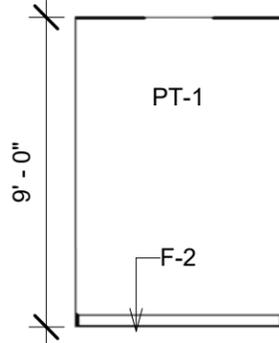


③ **S. STORAGE ELEV. 1**
3/16" = 1'-0"

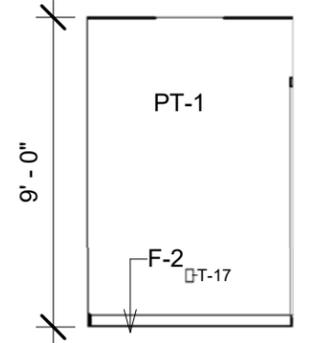

④ **S. STORAGE ELEV. 2**
3/16" = 1'-0"

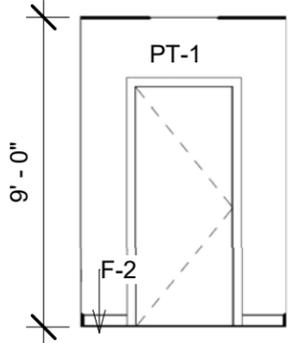

⑤ **S. STORAGE ELEV. 3**
3/16" = 1'-0"

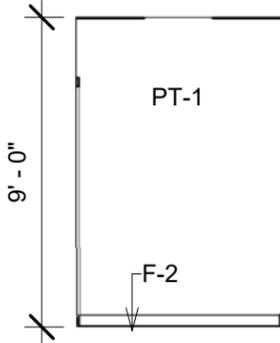

⑥ **S. STORAGE ELEV. 4**
3/16" = 1'-0"

KEYNOTE LEGEND	
CL-2	GYPSUM CEILING BOARD - PAINT TO MATCH PT-1. DUCTED RETURNS ONLY.
F-2	VINYL WALL BASE, SEE FLOOR FINISH FOR COLOR
FL-6	POLISHED CONCRETE FLOOR FINISH
LT-3	2'x4' SURFACE MOUNTED LED LIGHT FIXTURE
PT-1	PAINT #1, PRIMARY WALL COLOR SW6539
T-17	120V WALL MOUNTED DUPLEX POWER OUTLET-WHITE

PARTITION NOTES:

- ALL ROOMS LARGER THAN 500SF, OR SECURED ROOMS, TO HAVE DECK TO DECK PARTITIONS.

SECURE STORAGE NOTES:

- IF WALLS ARE STICK BUILT CONSTRUCTION USE 3/4" PLYWOOD AS INTERIOR SHEATHING.
- IF WALLS DO NOT GO TO STRUCTURAL DECK ABOVE, CEILING TO BE 3/4" PLYWOOD SCREWED TO JOISTS.
 - SURFACE MOUNTED FIXTURES ARE ACCEPTABLE IN HARD CEILING CONDITIONS
- INSTALL EXHAUST FAN W/ INLINE CARBON FILTER AND SWITCH.
- DOOR IS ACCESS CONTROLLED OR ON SEPARATE MASTER KEY, DETERMINED @ D.I.D. STAGE BY FOREST SERVICE.



United States Department of Agriculture
Forest Service

R-08

Southern Region

PROJECT NAME:
R-08 SOUTHERN REGION OFFICE SPACE TOOLS & TEMPLATES

UNITED STATES DEPARTMENT OF AGRICULTURE
FOREST SERVICE

SOUTHERN REGION (R8)
1720 PEACHTREE ROAD, NW
ATLANTA, GA. 30309

DRAWING TITLE:
MEDIUM SECURE STORAGE

DATE:
05/24/19

ARCHIVE NUMBER:

DESIGNER:
Designer



DWG SHEET NO:
A131

DRAWN BY:
Author

CHECKED BY:
Checker





PROJECT NO:
12432P18D0002

SHEET XXX OF XXX

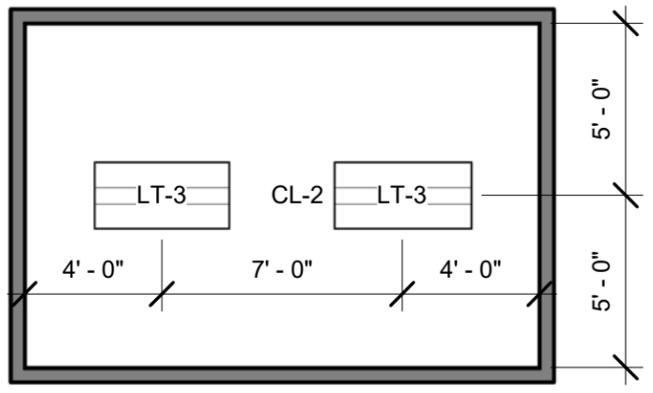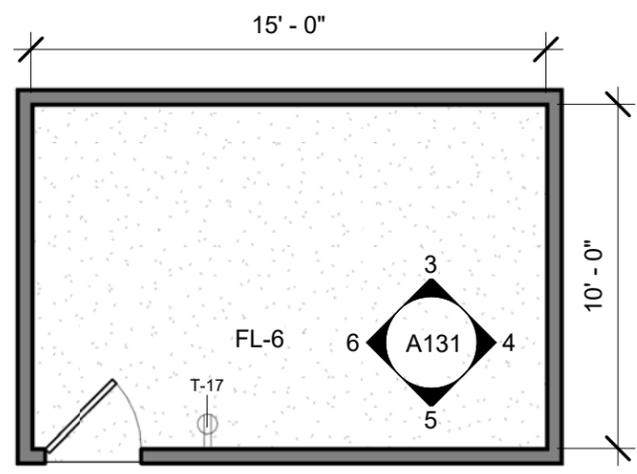

① MEDIUM SECURE STORAGE
3/16" = 1'-0"

② MEDIUM SECURE STORAGE RCP
3/16" = 1'-0"

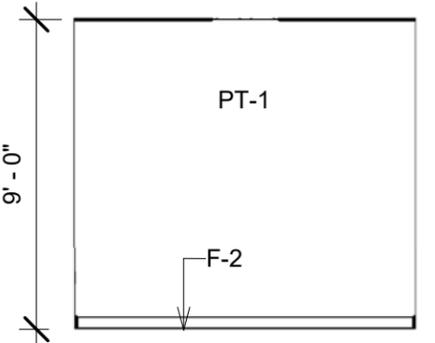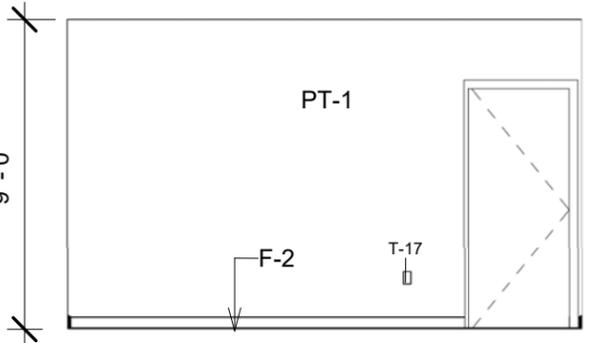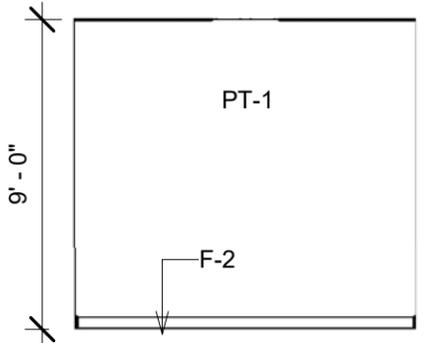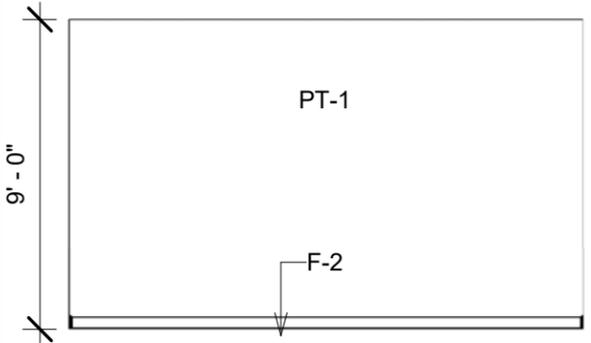


③ M. STORAGE ELEV. 1
3/16" = 1'-0"

④ M. STORAGE ELEV. 2
3/16" = 1'-0"

⑤ M. STORAGE ELEV. 3
3/16" = 1'-0"

⑥ M. STORAGE ELEV. 4
3/16" = 1'-0"

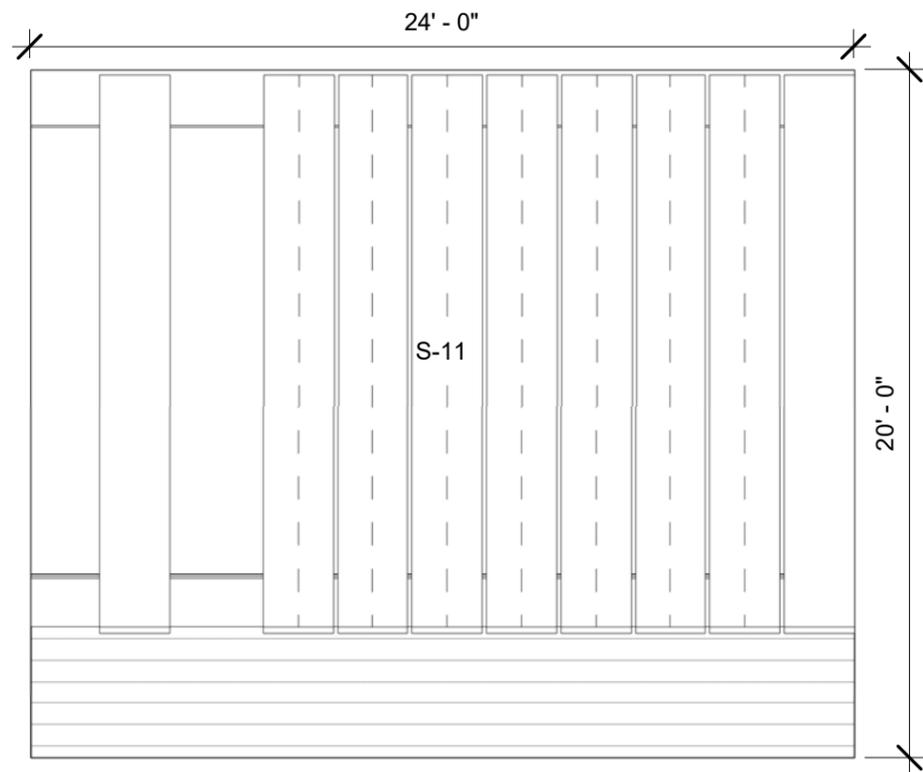

1 **COMPACTION STORAGE**
3/16" = 1'-0"

KEYNOTE LEGEND	
S-11	LARGE SLIDING STORAGE SYSTEM ON RAILS, 8 RACKS
NOTE: ONLY USE THIS COMPACTION STORAGE LAYOUT WHEN STORAGE IS OPEN & NOT SECURED. MAY BE FREESTANDING OR PARTIALLY ENCLOSED DEPENDING ON INTERIOR ARRANGEMENT.	



United States Department of Agriculture
Forest Service

R-08

Southern Region

PROJECT NAME:
R-08 SOUTHERN REGION OFFICE SPACE TOOLS & TEMPLATES


UNITED STATES DEPARTMENT OF AGRICULTURE FOREST SERVICE

SOUTHERN REGION (R8)
1720 PEACHTREE ROAD, NW
ATLANTA, GA. 30309


DRAWING TITLE

COMPACTION STORAGE


DATE 05/24/19	
ARCHIVE NUMBER:	
DESIGNER: Designer	DWG SHEET NO: A132
DRAWN BY: Author	
CHECKED BY: Checker	SHEET XXX OF XXX
PROJECT NO: 12432P18D0002	

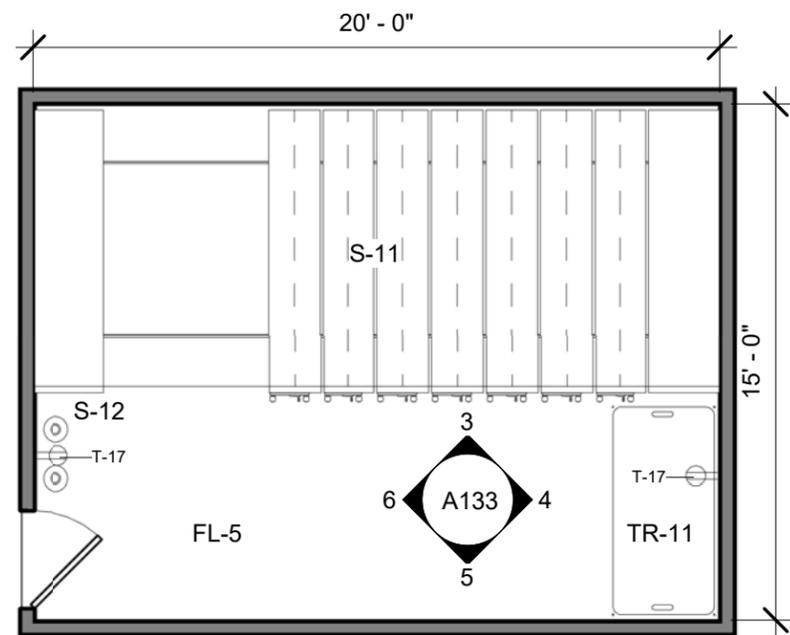


1 VAULT STORAGE
3/16" = 1'-0"

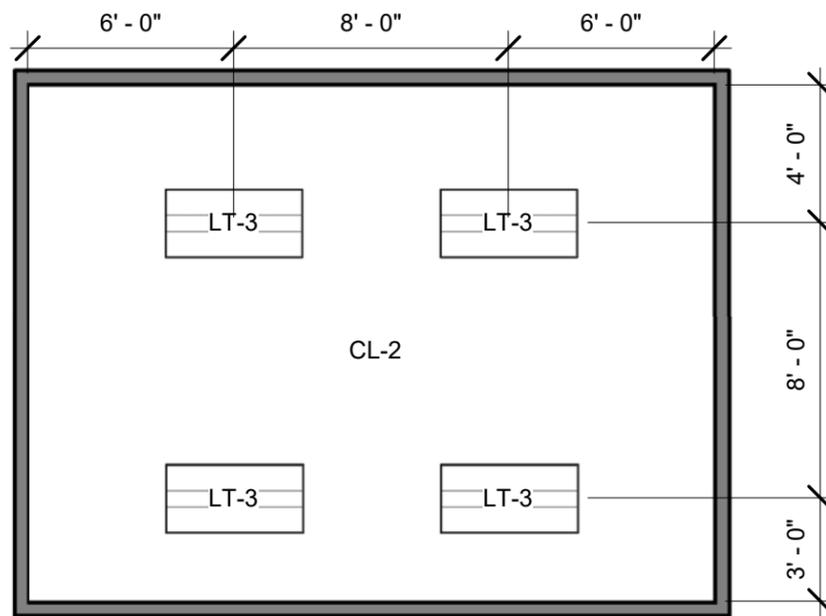


2 VAULT STORAGE RCP
3/16" = 1'-0"

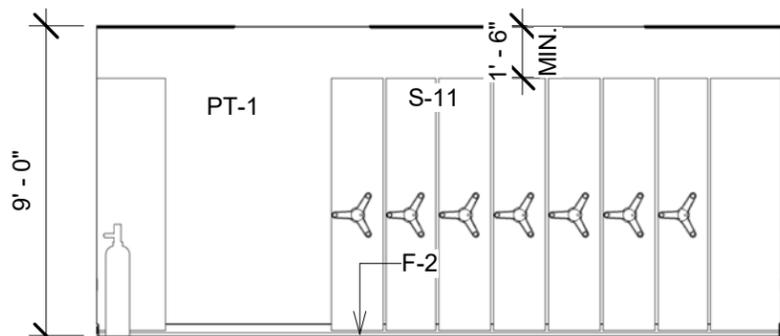


3 V. STORAGE ELEV. 1
3/16" = 1'-0"

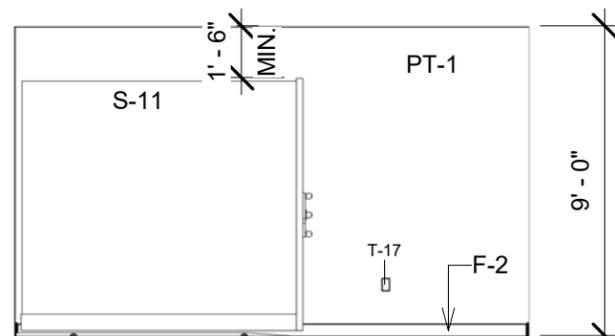


4 V. STORAGE ELEV. 2
3/16" = 1'-0"

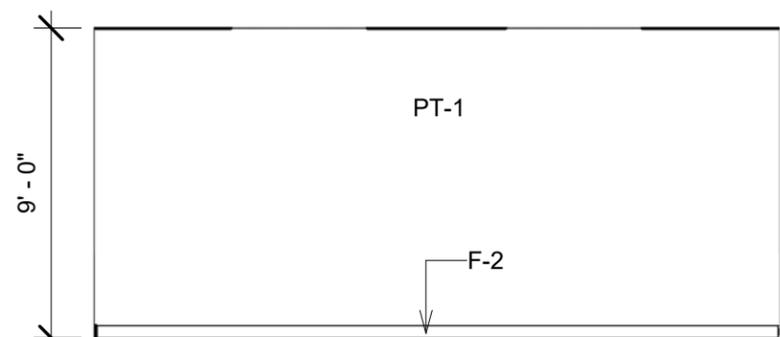

5 V. STORAGE ELEV. 3
3/16" = 1'-0"

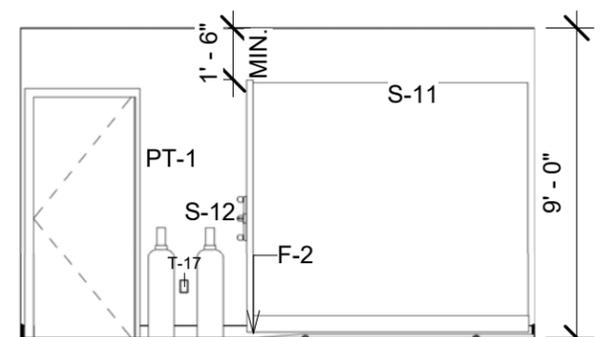

6 V. STORAGE ELEV. 4
3/16" = 1'-0"

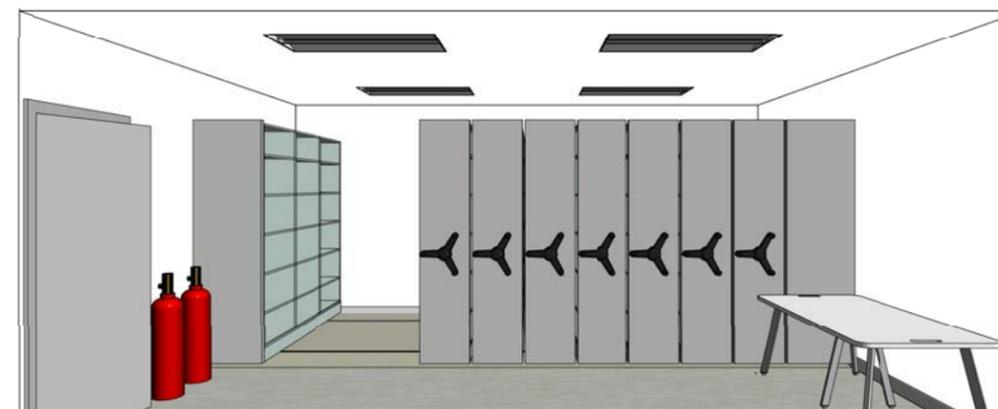

7 VAULT STORAGE

KEYNOTE LEGEND	
CL-2	GYPSUM CEILING BOARD - PAINT TO MATCH PT-1. DUCTED RETURNS ONLY.
F-2	VINYL WALL BASE, SEE FLOOR FINISH FOR COLOR
FL-5	VINYL COMPOSITE TILE (VCT)
LT-3	2'x4' SURFACE MOUNTED LED LIGHT FIXTURE
PT-1	PAINT #1, PRIMARY WALL COLOR SW6539
S-11	LARGE SLIDING STORAGE SYSTEM ON RAILS, 8 RACKS
S-12	CLEAN AGENT FIRE SUPPRESSION
T-17	120V WALL MOUNTED DUPLEX POWER OUTLET-WHITE
TR-11	36"Dx72"W TABLE

VAULT STORAGE NOTES:
 1. WALLS & CEILING 1-HR FIRE RATED.
 2. IF A HARD CEILING IS USED, SURFACE MOUNTED LIGHTS ARE ACCEPTABLE.



United States Department of Agriculture
Forest Service

R-08

Southern Region

PROJECT NAME:
R-08 SOUTHERN REGION OFFICE SPACE TOOLS & TEMPLATES

UNITED STATES DEPARTMENT OF AGRICULTURE
 FOREST SERVICE

SOUTHERN REGION (R8)
 1720 PEACHTREE ROAD, NW
 ATLANTA, GA. 30309

DRAWING TITLE:
 VAULT STORAGE

DATE:
 05/24/19

ARCHIVE NUMBER:

DESIGNER:
 Designer


DWG SHEET NO:
 A133

DRAWN BY:
 Author


CHECKED BY:
 Checker

PROJECT NO:
 12432P18D0002


SHEET XXX OF XXX

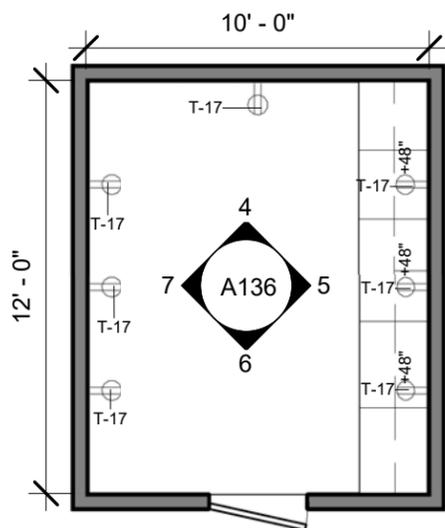


1 MAIL ROOM
3/16" = 1'-0"

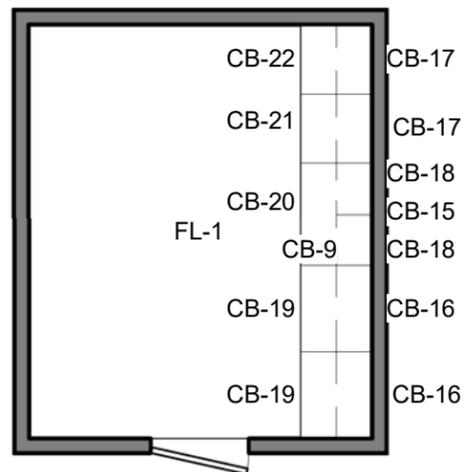


2 MAIL ROOM FURNITURE
3/16" = 1'-0"

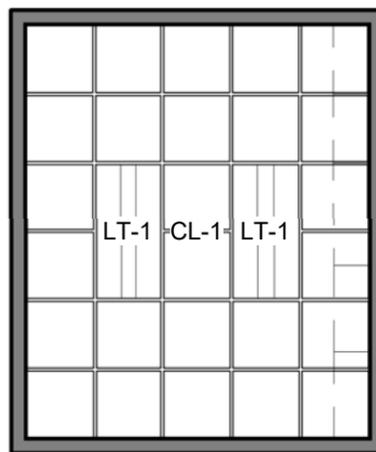

3 MAIL ROOM RCP
3/16" = 1'-0"

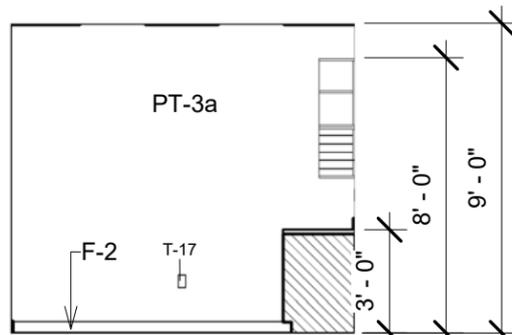


4 MAIL ELEV. 1
3/16" = 1'-0"

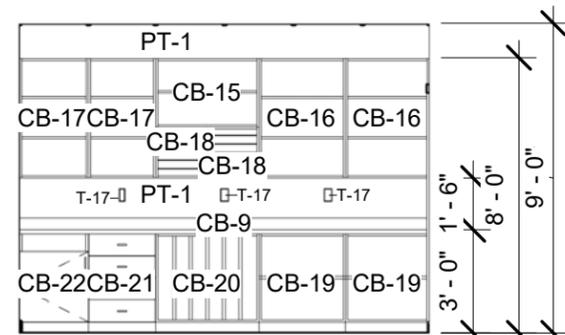


5 MAIL ELEV. 2
3/16" = 1'-0"



8 MAIL ROOM

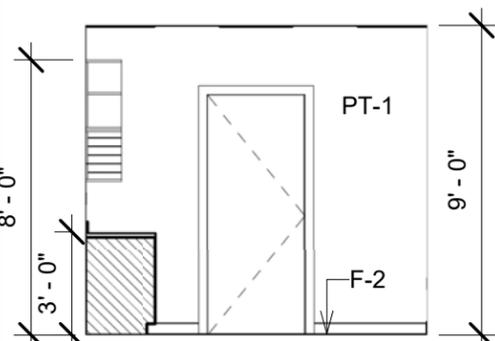

6 MAIL ELEV. 3
3/16" = 1'-0"

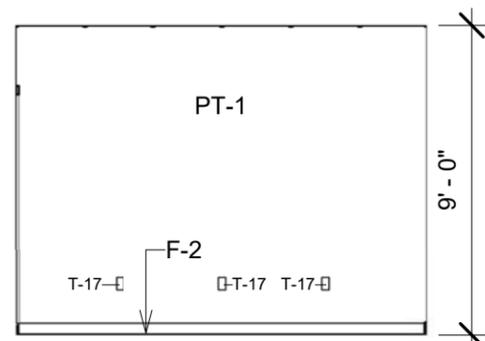

7 MAIL ELEV. 4
3/16" = 1'-0"

KEYNOTE LEGEND

CB-9	COUNTERTOP, 24" DEEP
CB-15	36"x24"T MODULAR OPEN UPPER CABINET, 2 OPEN SHELVES
CB-16	30"x36"T MODULAR OPEN UPPER CABINET, 3 OPEN SHELVES
CB-17	30"x36"T MODULAR OPEN UPPER CABINET, 3 OPEN SHELVES
CB-18	18"x18"T UPPER CABINETS W/ MAIL STORAGE
CB-19	30" MODULAR OPEN BASE CABINETS W/ 2 OPEN SHELVES
CB-20	36" MODULAR OPEN BASE CABINETS W/ OPEN VERTICAL STORAGE
CB-21	30" MODULAR 4 DRAWER BASE CABINET
CB-22	30" MODULAR COMBINATION BASE DRAWER W/ DRAWER & OPEN STORAGE
CL-1	2X2 ACOUSTIC CEILING TILE, ASTM E1264, FORM 2, PATTERN E, FIRE CLASS A, DUCTED RETURNS ONLY.
F-2	VINYL WALL BASE, SEE FLOOR FINISH FOR COLOR
FL-1	MODULAR CARPET TILE
LT-1	2'x4' RECESSED TROFFER
PT-1	PAINT #1, PRIMARY WALL COLOR SW6539
PT-3a	PAINT #3a, SECONDARY WALL COLOR SW6439, TO PAIR W/ PAINT #2a
T-17	120V WALL MOUNTED DUPLEX POWER OUTLET-WHITE



United States Department of Agriculture
Forest Service

R-08
Southern Region

PROJECT NAME:

R-08 SOUTHERN REGION OFFICE SPACE TOOLS & TEMPLATES

UNITED STATES DEPARTMENT OF AGRICULTURE
FOREST SERVICE

SOUTHERN REGION (R8)
1720 PEACHTREE ROAD, NW
ATLANTA, GA. 30309

DRAWING TITLE

MAIL ROOM

DATE

05/24/19

ARCHIVE NUMBER:

DESIGNER:

Designer

DWG SHEET NO.:

A136

DRAWN BY:

Author

CHECKED BY:

Checker

PROJECT NO:
12432P18D0002

SHEET XXX OF XXX

<p>CH-1 STACKABLE TASK CHAIR</p>	<p>CH-2 DESK CHAIR</p>	<p>CH-3 HIGHBACK LOUNGE CHAIR</p>	<p>CH-4 BAR HEIGHT CAFE CHAIR</p>	<p>CH-6 18"x48" BENCH</p>	<p>CH-7 18"x36" BENCH</p>	<p>CH-10 LOUNGE CHAIR</p>	<p>CH-12 PADDED LOUNGE CHAIR</p>	<p>CH-13 PADDED LOUNGE SOFA</p>	<p>THE FURNITURE TYPES REPRESENT BASES OF DESIGN STANDARDS FOR FURNITURE. THE FINAL FURNITURE PIECES SHALL BE DETERMINED BY US FOREST SERVICE PURCHASING AGENTS FOR EACH INDIVIDUAL PURCHASE ORDER.</p>
<p>TR-6 36" SQUARE TABLE</p>	<p>TR-1 24"x60" TRAINING TABLE</p>	<p>TR-13 24" CORNER TRAINING TABLE</p>	<p>TR-9 30"x60" TABLE</p>	<p>TR-14 30"x72" HIGH TOP TABLE</p>	<p>TR-11 36"x72" TABLE</p>	<p>TR-12 60"x144" TABLE</p>			
<p>TR-4 30" DIA. COFFEE TABLE</p>	<p>TR-7 54" DIA. TABLE</p>	<p>TR-3 18"x75" CREDENZA</p>	<p>S-3 LOCKERS</p>	<p>S-8 OPEN STORAGE SHELVES 48"x24"x85"</p>	<p>S-13 ABOVE DESK OPEN SHELVES 14"x72"</p>	<p>AC-8 MOBILE LAB CART</p>	<p>CB-13 SHELVED CABINET 24"x30"x72"</p>		



United States Department of Agriculture
Forest Service

R-08

Southern Region

PROJECT NAME:

R-08 SOUTHERN
REGION OFFICE
SPACE TOOLS &
TEMPLATES

UNITED STATES
DEPARTMENT OF
AGRICULTURE
FOREST SERVICE

SOUTHERN REGION (R8)
1720 PEACHTREE ROAD, NW
ATLANTA, GA. 30309

DRAWING TITLE

FURNITURE TYPES

DATE
05/24/19

ARCHIVE NUMBER:

DESIGNER:
Designer

DWG SHEET NO:







DRAWN BY:
Author

A200

CHECKED BY:
Checker

PROJECT NO:
12432P18D0002

SHEET XXX OF XXX
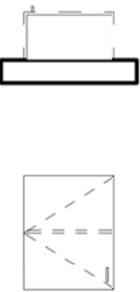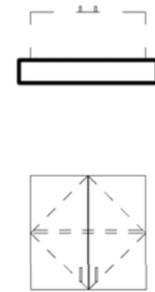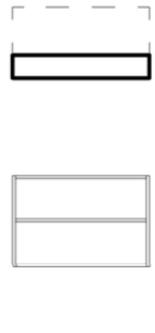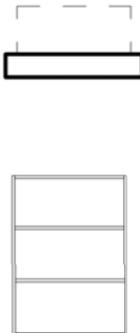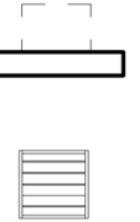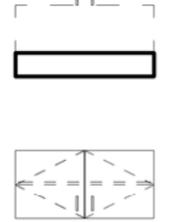
<p>CB-1 SINGLE DOOR UPPER CABINET</p> 	<p>CB-2/3 DOUBLE DOOR UPPER CABINET VARIOUS WIDTHS</p> 	<p>CB-4 REMOVABLE FULL HEIGHT DOUBLE DOOR BASE CABINET</p> 	<p>CB-5 SINGLE DOOR BASE CABINET</p> 	<p>CB-7 DOUBLE DOOR BASE CABINET</p> 	<p>CB-14 DOUBLE DOOR SINK BASE CABINET</p> 	<p>CB-15 TWO SHELF UPPER CABINET 24" T</p> 	<p>CB-16/17 THREE SHELF UPPER CABINET</p> 
<p>CB-18 UPPER MAIL CABINET 18" T</p> 	<p>CB-19/23 TWO SHELF BASE CABINET</p> 	<p>CB-20 VERTICAL STORAGE BASE CABINET</p> 	<p>CB-21 4 DRAWER BASE CABINET</p> 	<p>CB-22 BASE CABINET W/ OPEN DRAWER</p> 	<p>CB-25 FULL HEIGHT BASE CABINET</p> 	<p>CB-26 DOUBLE DOOR UPPER CABINET 24" T</p> 	

THE FURNITURE TYPES REPRESENT BASES OF DESIGN STANDARDS FOR FURNITURE. THE FINAL FURNITURE PIECES SHALL BE DETERMINED BY US FOREST SERVICE PURCHASING AGENTS FOR EACH INDIVIDUAL PURCHASE ORDER.



R-08
Southern Region

PROJECT NAME:
R-08 SOUTHERN REGION OFFICE SPACE TOOLS & TEMPLATES

UNITED STATES DEPARTMENT OF AGRICULTURE FOREST SERVICE

SOUTHERN REGION (R8)
1720 PEACHTREE ROAD, NW
ATLANTA, GA. 30309

DRAWING TITLE:
FURNITURE TYPES

DATE 05/24/19	
ARCHIVE NUMBER:	
DESIGNER: Designer	DWG SHEET NO: A201
DRAWN BY: Author	
CHECKED BY: Checker	
PROJECT NO: 12432P18D0002	SHEET XXX OF XXX



INSPIRATION IMAGES



1 CONTEMPORARY FOREST GREEN COLOR SCHEME

FL-1 & FL-2 CARPET TILE

- SIZE- 10" X 40" PLANK
- PATTERN INSTALLATION- HERRINGBONE
- COLOR- GOLDENROD
- IAQ- GREEN LABEL PLUS
- BASIS OF DESIGN- INTERFACE PM01 PORTMANTEAU COLLECTION 104825 GOLDENROD
- VINYL BASE COLOR- JOHNSONITE 09 CLAY



FL-4 LUXURY VINYL TILE

- SIZE- 10" X 40" PLANK
- PATTERN INSTALLATION- ASHLAR
- COLOR- MAHOGANY
- IAQ- CERTIFIED LOW-VOC EMISSIONS
- BASIS OF DESIGN- INTERFACE LEVEL SET COLLECTION NATURAL WOODGRAINS A00209 MAHOGANY
- VINYL BASE COLOR- JOHNSONITE 76 CINNAMON



FL-4 VINYL COMPOSITE TILE

- TILE COLOR- BASES OF DESIGN ARMSTRONG RAFFIA 55806 GOLDEN BLOSSOM
- TILE SIZE- 12" X 24"
- PATTERN- 1/3 RUNNING BOND



PT-2A SECONDARY WALL COLOR

- PAINT COLOR- SW6478 WATERY
- FINISH FOR GYPSUM BOARD- FLAT
- FINISH FOR MASONRY- LOW LUSTER



PT-2B SECONDARY WALL COLOR

- PAINT COLOR- SW6379 JERSEY CREAM
- FINISH FOR GYPSUM BOARD- FLAT
- FINISH FOR MASONRY- LOW LUSTER




PT-2C SECONDARY WALL COLOR

- PAINT COLOR- SW6527 BLISSFUL BLUE
- FINISH FOR GYPSUM BOARD- FLAT
- FINISH FOR MASONRY- LOW LUSTER




PT-1 PRIMARY WALL COLOR (60% OF WALLS)

- PAINT COLOR- SW6539 SOOTHING WHITE
- FINISH FOR GYPSUM BOARD- FLAT
- FINISH FOR MASONRY- LOW LUSTER

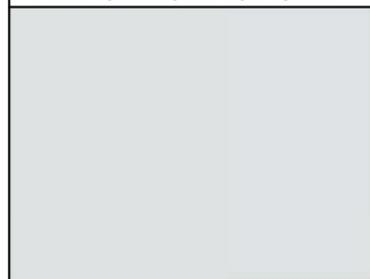

PT-3A ACCENT WALL COLOR

- PAINT COLOR- SW6481 GREEN BAY
- FINISH FOR GYPSUM BOARD- FLAT
- FINISH FOR MASONRY- LOW LUSTER

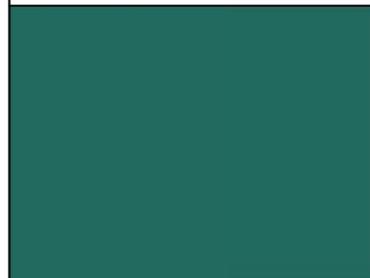


PT-3B ACCENT WALL COLOR

- PAINT COLOR- SW6380 HUMBLE GOLD
- FINISH FOR GYPSUM BOARD- FLAT
- FINISH FOR MASONRY- LOW LUSTER




PT-3C ACCENT WALL COLOR

- PAINT COLOR- SW6523 DENIM
- FINISH FOR GYPSUM BOARD- FLAT
- FINISH FOR MASONRY- LOW LUSTER

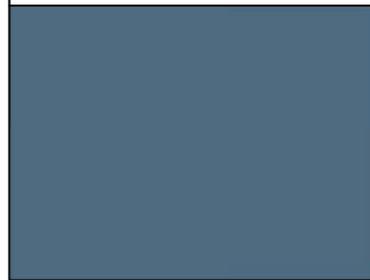

ACT-1 ACOUSTICAL CEILING SYSTEM

- GRID FACE / COLOR- 15/16" / WHITE
- GRID SIZE- 2X2
- TILE TEXTURE / COLOR- FINE / WHITE
- TILE EDGE- SQUARE TEGULAR 9/16"

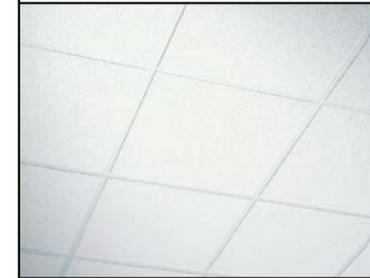

PT-10 WALL COVERING ACCENT

- TYPE / SIZE- WALL TILE / 10X30
- COLOR / FINISH- WHITE / GLOSS
- PATTERN- STACKED
- MORTAR- WHITE
- STYLE- TEXTURED HORIZONTAL LINES
- BASIS OF DESIGN- ARCHITECTURE CERAMICS ILLUSION BIANCO LINE MATTE WALL DECO TILE



PT-11 WALL COVERING ACCENT

- TYPE- NATURAL WOOD PANEL
- COLOR- POPLAR BARK
- PATTERN- FLUSH, STACKED
- FINISH- SANDED, SEMI-GLOSS
- BASIS OF DESIGN- BARK HOUSE BARK



PT-11(ALT.) WALL COVERING ACCENT

- TYPE- VINYL WALL DECAL
- COLOR- US FOREST IMAGE
- PATTERN- VERTICAL TREES OR SIMILAR



PT-12 ACOUSTICAL PANEL

- FABRIC COLOR- BASES OF DESIGN ANCHORAGE 2335 VANILLA 2130
- TRACK TYPE- CONCEALED SIMILAR TO FABRIC MATE FS210 FRAME




CB-9 / SF-1 COUNTERTOPS

- CB-9 COLOR- BASES OF DESIGN FORMICA 940-90 WHITE GLOSS FINISH
- SF-1 COLOR- BASE OF DESIGN CORIAN WHITE ONYX




TR-1 - TR-12 TABLE

- LAMINATE COLOR- 949-90 WHITE
- LAMINATE FINISH- GLOSS
- BASE COLOR / FINISH- BRASS / SATIN

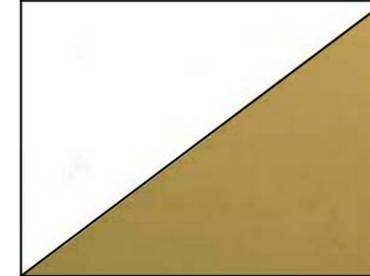

CH-1 - CH-13 CHAIR

- FABRIC COLOR- BEIGE
- FABRIC TYPE- KNIT
- METAL COLOR / FINISH- BLACK / MATTE

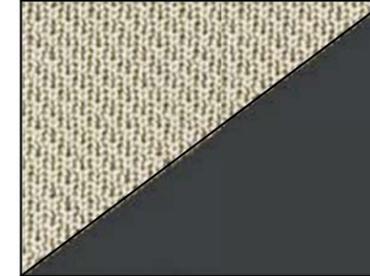

United States Department of Agriculture
Forest Service

R-08
Southern Region

PROJECT NAME:

R-08 SOUTHERN REGION OFFICE SPACE TOOLS & TEMPLATES

UNITED STATES DEPARTMENT OF AGRICULTURE FOREST SERVICE

SOUTHERN REGION (R8)
1720 PEACHTREE ROAD, NW
ATLANTA, GA. 30309

DRAWING TITLE:

COLOR OPTION 1- CONTEMPORARY FOREST GREEN

DATE:

05/24/19

ARCHIVE NUMBER:

DESIGNER:

Designer

DWG SHEET NO.:

A300

DRAWN BY:

Author

CHECKED BY:

Checker

PROJECT NO.:

12432P18D0002

SHEET XXX OF XXX




INSPIRATION IMAGE



1 WOODLANDS & WHITE COLOR SCHEME


FL-1 & FL-2 CARPET TILE

- SIZE- 50cm SQUARE
- PATTERN INSTALLATION- MONOLITHIC
- COLOR- MINT JULEP / MEDICI BLUE
- IAQ- GREEN LABEL PLUS
- BASIS OF DESIGN- INTERFACE MONOCHROME 101858 MINT JULEP & 101845 MEDICI BLUE
- VINYL BASE COLOR- JOHNSONITE 21 PLATINUM

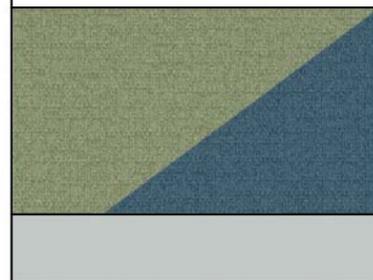

FL-4 LUXURY VINYL TILE

- SIZE- 25cm X 1m PLANK
- PATTERN INSTALLATION- ASHLAR
- COLOR- SILVERLIGHT
- IAQ- CERTIFIED LOW-VOC EMISSIONS
- BASIS OF DESIGN- INTERFACE LEVEL SET COLLECTION NATURAL WOODGRAINS A00701 SILVERLIGHT
- VINYL BASE COLOR- JOHNSONITE 21 PLATINUM

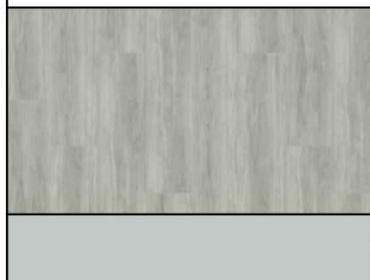

FL-4 VINYL COMPOSITE TILE

- TILE COLOR- BASES OF DESIGN ARMSTRONG RAFFIA 55801 PLATINUM
- TILE SIZE- 12" X 24"
- PATTERN- 1/3 RUNNING BOND



PT-2A SECONDARY WALL COLOR

- PAINT COLOR- SW6437 HAVEN
- FINISH FOR GYPSUM BOARD- FLAT
- FINISH FOR MASONRY- LOW LUSTER



PT-2B SECONDARY WALL COLOR

- PAINT COLOR- SW6379 JERSEY CREAM
- FINISH FOR GYPSUM BOARD- FLAT
- FINISH FOR MASONRY- LOW LUSTER



PT-2C SECONDARY WALL COLOR


- PAINT COLOR- SW6527 BLISSFUL BLUE
- FINISH FOR GYPSUM BOARD- FLAT
- FINISH FOR MASONRY- LOW LUSTER



INTERIOR WALL COLORS


PT-1 PRIMARY WALL COLOR (60% OF WALLS)

- PAINT COLOR- SW6539 SOOTHING WHITE
- FINISH FOR GYPSUM BOARD- FLAT
- FINISH FOR MASONRY- LOW LUSTER

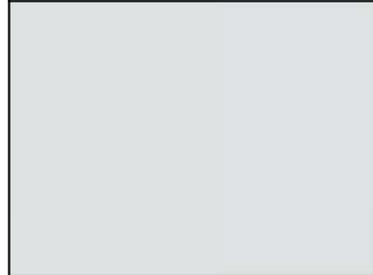

PT-3A ACCENT WALL COLOR

- PAINT COLOR- SW6439 GREENFIELD
- FINISH FOR GYPSUM BOARD- FLAT
- FINISH FOR MASONRY- LOW LUSTER

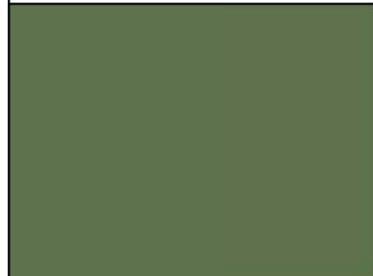


PT-3B ACCENT WALL COLOR

- PAINT COLOR- SW7072 ONLINE
- FINISH FOR GYPSUM BOARD- FLAT
- FINISH FOR MASONRY- LOW LUSTER



PT-3C ACCENT WALL COLOR

- PAINT COLOR- SW6529 SCANDA
- FINISH FOR GYPSUM BOARD- FLAT
- FINISH FOR MASONRY- LOW LUSTER

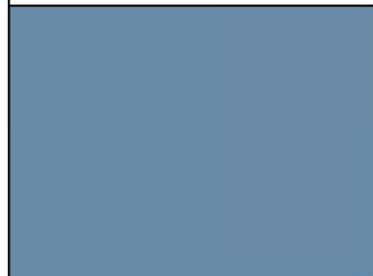

ACT-1 ACOUSTICAL CEILING SYSTEM

- GRID FACE / COLOR- 15/16" / WHITE
- GRID SIZE- 2X2
- TILE TEXTURE / COLOR- FINE / WHITE
- TILE EDGE- SQUARE TEGULAR 15/16"



PT-10 WALL COVERING ACCENT

- TYPE / SIZE- WALL TILE / 8X48
- COLOR / FINISH- GRAY / MATTE
- PATTERN- STAGGERED
- MORTAR- GRAY
- STYLE- WOOD GRAIN
- BASIS OF DESIGN- ARIZONA TILE ESSENCE SERIES GRAY



PT-11 WALL COVERING ACCENT

- TYPE- NATURAL WOOD PANEL
- COLOR- POPLAR BARK
- PATTERN- FLUSH, STACKED
- FINISH- SANDED, SEMI-GLOSS
- BASIS OF DESIGN- BARK HOUSE BARK



PT-11 (ALT.) WALL COVERING ACCENT

- TYPE- VINYL WALL DECAL
- COLOR- US FOREST IMAGE
- PATTERN- VERTICAL TREES OR SIMILAR



PT-12 ACOUSTICAL PANEL

- FABRIC COLOR- BASES OF DESIGN ANCHORAGE 2335 SLATE 2017
- TRACK TYPE- CONCEALED SIMILAR TO FABRIC MATE FS210 FRAME



CB-9 / SF-1 COUNTERTOPS

- CB-9 COLOR- BASES OF DESIGN FORMICA LAMINATE 940-90 WHITE GLOSS FINISH
- SF-1 COLOR- BASE OF DESIGN CORIAN WHITE ONYX




TR-1 - TR-12 TABLE

- STANDARD LAMINATE COLOR- 315 MEDIUM TEAK
- CAFE & BREAK LAMINATE COLOR- 4746-60 WOOLAMAI (MEDIUM BLUE) BRUSH
- BASE COLOR / FINISH- PEWTER / BRUSHED



CH-1 - CH-13 CHAIR

- CH-1, CH-2
- SEAT / BACK COLOR- LIGHT GRAY
- SEAT / BACK MATERIAL- KNIT OR PLASTIC
- FRAME COLOR / FINISH- BLACK / MATTE
- CH-3, CH-4, CH-10
- SEAT / BACK COLOR- DARK BLUE
- SEAT / BACK MATERIAL- KNIT OR PLASTIC
- FRAME COLOR / FINISH- BLACK / MATTE
- CH-12, CH-13
- SEAT / BACK COLOR- PALM
- SEAT / BACK MATERIAL- UPHOLSTERY
- FRAME COLOR / FINISH- BLACK / MATTE

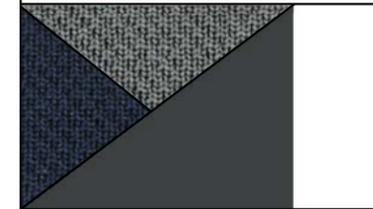

PT-16 ACCOUSTICAL WOOD WALL PLANK ACCENT

- SIZE- 5-1/4X96
- FINISH- WALNUT
- PATTERN- STAGGERED
- STYLE- WOOD GRAIN
- BASIS OF DESIGN- ARMSTRONG WOODWORKS LINERAR VENEERED PLANKS



United States Department of Agriculture
Forest Service

R-08
Southern Region

PROJECT NAME:

R-08 SOUTHERN REGION OFFICE SPACE TOOLS & TEMPLATES

UNITED STATES DEPARTMENT OF AGRICULTURE FOREST SERVICE

SOUTHERN REGION (R8)
1720 PEACHTREE ROAD, NW
ATLANTA, GA. 30309

DRAWING TITLE

COLOR OPTION 2- WOODLANDS & WHITE

DATE

05/24/19

ARCHIVE NUMBER:

DESIGNER:

Designer

DWG SHEET NO:

A301

DRAWN BY:

Author


CHECKED BY:

Checker


PROJECT NO:

12432P18D0002


SHEET XXX OF XXX

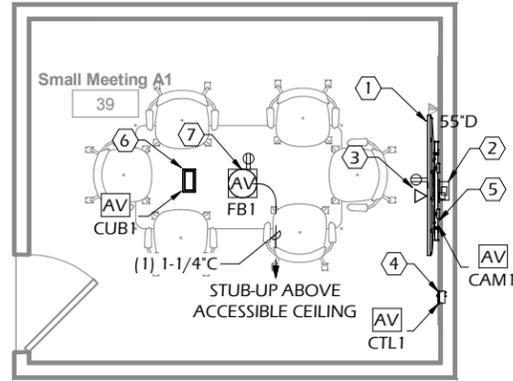


1 TYPICAL SMALL MEETING RMS A1 & A3
3/16" = 1'-0"

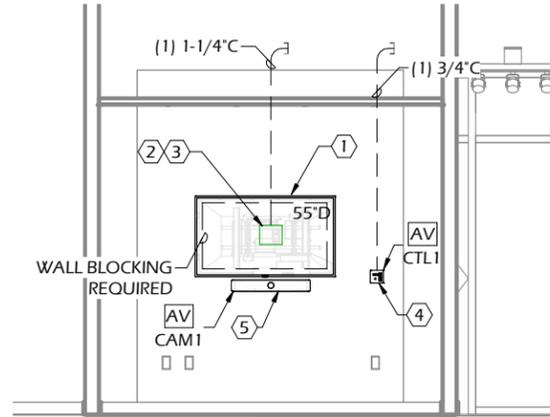

2 TYPICAL - SMALL MEETING RMS A1 & A3
3/16" = 1'-0"

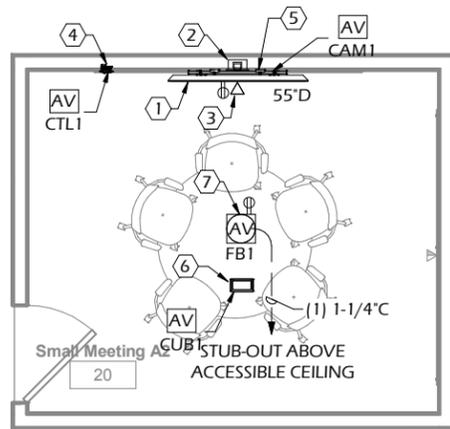

3 SMALL MEETING RMS A2
3/16" = 1'-0"

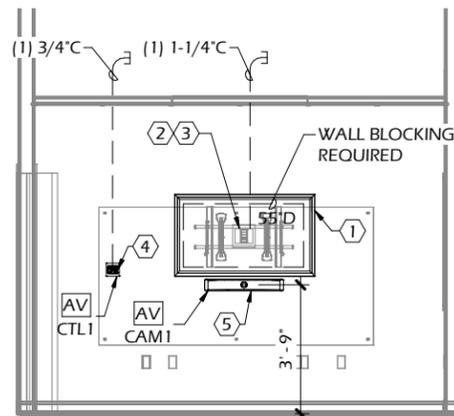

4 TYPICAL SMALL MEETING ROOM A2
3/16" = 1'-0"

General Notes:

- A. Provide and install electrical conduit 6" above accessible ceiling. Unless otherwise noted on this drawing.

Key Notes:

- 1 Provide and install wall mounted flat panel display. Provide and install wall blocking to support 5 times the display & mount's total weight. See detail drawings for additional information.
- 2 Provide and install shared in-wall back box Hubbell NSAV62M (AV-TV). (www.hubbell.com). Flush mounted at location shown on plans (unless otherwise noted on drawings).
- 3 Provide and install one 120V/1-phase duplex receptacle in one-gang insert of hubbell in-wall back box from a dedicated 20A/1-phase circuit in house panel. See electrical drawings for circuiting. Provide and install two(2) data outlets in one-gang insert of hubbell in-wall back box. See telecom drawings for additional information. Confirm final location and back box requirements with audio visual contractor prior to installation.
- 4 Provide and install a two(2)-gang back box, AV-CTL1, with minimum depth of 2.5" flush mounted at building switch height for audio video control panel.
- 5 Usb conferencing camera & mic. Provide and install below flat panel display.
- 6 Provide and install AV cable enclosure with flip lid and to coordinate with interiors/architect for installation in tabletop. Coordinate with architect prior to rough-in. Provide and install cable management system connecting table to floor box. AV table to connect to floor box with pluggable umbilical encased in black expandable sleeving.
- 7 Provide and install recessed floor box as shown on plans. Reference audio visual legend for additional information on floor box. Provide and install a 120V/1-phase duplex receptacle from a dedicated 20A/1-phase circuit in house power panel. Provide and install two (2) data outlets adjacent to power duplex in recessed floor box. See telecom drawings for additional information.



United States Department of Agriculture
Forest Service

R-08
Southern Region

PROJECT NAME:

R-08 SOUTHERN REGION OFFICE SPACE TOOLS & TEMPLATES

UNITED STATES DEPARTMENT OF AGRICULTURE FOREST SERVICE

SOUTHERN REGION (R8)
1720 PEACHTREE ROAD, NW
ATLANTA, GA 30309

DRAWING TITLE

SMALL MEETING ROOMS DETAILS

DATE
05/24/19

ARCHIVE NUMBER:

DESIGNER:
US FOREST SERVICE/TSW

DWG SHEET NO:


A600

DRAWN BY:
US FOREST SERVICE/TSW


CHECKED BY:
US FOREST SERVICE

SHEET XXX OF XXX

PROJECT NO:
19031

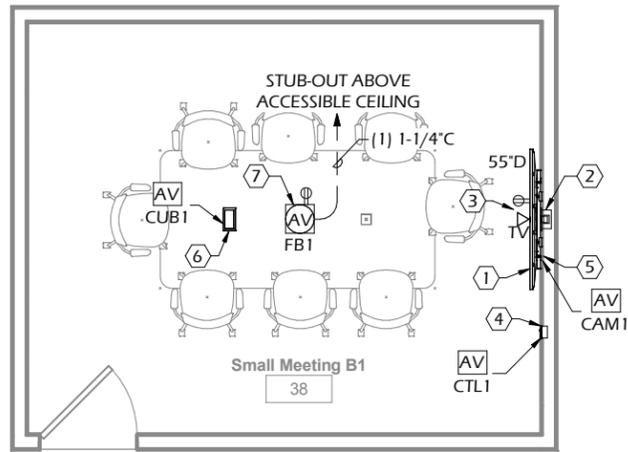

1 TYPICAL SMALL MEETING RMS B1 & B2
3/16" = 1'-0"

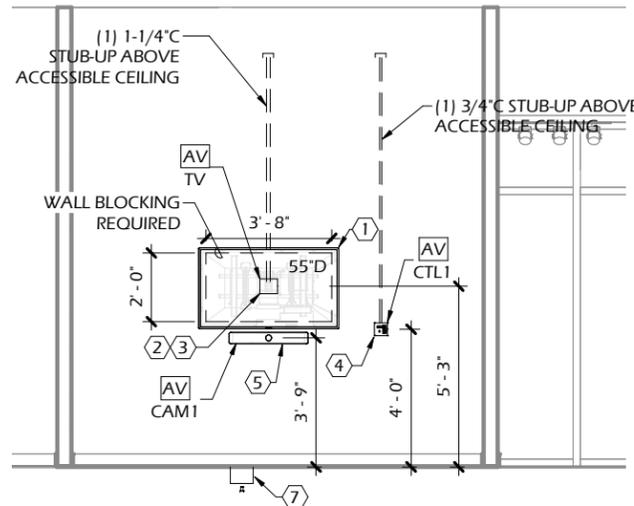

2 TYPICAL SMALL MEETING RMS B1 & B2
3/16" = 1'-0"

General Notes:

- A. Provide and install electrical conduit 6" above accessible ceiling. Unless otherwise noted on this drawing.

Key Notes:

- 1 Provide and install wall mounted flat panel display. Provide and install wall blocking to support 5 times the display & mount's total weight. See detail drawings for additional information.
- 2 Provide and install shared in-wall back box Hubbell NSAV62M (AV-TV). (www.hubbell.com). Flush mounted at location shown on plans (unless otherwise noted on drawings).
- 3 Provide and install one 120V/1-phase duplex receptacle in one-gang insert of hubbell in-wall back box from a dedicated 20A/1-phase circuit in house panel. See electrical drawings for circuiting. Provide and install two(2) data outlets in one-gang insert of hubbell in-wall back box. See telecom drawings for additional information. Confirm final location and back box requirements with audio visual contractor prior to installation.
- 4 Provide and install a two(2)-gang back box, AV-CTL1, with minimum depth of 2.5" flush mounted at building switch height for audio video control panel.
- 5 Usb conferencing camera & mic. Provide and install below flat panel display.
- 6 Provide and install AV cable enclosure with flip lid and to coordinate with interiors/architect for installation in tabletop. Coordinate with architect prior to rough-in. Provide and install cable management system connecting table to floor box. AV table to connect to floor box with pluggable umbilical encased in black expandable sleeving.
- 7 Provide and install recessed floor box as shown on plans. Reference audio visual legend for additional information on floor box. Provide and install a 120V/1-phase duplex receptacle from a dedicated 20A/1-phase circuit in house power panel. Provide and install two (2) data outlets adjacent to power duplex in recessed floor box. See telecom drawings for additional information.



R-08
Southern Region

PROJECT NAME:

R-08 SOUTHERN REGION OFFICE SPACE TOOLS & TEMPLATES

UNITED STATES DEPARTMENT OF AGRICULTURE FOREST SERVICE

SOUTHERN REGION (R8)
1720 PEACHTREE ROAD, NW
ATLANTA, GA 30309

DRAWING TITLE

SMALL MEETING ROOMS DETAILS

DATE
05/24/19

ARCHIVE NUMBER:

DESIGNER:
US FOREST SERVICE/TSW


DWG SHEET NO:
A601

DRAWN BY:
US FOREST SERVICE/TSW

CHECKED BY:
US FOREST SERVICE


PROJECT NO:
19031

SHEET XXX OF XXX

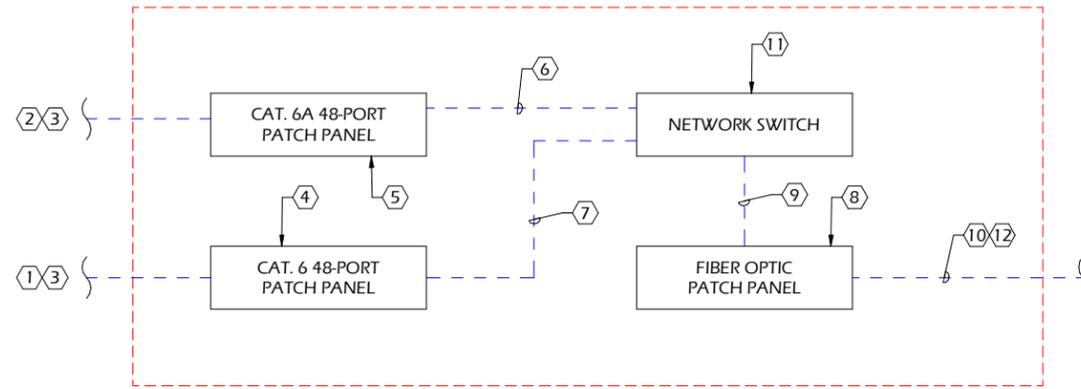

FINISHED FLOOR

1 ONE-LINE DIAGRAM - DATA DISTRIBUTION
N.T.S.

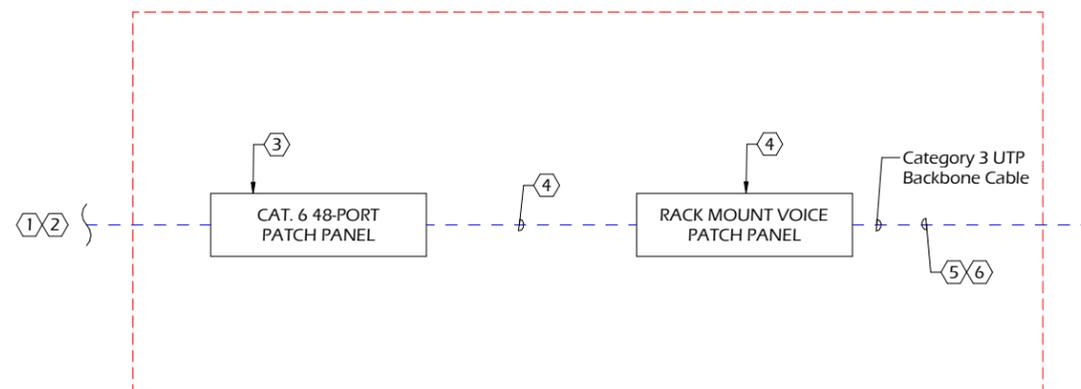

FINISHED FLOOR

2 ONE-LINE DIAGRAM - VOICE DISTRIBUTION
N.T.S.

Key Notes:

- ① Provide plenum-type 23 awg/category 6 compliant 4 pr. cable from category 6 patch panel in telecom rooms to station outlet locations & IP cameras. See legend and floor plans for requirements.
- ② Provide plenum-type 23 awg/category 6a compliant 4 pr. cables from category 6A patch panels in telecom rooms to all wireless access point locations.
- ③ Reference outlet details for terminations requirements.
- ④ All category 6 copper patch panels to be sized as required to provide cat. 6 link to all stations. provide spare capacity as required in specifications. Patch panels to be category 6 48-port type. see rack elevations for requirements.
- ⑤ All category 6A copper patch panels to be sized as required to provide cat. 6A link to all stations. Provide spare capacity as required in specifications. Patch panels to be category 6A 48-port type. See rack elevations for requirements.
- ⑥ Provide one(1) 2-meter category 6 patch cable for each terminated category 6 horizontal circuit.
- ⑦ Provide one(1) 2-meter category 6A patch cable for each terminated category 6A horizontal circuit.
- ⑧ Rack mount fiber optic connector panel. In MDF fiber to be terminated with LC connectors in 4 RMU panel. in IDF rooms fiber to be terminated with standard density bulkheads in 2 RMU panels.
- ⑨ All fiber optic strands to be terminated and tested. Multi-mode & single mode fiber optic patch cables. Provide one(1) multi-mode fiber optic patch cord for each multi-mode fiber termination and one(1) single mode fiber optic patch cord for each single mode strand termination.
- ⑩ Provide and install 12 strand OM-3, 50 micron, plenum rated laser optimized multi mode fiber optic cable between main telecom room (MDF) and other telecom rooms (IDFS).
- ⑪ All network switches to be provided by owner.
- ⑫ Fiber backbone cables to be provided with 10'-0" service loops on both ends of cable.

Key Notes:

- ① Provide plenum-type 23 awg/category 6 compliant 4 pr. cable from category 6 patch panel in telecom rooms to station outlet locations. See legend and floor plans for requirements.
- ② Reference outlet details for terminations requirements.
- ③ All category 6 copper patch panels to be sized as required to provide cat. 6 link to all stations. Provide spare capacity as required in specifications. patch panels to be category 6 48-port. See rack elevations for requirements.
- ④ Provide six(6) 3-meter cat. 3 patch cable for each telecom room. Turn over patch cables to owner. Provide 24-port voice patch panel for all UTP backbone cables. Label patch panel for voice application.
- ⑤ UTP backbone cable to be provided with 10'-0" service loops on both end of cable.
- ⑥ 25 pair category 3 voice cable routed to each telecom room. Terminate one pair to each RJ-45 port (blue pair).



United States Department of Agriculture
Forest Service

R-08
Southern Region

PROJECT NAME:

**R-08 SOUTHERN
REGION OFFICE
SPACE TOOLS &
TEMPLATES**

**UNITED STATES
DEPARTMENT OF
AGRICULTURE
FOREST SERVICE**

SOUTHERN REGION (R8)
1720 PEACHTREE ROAD, NW
ATLANTA, GA 30309

DRAWING TITLE

**ONE-LINE
DIAGRAM - DATA
& VOICE SERVICE**

DATE
05/24/19

ARCHIVE NUMBER:

DESIGNER:
US
FOREST
SERVICE/TSW

DWG SHEET NO.:


A602

DRAWN BY:
US
FOREST
SERVICE/TSW

CHECKED BY:
US
FOREST
SERVICE

PROJECT NO:
19031


SHEET XXX OF XXX

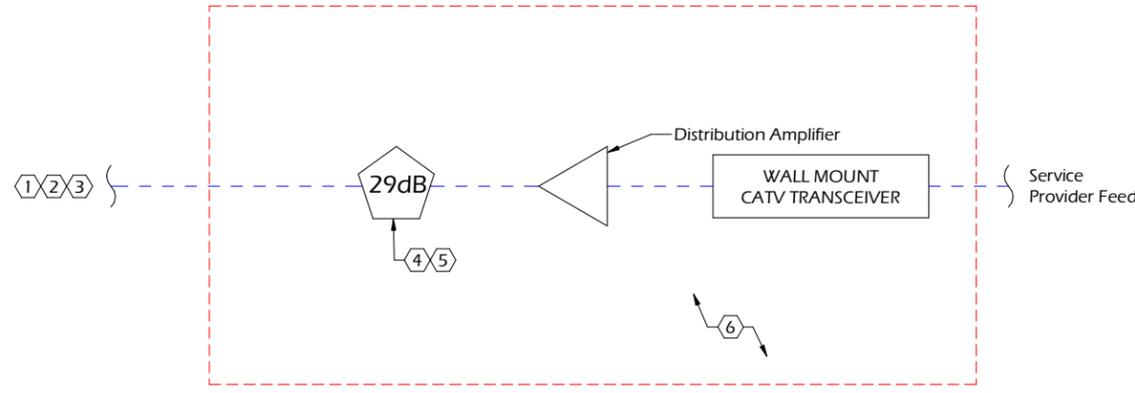

1 ONE-LINE DIAGRAM - CATV DISTRIBUTION
N.T.S.

Key Notes:


- 1 All horizontal CATV cables to be plenum rated RG-6U quad shield coaxial cable for distances up to 200' and RG-11U quad shield for distances between 200' and 300'. Terminate RG-6U quad shield cables with compression f-connectors and connect to CATV patch panel.
- 2 Reference outlet details for termination requirements.
- 3 Reference floor plan drawings for correct quantity of outlets.
- 4 Select attenuation tap values to ensure 0 to 10dbmv of signal level at each outlet.
- 5 Provide quantity of directional taps to match quantity of horizontal outlets plus 20% spare.
- 6 Provide and install all required RG-6U quad shield patch cables.

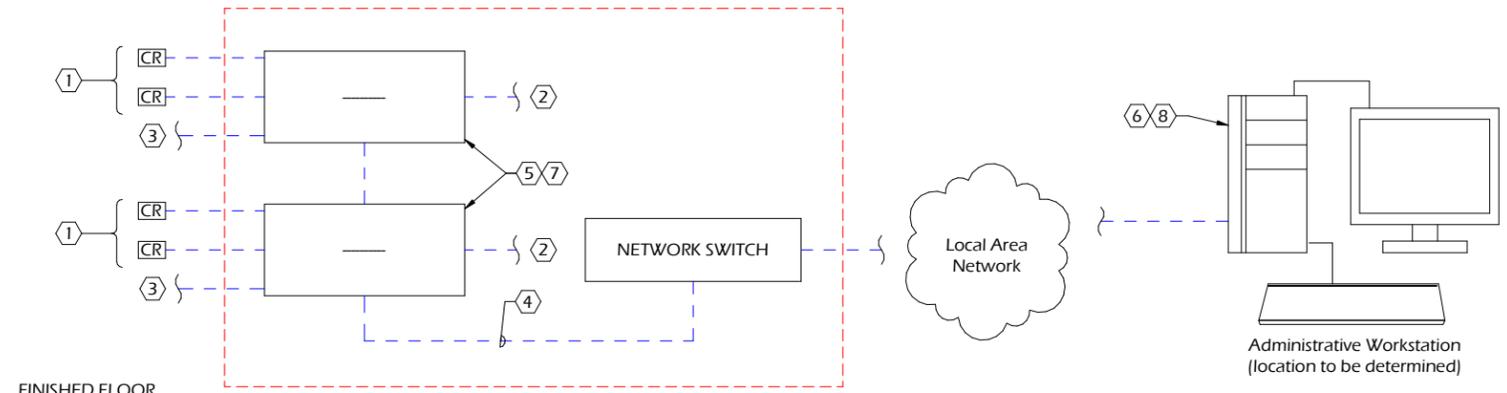

2 ONE-LINE DIAGRAM - ACCESS CONTROL SYSTEM
N.T.S.

Key Notes:

- 1 Verify and provide exact quantity of card readers, door position switch inputs, and miscellaneous signal inputs as shown on contract drawings.
- 2 Interface with electric locks per the contract specifications. Integrate all controlled outputs into access control system. Verify quantity of all controlled outputs with contract drawings.
- 3 Coordinate with fire alarm to effect immediate release of access controlled doors by the fire alarm system upon activation of the fire alarm signal.
- 4 Interface with building network by providing category 6 data cables between access control panels and owner provided network switch.
- 5 Provide battery back-up equipment at each reader interface panel to support the ACS for a period of 30 minutes.
- 6 Load and program client software on one(1) existing workstation. Customize system with locking schedules, point id's, etc... as required by the owner. Integrate video system with the access control system. Program system for camera call-up in the event of an alarm notification on doors/areas specified by owner.
- 7 Reader interface boards shall be required for all door openings requiring door position switches and rex signals.
- 8 US Forest Service to provide two(2) Static IP addresses.

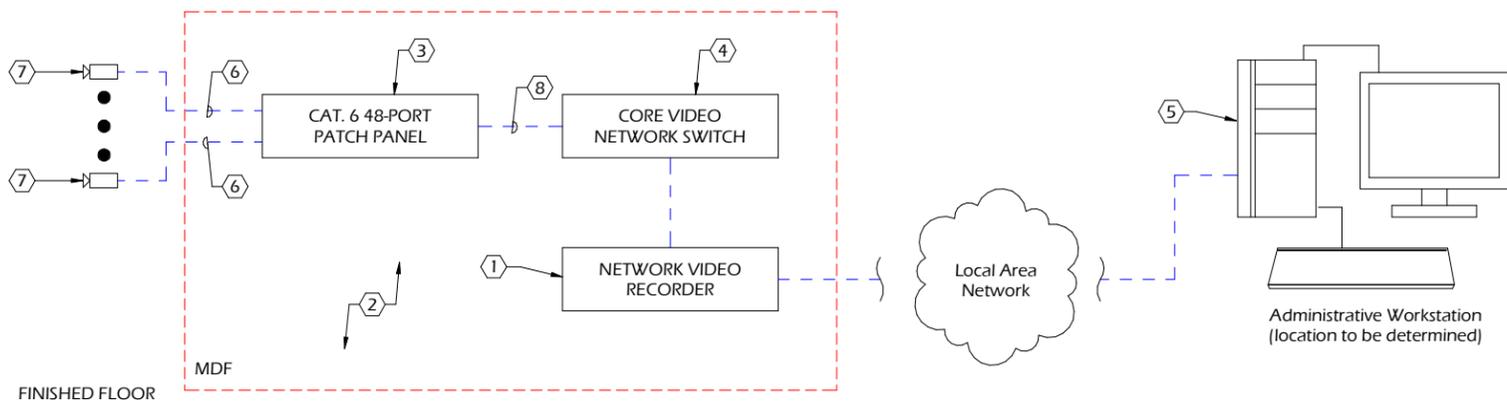

3 ONE-LINE DIAGRAM - VIDEO SURVEILLANCE SYSTEM
N.T.S.

Key Notes:

- 1 Provide all required video storage. Provide all required licensing for required video management system.
- 2 Configure VMS system for "activity detection recording". See specifications for requirements. All video to be configured to be maintained for a minimum of 30 days.
- 3 Category 6 cables and associated data patch panels to be provided by telecom contractor.
- 4 Owner to provide core switch and power-over-ethernet switch mounted in telecom rack.
- 5 Load and configure video surveillance software on up to three(3) owner provided workstations. all camera setting to be programmed by contractor to owner's satisfaction.
- 6 Provide and install one(1) category 6 cable for each IP device.
- 7 Provide and install low light, wide dynamic range (WDR), color, IP megapixel cameras for interior locations. See floor plans for locations. See camera schedule for mounting requirements.
- 8 Provide and install all category 6 patch cables.



United States Department of Agriculture
Forest Service

R-08
Southern Region

PROJECT NAME:

R-08 SOUTHERN REGION OFFICE SPACE TOOLS & TEMPLATES

UNITED STATES DEPARTMENT OF AGRICULTURE FOREST SERVICE

SOUTHERN REGION (R8)
1720 PEACHTREE ROAD, NW
ATLANTA, GA 30309

DRAWING TITLE

ONE-LINE DIAGRAM - CATV-CCTV-ACCESS CTRL

DATE

05/24/19

ARCHIVE NUMBER:

DESIGNER:

US FOREST SERVICE/TSW

DWG SHEET NO:

A603

DRAWN BY:

US FOREST SERVICE/TSW


CHECKED BY:

US FOREST SERVICE

PROJECT NO:

19031

SHEET XXX OF XXX

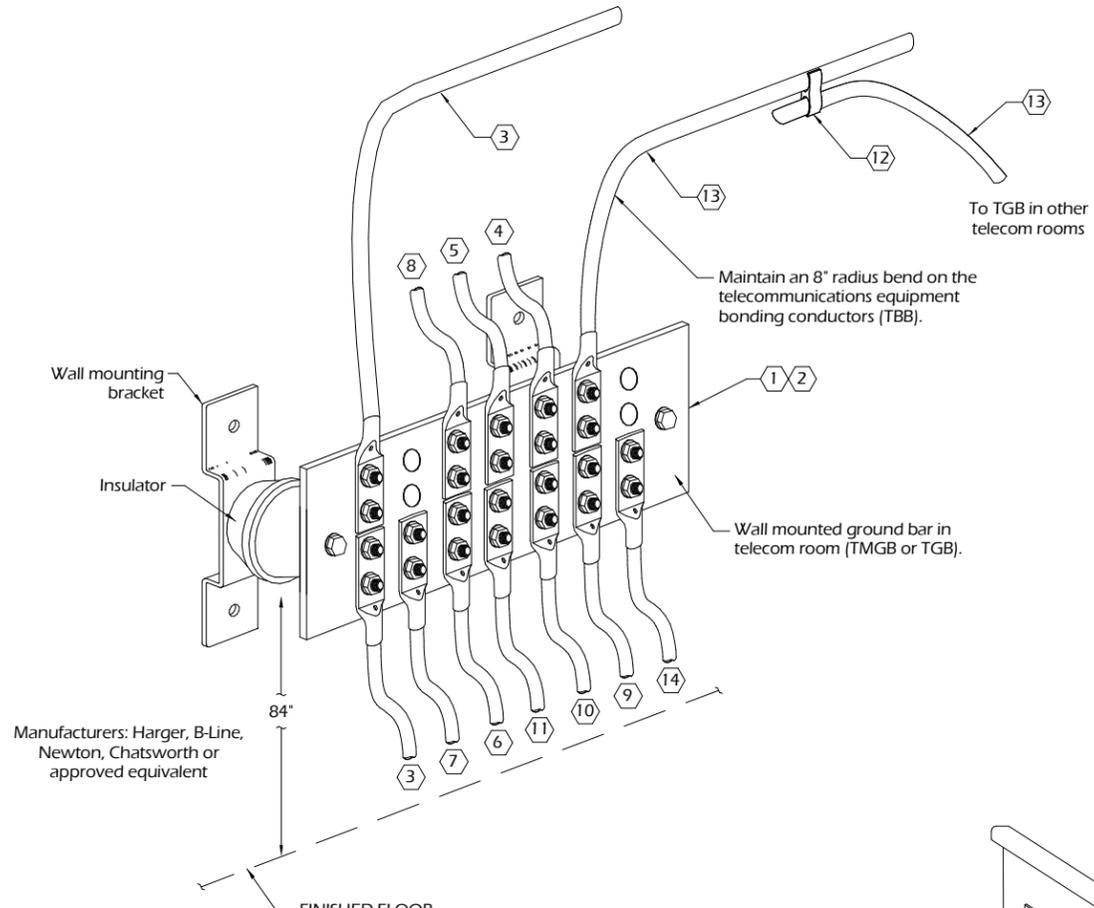





General Notes:

- A. Telecommunications bonding backbone (TBB) shall be a continuous conductor and shall be spliced to telecommunications ground busbars with a short bonding conductor. Use conductor table to calculate TBB size. Comply with all requirements of nasi/tia-607b.
- B. Grounding equalizer (GE) shall be a continuous conductor and shall be spliced to telecommunications ground busbars with a short bonding conductor. Use conductor table to calculate GE size. Comply with all requirements of ansi/tia-607c.
- C. All grounding lugs shall be two hole, no exceptions.

CONDUCTOR TABLE	
LINEAR LENGTH (FT.)	SIZE (AWG)
LESS THAN 13	6
14 - 20	4
21 - 26	3
27 - 33	2
34 - 41	1
42 - 52	1/0
53 - 66	2/0
GREATER THAN 67	3/0

Key Notes:

- 1 Provide and install telecommunications main grounding busbar (TMGB). TMGB shall be pre-drilled copper busbar with standard nema bolt hole sizing and spacing. Minimum sizing shall be 1/4" thick x 4" wide x 24" length.
- 2 Provide and install telecommunications grounding busbar (TGB). TGB shall be pre-drilled copper busbar with standard nema bolt hole sizing and spacing. Minimum sizing shall be 1/4" thick x 4" wide x 18" length.
- 3 Provide and install bonding conductor for telecommunications (BCT) to building main electrical grounding system. Use conductor table to calculate BCT size. Note: the BCT and the TBB shall be the same size based upon the larger conductor.
- 4 Provide and install bonding conductor for telecommunications (BCT) to electrical panels within the MDF and IDF rooms. Use conductor table to calculate BCT size.
- 5 Provide and install bonding conductor to the building steel. Use conductor table to calculate conductor size. same size as (TBB).
- 6 Provide and install telecommunications equipment bonding conductor (TEBC) routed on ladder rack to bond each telecommunications rack or cabinet to the TMGB or TGB. Use conductor table to calculate conductor size. Each TEBC shall be a continuous conductor. Splice a #6AWG conductor using an irreversible compression or exothermal weld from the TEBC to each rack or cabinet mounted grounding busbar. Daisy chaining from one rack or cabinet to another is not acceptable.
- 7 Provide and install telecommunications equipment bonding conductor (TEBC) from TMGB or TGB to each level of the ladder rack system with a #6AWG conductor. Each section of the ladder rack system shall be bonded together with cable runway straps.
- 8 Provide and install telecommunications equipment bonding conductor (TEBC) from TMGB or TGB to each EMT conduit used for backbone cabling with a #6AWG conductor. Conduit shall be bonded on both ends.
- 9 Provide and install telecommunications equipment bonding conductor (TEBC) from TMGB or TGB to each metal jacket of the armored fiber optic cable with a #6AWG conductor. Metal jacket shall be bonded on both ends.
- 10 Provide and install telecommunications equipment bonding conductor (TEBC) from TMGB or TGB to sub floor pedestal support system used for distributing horizontal cabling under the floor. Use conductor table to calculate conductor size.
- 11 Provide and install grounding equalizer (GE) conductor. the GE connects the telecommunications grounding busbar(s) in the same-floor telecommunication rooms served from different TBB conductors. Use conductor table to calculate GE conductor size.
- 12 Irreversible compression type connector or exothermic weld.
- 13 Provide and install telecommunications bonding backbone conductor (TBB) routed in conduit to bond each telecommunications room to the TMGB. Use conductor table to calculate conductor size. The TBB shall be a continuous conductor.

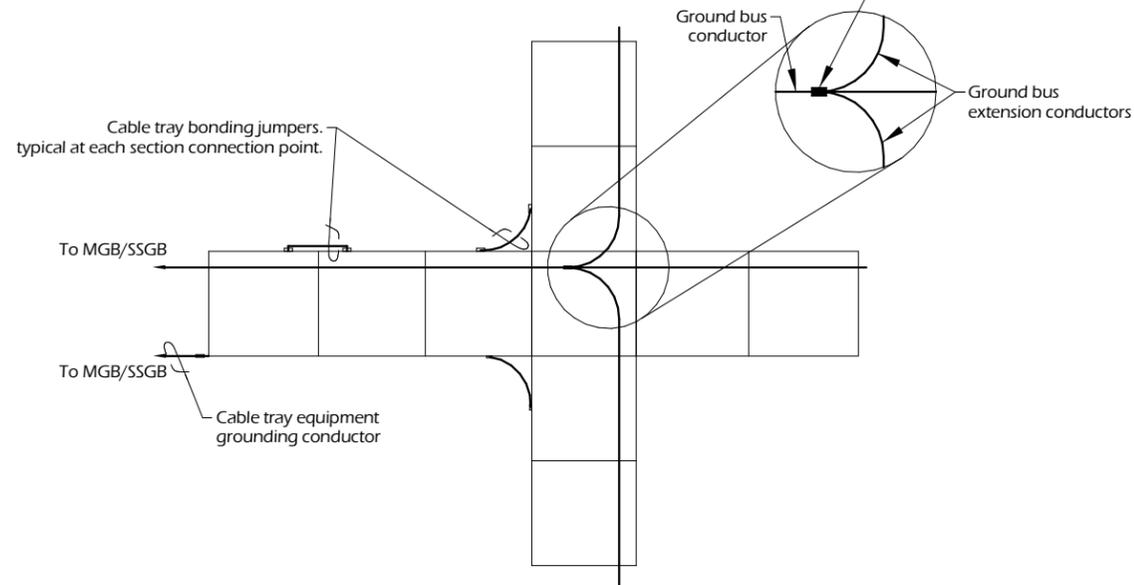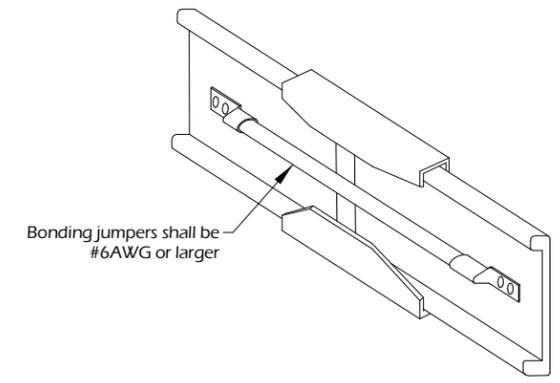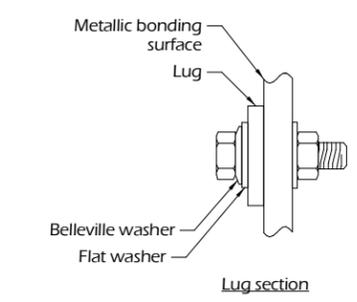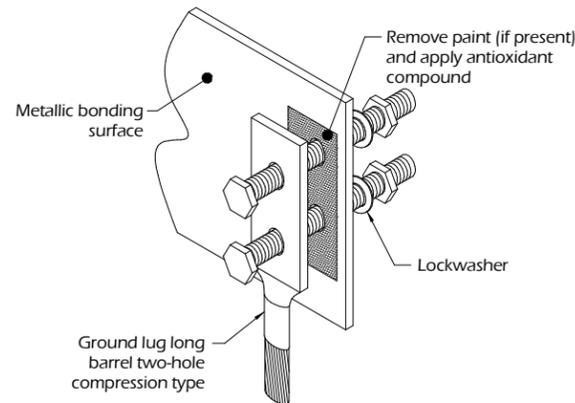

United States Department of Agriculture
Forest Service

R-08
Southern Region

PROJECT NAME:

R-08 SOUTHERN REGION OFFICE SPACE TOOLS & TEMPLATES

UNITED STATES DEPARTMENT OF AGRICULTURE FOREST SERVICE

SOUTHERN REGION (R8)
1720 PEACHTREE ROAD, NW
ATLANTA, GA 30309

DRAWING TITLE

DETAILS

DATE
05/24/19

ARCHIVE NUMBER:

DESIGNER:
US FOREST SERVICE/TSW


DWG SHEET NO:
A604

DRAWN BY:
US FOREST SERVICE/TSW


CHECKED BY:
US FOREST SERVICE

PROJECT NO:
19031


SHEET XXX OF XXX

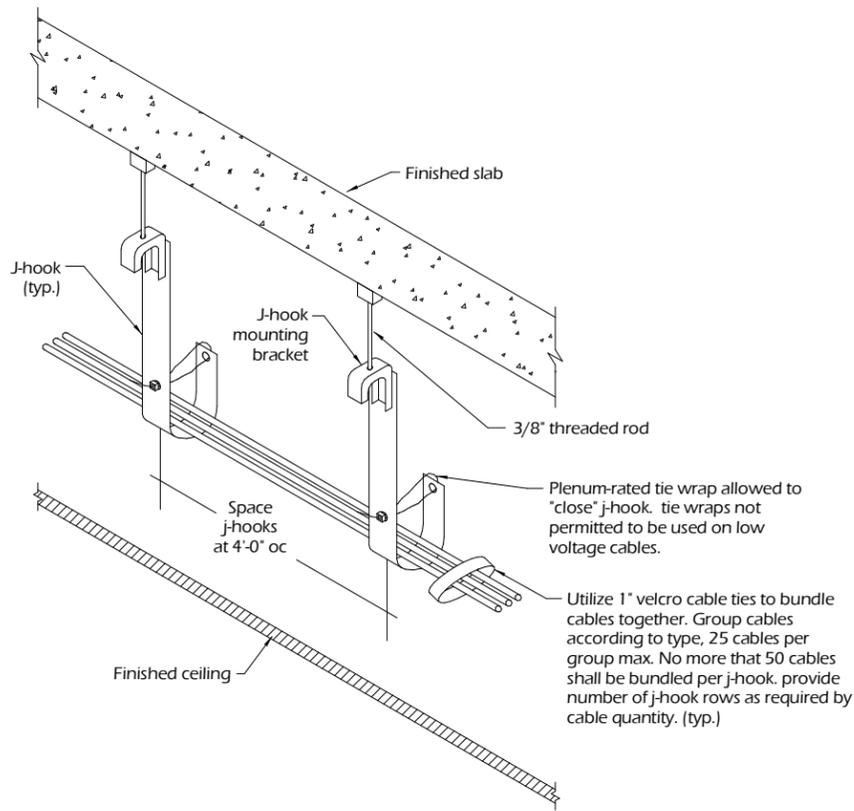


DETAIL NOT TO SCALE **1** ACCESSIBLE CEILING CABLE INSTALLATION DETAIL

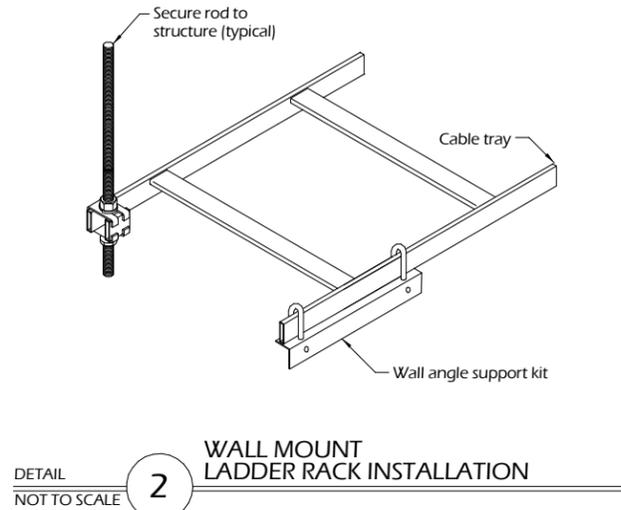

DETAIL NOT TO SCALE **2** WALL MOUNT LADDER RACK INSTALLATION

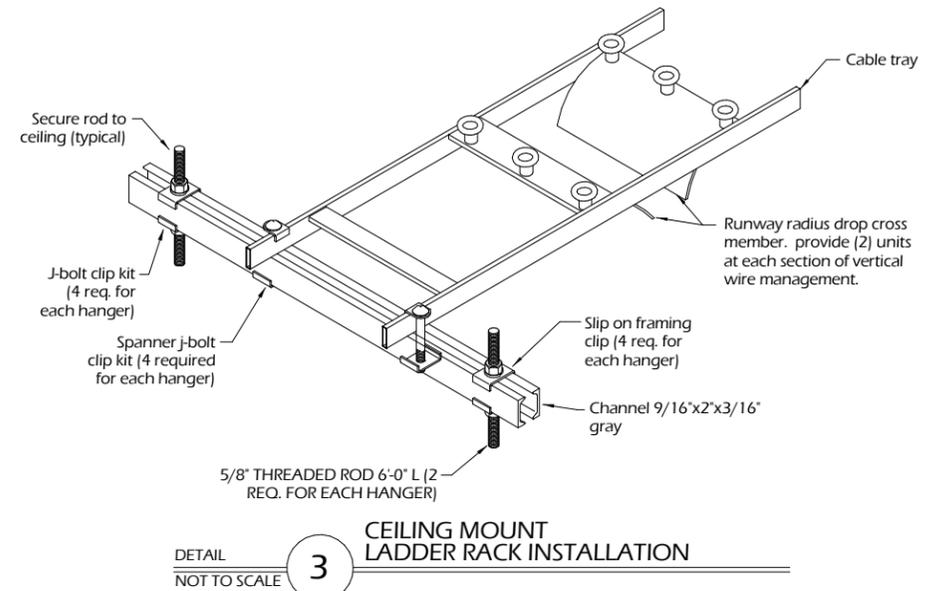


DETAIL NOT TO SCALE **3** CEILING MOUNT LADDER RACK INSTALLATION

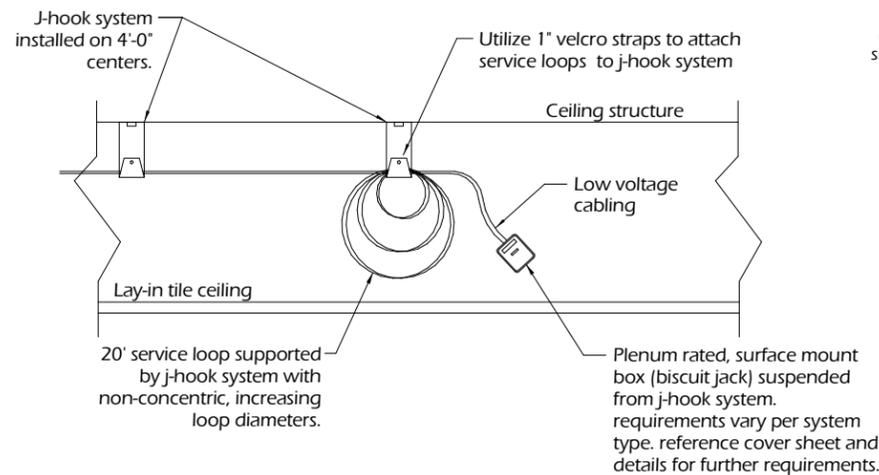

General Notes:

- A. Biscuit jack shall be plenum rated, dual port, category 6 type for all wireless access point locations.
- B. Biscuit jack shall be plenum rated, single port, category 6 type for all video surveillance camera locations.

DETAIL NOT TO SCALE **4** SUSPENDED BISCUIT JACK

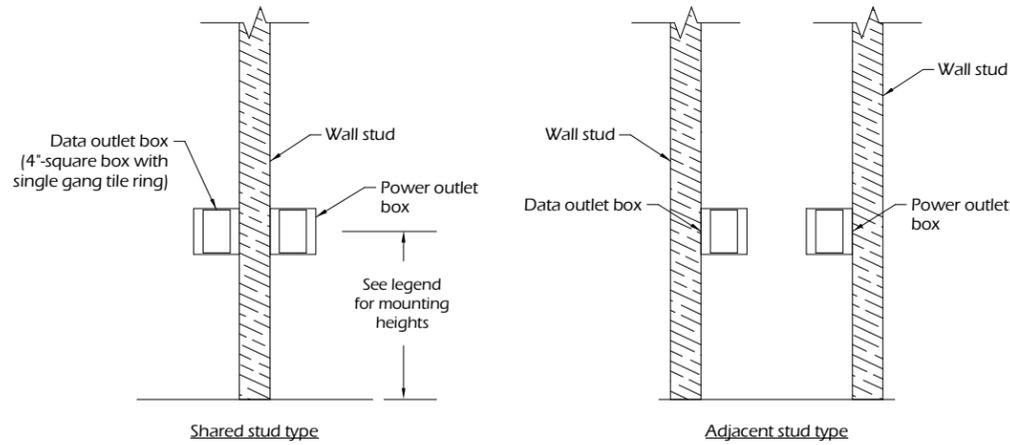

General Notes:

- A. All data outlets to be coordinated with electrical power locations. data outlets shall be mounted adjacent to power receptacles at same height.
- B. Aata outlet shall either be mounted on opposite side of shared stud as power or data shall be mounted on adjacent stud to power in same wall cavity.
- C. Typical data outlet height shall be 18", unless otherwise noted. Coordinate exact mounting heights and orientation with electrical and architectural plan.
- D. Verify all data outlets to be provided with adjacent power receptacle. Submit RFI if condition does not exist.
- E. Provide shop drawings/elevation for architect review

DETAILS NOT TO SCALE **5** TYPICAL DATA OUTLET INSTALLATION REQUIREMENTS

R-08
Southern Region

PROJECT NAME:

R-08 SOUTHERN REGION OFFICE SPACE TOOLS & TEMPLATES

UNITED STATES DEPARTMENT OF AGRICULTURE FOREST SERVICE

SOUTHERN REGION (R8)
1720 PEACHTREE ROAD, NW
ATLANTA, GA 30309

DRAWING TITLE

DETAILS

DATE
05/24/19

ARCHIVE NUMBER:

DESIGNER:
US FOREST SERVICE/TSW


DWG SHEET NO:
A605

DRAWN BY:
US FOREST SERVICE/TSW


CHECKED BY:
US FOREST SERVICE

PROJECT NO:
19031


SHEET XXX OF XXX

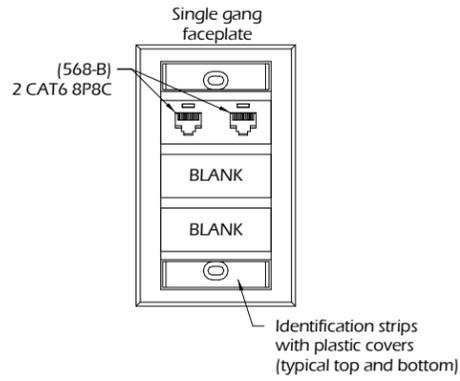


DETAIL NOT TO SCALE **1** TYPICAL 2-PORT OUTLET

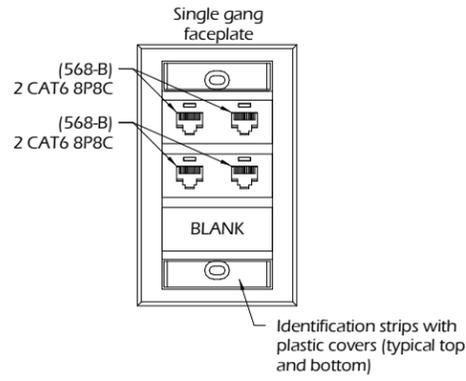


DETAIL NOT TO SCALE **2** TYPICAL 4-PORT OUTLET

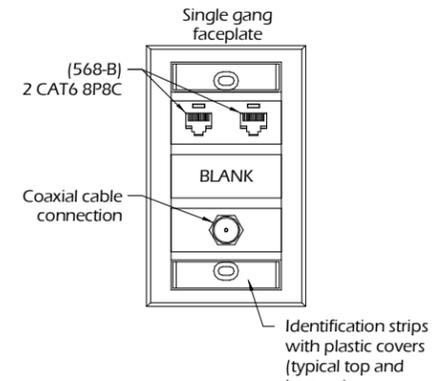


DETAIL NOT TO SCALE **3** TYPICAL DISPLAY OUTLET

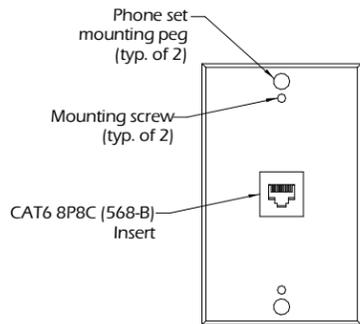

DETAIL NOT TO SCALE **4** TYPICAL WALL PHONE PLATE

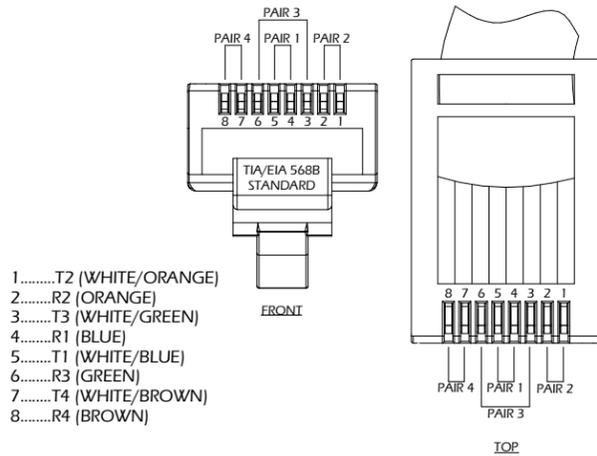

DETAIL NOT TO SCALE **5** RJ45 JACK TERMINATION

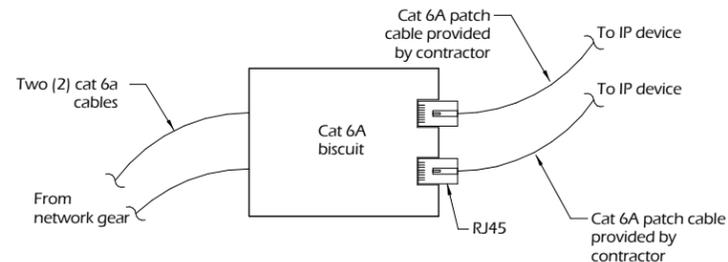

DETAIL NOT TO SCALE **6** WIRELESS ACCESS POINT TYPICAL ETHERNET BISCUIT



United States Department of Agriculture
Forest Service

R-08

Southern Region

PROJECT NAME:
R-08 SOUTHERN REGION OFFICE SPACE TOOLS & TEMPLATES

UNITED STATES DEPARTMENT OF AGRICULTURE FOREST SERVICE

SOUTHERN REGION (R8)
1720 PEACHTREE ROAD, NW
ATLANTA, GA 30309

DRAWING TITLE
DETAILS


DATE
05/24/19

ARCHIVE NUMBER:


DESIGNER: US FOREST SERVICE/TSW	DWG SHEET NO: A606
DRAWN BY: US FOREST SERVICE/TSW	

CHECKED BY: US FOREST SERVICE	
----------------------------------	--


PROJECT NO: 19031	SHEET XXX OF XXX
----------------------	------------------

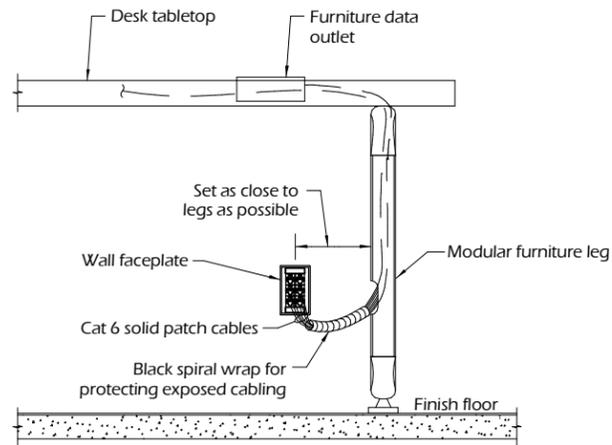

DETAIL NOT TO SCALE **1** WALL MOUNT FURNITURE FEED DETAIL

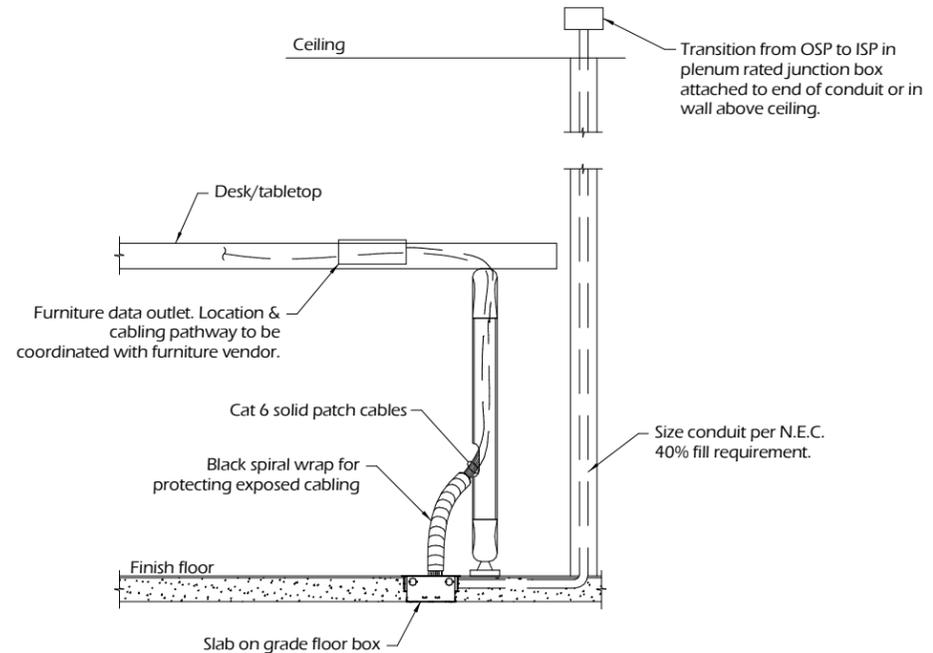


DETAIL NOT TO SCALE **2** FLOOR BOX FURNITURE FEED DETAIL MOUNTED IN SLAB ON GRADE

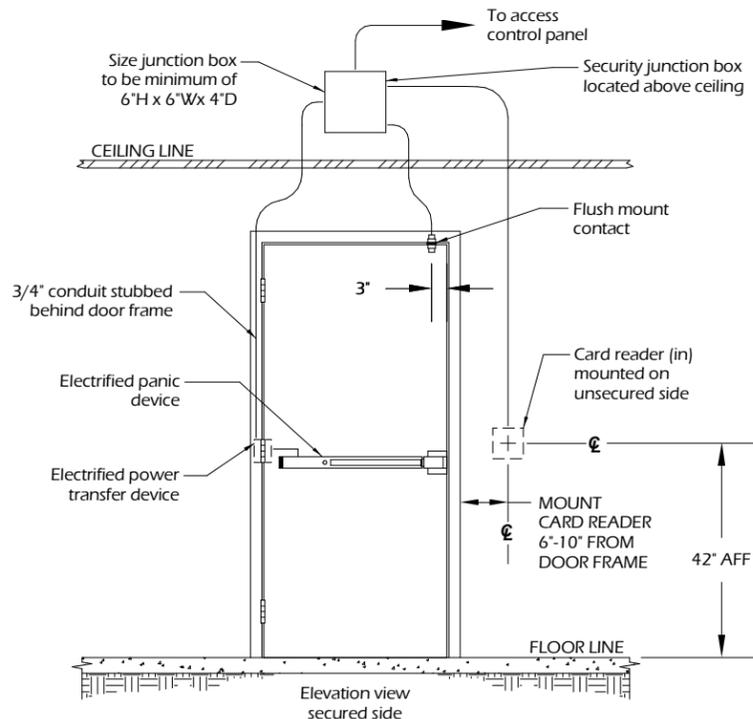

Single door with card reader, door contact, electrified panic device, power transfer device

DETAIL NOT TO SCALE **3** SINGLE DOOR DETAIL

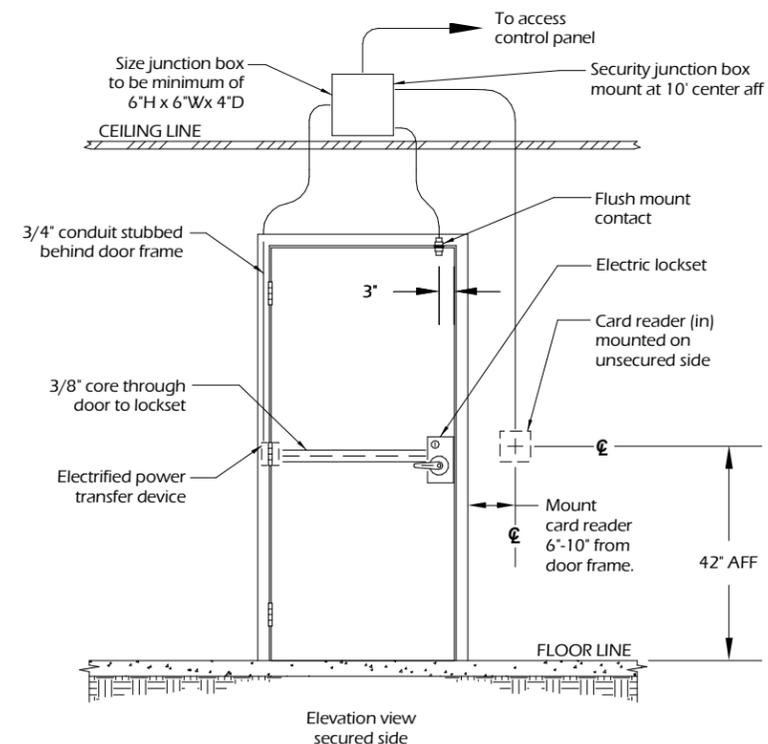

Single door with card reader (in), door contact, mortise lockset, power transfer hinge

DETAIL NOT TO SCALE **4** SINGLE DOOR DETAIL

R-08
 Southern Region

PROJECT NAME:

R-08 SOUTHERN REGION OFFICE SPACE TOOLS & TEMPLATES

UNITED STATES DEPARTMENT OF AGRICULTURE FOREST SERVICE

SOUTHERN REGION (R8)
 1720 PEACHTREE ROAD, NW
 ATLANTA, GA 30309

DRAWING TITLE

DETAILS

DATE
 05/24/19

ARCHIVE NUMBER:

DESIGNER:
 US FOREST SERVICE/TSW

DWG SHEET NO.:


A607

DRAWN BY:
 US FOREST SERVICE/TSW



CHECKED BY:
 US FOREST SERVICE

SHEET XXX OF XXX

PROJECT NO:
 19031

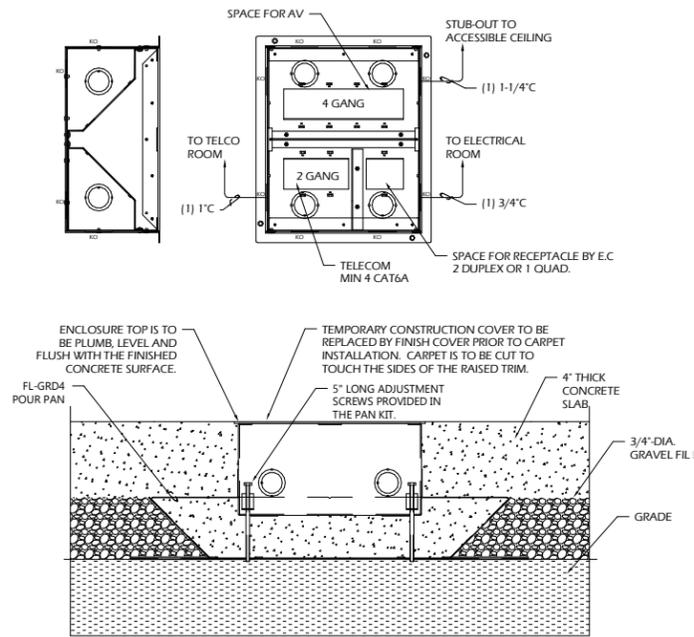

1 FLOORBOX - CONCRETE FLOOR - BASIS OF DESIGN (FSR FL-500P-6)
N.T.S.

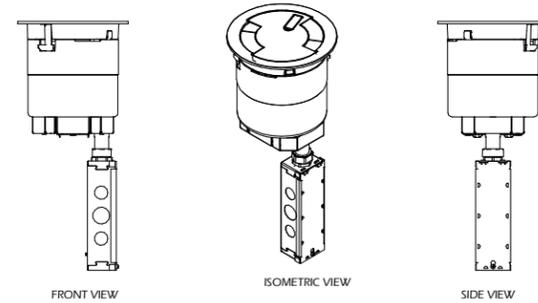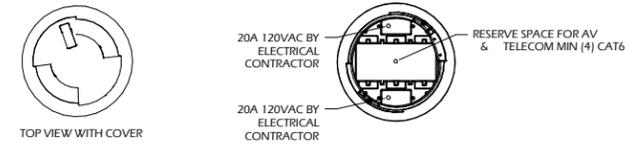

2 FLOOR BOX - BASIS OF DESIGN - POKE - THROUGH TYPE (WIREMOLD 8ATC)
N.T.S.



United States Department of Agriculture
Forest Service

R-08

Southern Region

PROJECT NAME:

R-08 SOUTHERN REGION OFFICE SPACE TOOLS & TEMPLATES

UNITED STATES DEPARTMENT OF AGRICULTURE
FOREST SERVICE

SOUTHERN REGION (R8)
1720 PEACHTREE ROAD, NW
ATLANTA, GA 30309

DRAWING TITLE

DETAILS

DATE
05/24/19

ARCHIVE NUMBER:

DESIGNER:
US FOREST SERVICE/TSW

DWG SHEET NO:

A608

DRAWN BY:
US FOREST SERVICE/TSW

CHECKED BY:
US FOREST SERVICE

PROJECT NO:
19031

SHEET XXX OF XXX